

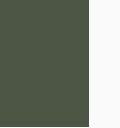
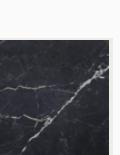
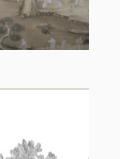
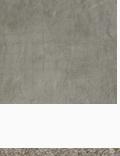
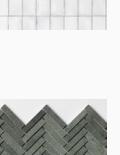


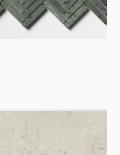

PROJECT NOTES		FINISH SCHEDULE		LIGHTING SCHEDULE	
1.DIMENSIONS ON PLANS ARE TO BE FACE OF GWB/METAL STUD PARTITIONS AND CORRIDOR SIDE FINISH FACE OF CORRIDOR PARTITIONS UNLESS OTHERWISE NOTED.			P-1	RESTAURANT/BAR WALL & CEILING PAINT - SW 9580 -FLAT	
2.ALL VERT & HORIZONTAL DUCTS, PIPES, CONDUIT, ETC. (WHETHER SHOWN OR NOT) IN FINISHED ROOMS NOT ENCASED IN FINISHED WALLS OR CEILINGS SHALL BE FURRED IN AND FINISHED TO MATCH ADJACENT FINISH SURFACES AT ALL NEW WORK.			P-2	LOUNGE- CEILING PAINT - SW 0065- FLAT	
3.STUD THICKNESS SHALL BE INCREASED AS REQ'D AT PLUMBING HANGERS, ELECT. PANELS, ETC., WHICH EXCEED 4" FROM FINISH WALL FACE TO BACK OF UNIT.			H-P01	SW 7570 - FLAT EGRET WHITE	
4.FURNISH ACCESS PANELS IN WALLS AND NON ACCESSIBLE TYPE CEILING WHERE SERVICE OR ADJUSTMENT TO MECHANICAL, PLUMBING OR ELECTRICAL EQUIPMENT IS REQUIRED. (SEE ENGINEERING DRAWINGS FOR ANY REQUIRED ACCESS PANEL(S) FOR THIS PROJECT.)			H-P02	CEILING PAINT SW 7005- FLAT PURE WHITE	
5.PROVIDE CONTROL JOINT IN GYP WALLBOARD AT 30 FT O.C. MAX PER MANUFACTURE'S RECOMMENDATIONS WHERE POSSIBLE, LOCATE JOINTS AB OVE DOOR FRAMES.			H-P03	WALL PAINT SW 7037 BALANCED BEIGE	
6.GYP. WALLBORAD IN TOLIETS, AND OTHER AREAS SUBJECT TO WETTING, SHALL BE MOISTURE RESISTANT TYPE ON WALLS. WALLS TO RECEIVED CERAMIC TILE, FINISH GRYPUSM WALLBOARDS SHALL BE MOISTURE RESISTANT TYPE.			WC-1	HAND-PAINTED CHINESE LANDSCAPE. TYPE II / 20 OUNCE. VINYL SCRIM BACKING - RESTAURANT	
7.ALL GYP. WALLBOARD IN FIRE RATED WALLS SHALL BE FIRE RESISTIVE UL CLASSIFIED MATERIAL APPLIED IN STRICT CONFORMANCE TO THE APPLICABLE FIRE TEST DESIGN WITH JOINTS ON OOPPOSITE WALL FACES STAGGERED FASTENERS SHALL BE OF APPROVED TYPE AND INTSTALLED IN ACCORDANCE WITH APPICALE FIRE TEST. ALL WALLBOARD JOING SHALL BE TAPEAD AND FINISHED WITH JOINT COMPOUND, INCLUDING THOSE ABOVE THE CEILING WHETHER FIRE "RATED OR NOT". PENETRATION FOR PIPES, CONDUIT, DUCTS, ETC., IN EXCESS OF 8" IN MAXIMUM DIMENSION SHALL BE FRAMED. PERIMETER OF PENTRATIONS SHALL BE TIGHTLY PACKED WITH MINERAL FIBER SAFE INSULATION.			WC-2	FOREST SCENE - GREEN/CREAM BACK GROUND. TYPE II / 20 OUNCE. VINYL SCRIM BACKING - LOUNGE	
8.INTERPRETATION, ERRORS AND OMISSIONS SHOULD ANY OMISSION, DISCREPANCY, AMBIGUITY OR ERROR IN THE CONTRACT DOCUMENT DRAWINGS BE DISCOVERED OR SHOULD THERE BE ANY DOUBT AS TO THE MEANING OR INTENT THEREOR, REPORT SUCH FINDINGS TO THE ARCHITECT IN WRITING. CLARIFICATION WILL BE MADE BY REVISON TO DRAWINGS, WHICH WILL BE SENT TO THE GENERAL CONTRACTOR IN THE EVENT OF THE CONTRACTOR'S FAILURE TO GIVE SUCH NOTICE. HE WILL BE HELD RESPOINSIBLE FOR THE RESULTS OF ANY SUCH DEFECTS, ERRORS OR OMISSIONS AND COST OF RECTIRYING THE SAME IF DURING THE COURSE OF CONSTRUCTION, CONFLICTS ARE FOUND IN THE DRAWINGS OR EXSITING SITE CONDITIONS, THE ARCHITECT WILL INTERPRET OR CONSTRUE THE DRAWING(S) AND/OR EXISTING SITE CONDISTIONS SO AS TO SECURE THE MOST SUBSTAINTIAL AND COMPLETE. PERFORMANCE OR THE WORK.			BM-01	EWBB52 SQUARE EDGE 3-1/2" TALL x 3/4" BASEBOARD MOLDING	
			CM-01	94.5" NATURAL WALNUT TRIM PIECE	
			FG-1	"FROSTED SILVERLAKE" LAMINATED ARCHITECTURAL GLASS	
			P-1	HANDCRAFTED HEWN LEDGE WOOD BEAM - LOBBY FOYER	
			H-TL01	SHOWER WALL TILE- ATLASI TREASURE SERAMIC TILE SKU: 100782820	
			H-TL03	BATH VANITY ACCENT WALL TILE- VERDE TIA HONED HERRINGBONE 5/8X3 MARBLE MOSAIC	
			H-LS01	ACCENT WALL IN GUEST ROOMS - BEHIND BED AND TV DAL TILE DIGITARY- LIMESTONE TEXTILE - MATTE VISUAL	

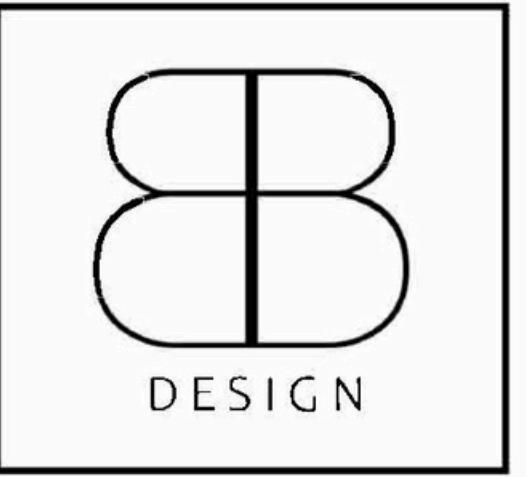

UNIVERSITY OF ALABAMA - INTERIOR DESIGN

BB DESIGN  
BEVERLY BRADSHAW  
2313 ROSEMONT PLACE  
(334)320-1818  
BCBRADSHAW@CRIMSON.UA.EDU

**GALINOIS**  
123 Ocean Drive,  
Naxos, Cyclades  
32480






































# Project Notes, Lighting and Finish Schedule

                                
ct Number	2000.01
	10 April, 2025
n By	Beverly Bradshaw
ed By	Bethany Blevins

GS

$$\frac{1}{4}'' = 1'-0''$$

## FURNITURE SCHEDULE

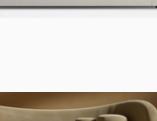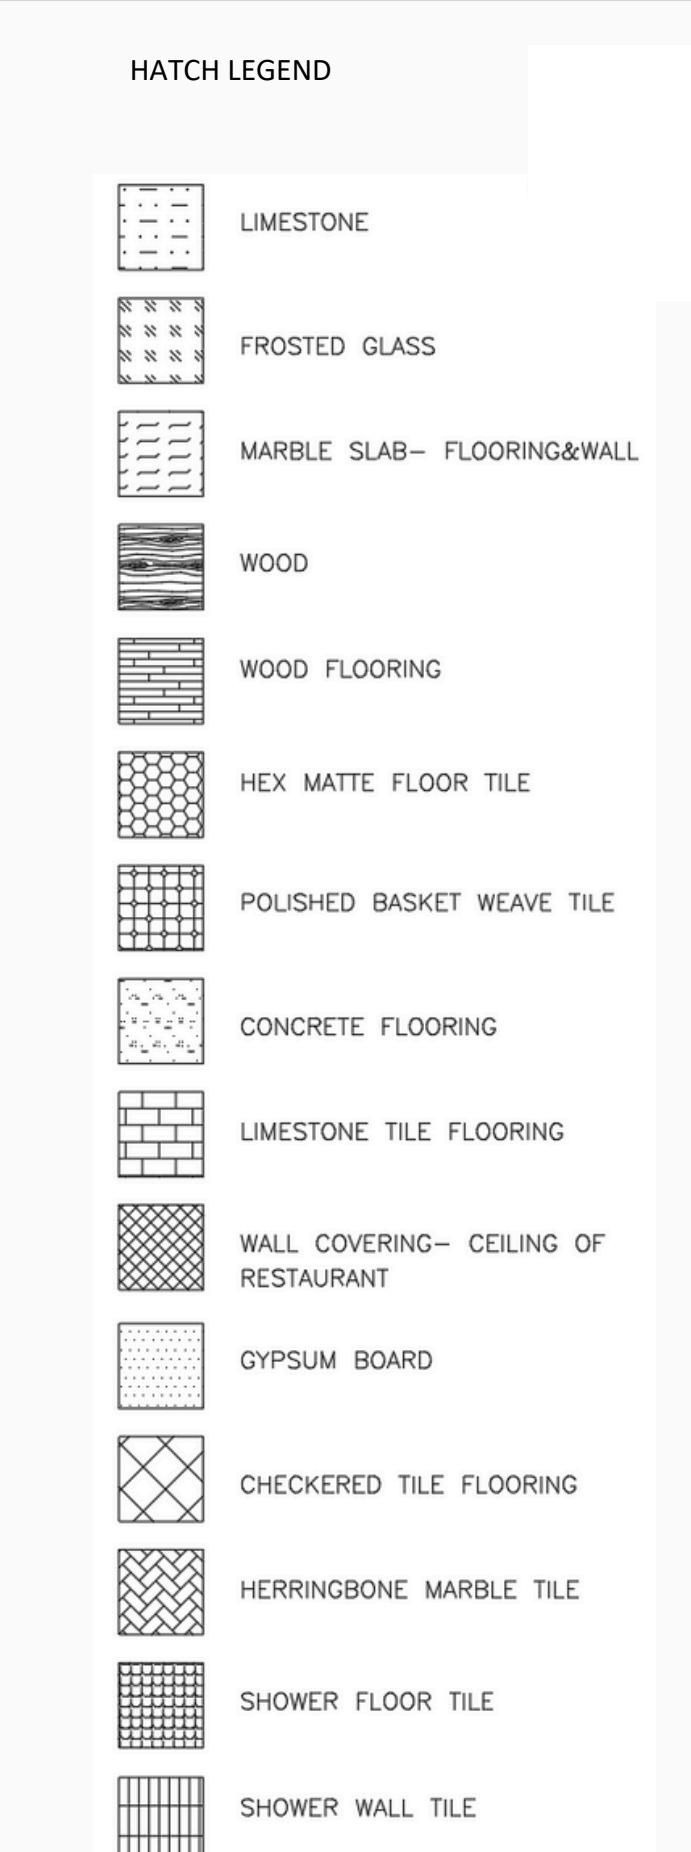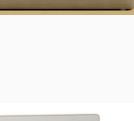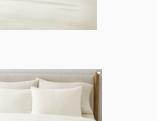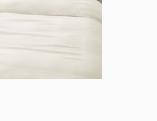	H-01	TOILET		H-19	CUSTOM CABINET UNIT		H-45	BATHROOM- CUSTOM OVER VANITY MIRRORS																														
	H-02	FREE STANDING BATHTUB		H-20	COFFEE TABLE		H-46	WALL ART- NORTH WALL OF KING AND QUEEN GUESTROOMS																														
	H-03	SHOWER HEAD KIT		H-21	END TABLE		H-47	WALL ART- QUEEN BATHROOMS																														
	H-04	SHOWER + BATH KIT		H-22	SIDE CHAIR 1		H-48	GUESTROOM- WALL MIRROR																														
	H-05	SINK FAUCET		H-23	UPHOLSTERED BENCH		H-49	HOSPITALITY WALL ART																														
	H-06	DROP IN BATHTUB		H-24	LARGE SOFA		H-50	ROOM NUMBER SIGNAGE- EXTERIOR OF ROOM																														
	H-07	MINI FRIDGE		H-25	SMALL SOFA	 <p>HATCH LEGEND</p> <table><tbody><tr><td></td><td>LIMESTONE</td></tr><tr><td></td><td>FROSTED GLASS</td></tr><tr><td></td><td>MARBLE SLAB- FLOORING&amp;WALL</td></tr><tr><td></td><td>WOOD</td></tr><tr><td></td><td>WOOD FLOORING</td></tr><tr><td></td><td>HEX MATTE FLOOR TILE</td></tr><tr><td></td><td>POLISHED BASKET WEAVE TILE</td></tr><tr><td></td><td>CONCRETE FLOORING</td></tr><tr><td></td><td>LIMESTONE TILE FLOORING</td></tr><tr><td></td><td>WALL COVERING- CEILING OF RESTAURANT</td></tr><tr><td></td><td>GYPSUM BOARD</td></tr><tr><td></td><td>CHECKERED TILE FLOORING</td></tr><tr><td></td><td>HERRINGBONE MARBLE TILE</td></tr><tr><td></td><td>SHOWER FLOOR TILE</td></tr><tr><td></td><td>SHOWER WALL TILE</td></tr></tbody></table>		LIMESTONE		FROSTED GLASS		MARBLE SLAB- FLOORING&WALL		WOOD		WOOD FLOORING		HEX MATTE FLOOR TILE		POLISHED BASKET WEAVE TILE		CONCRETE FLOORING		LIMESTONE TILE FLOORING		WALL COVERING- CEILING OF RESTAURANT		GYPSUM BOARD		CHECKERED TILE FLOORING		HERRINGBONE MARBLE TILE		SHOWER FLOOR TILE		SHOWER WALL TILE	H-26	SIDE CHAIR 2
	LIMESTONE																																					
	FROSTED GLASS																																					
	MARBLE SLAB- FLOORING&WALL																																					
	WOOD																																					
	WOOD FLOORING																																					
	HEX MATTE FLOOR TILE																																					
	POLISHED BASKET WEAVE TILE																																					
	CONCRETE FLOORING																																					
	LIMESTONE TILE FLOORING																																					
	WALL COVERING- CEILING OF RESTAURANT																																					
	GYPSUM BOARD																																					
	CHECKERED TILE FLOORING																																					
	HERRINGBONE MARBLE TILE																																					
	SHOWER FLOOR TILE																																					
	SHOWER WALL TILE																																					
	H-09	SINGLE VANITY		H-27	LOUNGE CHAIR																																	
	H-10	CUSTOM DOUBLE VANITY		H-28	DESK CHAIR																																	
	H-11	QUEEN BED		H-29	DINING CHAIR																																	
	H-12	KING BED		H-38	QUEEN MATTRESS																																	
	H-13	QUEEN NIGHTSTAND		H-39	KING MATTRESS																																	
	H-14	CUSTOM TV UNIT		H-40	QUEEN DUVET COVERS AND SHAMS																																	
	H-15	DINING TABLE		H-41	KING DUVET COVERS AND SHAMS																																	
	H-16	SIDE TABLE		H-42	PLEATED LINEN CURTAINS																																	
	H-17	ACCENT TABLE		H-43	CAFE CURTAINS																																	
	H-18	DESK		H-44	FLOOR TO CEILING WALL MIRROR																																	

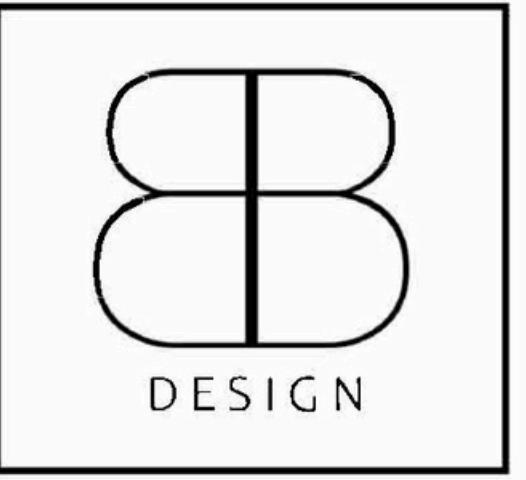

UNIVERSITY OF ALABAMA - INTERIOR DESIGN

**BB DESIGN**  
BEVERLY BRADSHAW  
2313 ROSEMONT PLACE  
(334)320-1818  
**BCBRADSHAW@CRIMSON.UA.EDU**

**GALINOIS**  
123 Ocean Drive,  
Naxos, Cyclades  
32480

# Furniture Schedule and All Legends

LEGEND	
FA	FIRE ALARM
FP	FIRE PULL
	FIRE EXTINGUISHER
	60" TURNING RADIUS
-----	EGRESS PATH
	EMERGENCY EXIT

NOTES

ELECTRICAL LEGEND	
	DUPLEX CONVENIENCE OUTLET
	GFI OUTLET
	220V OUTLET
	60V OUTLET
	JUNCTION BOX
	TELEPHONE
	CABLE
	INTERNET
NOTES:	
UNLESS OTHERWISE NOTED, ALL OUTLETS ARE 15" A.F.F. STANDARD AND 18" A.F.F. IN ADA ROOMS	


RCP LEGEND		
⊗	H-30	HANGING PENDANT LIGHT
⊗⊗	H-32	LARGE HANGING PENDANT
○	H-34	6" RECESSED CAN LIGHT
●	H-35	4" RECESSED CAN LIGHT
△	H-31	WALL SCONCE
□	H-33	LED STRIP LIGHT
⊛	H-36	DINING TABLE CHANDELIER
○○	-	FIRE SPRINKLER
□□	-	HVAC SUPPLY VENT
✉	-	HVAC RETURN VENT
□	-	EXHAUST FAN
●	-	8" HANGING PENDANT
○○	-	CEILING FLUSH PENDANT
⊛○	-	10" HANGING PENDANT
○○	-	LARGE CHANDELIER
⊛○	-	RETRO CHANDELIER

ject Number	2000.01
Entered	10 April, 2025
Own By	Beverly Bradshaw
Checked By	Bethany Blevins

GS2

$$\frac{1}{4}'' = 1'-0''$$



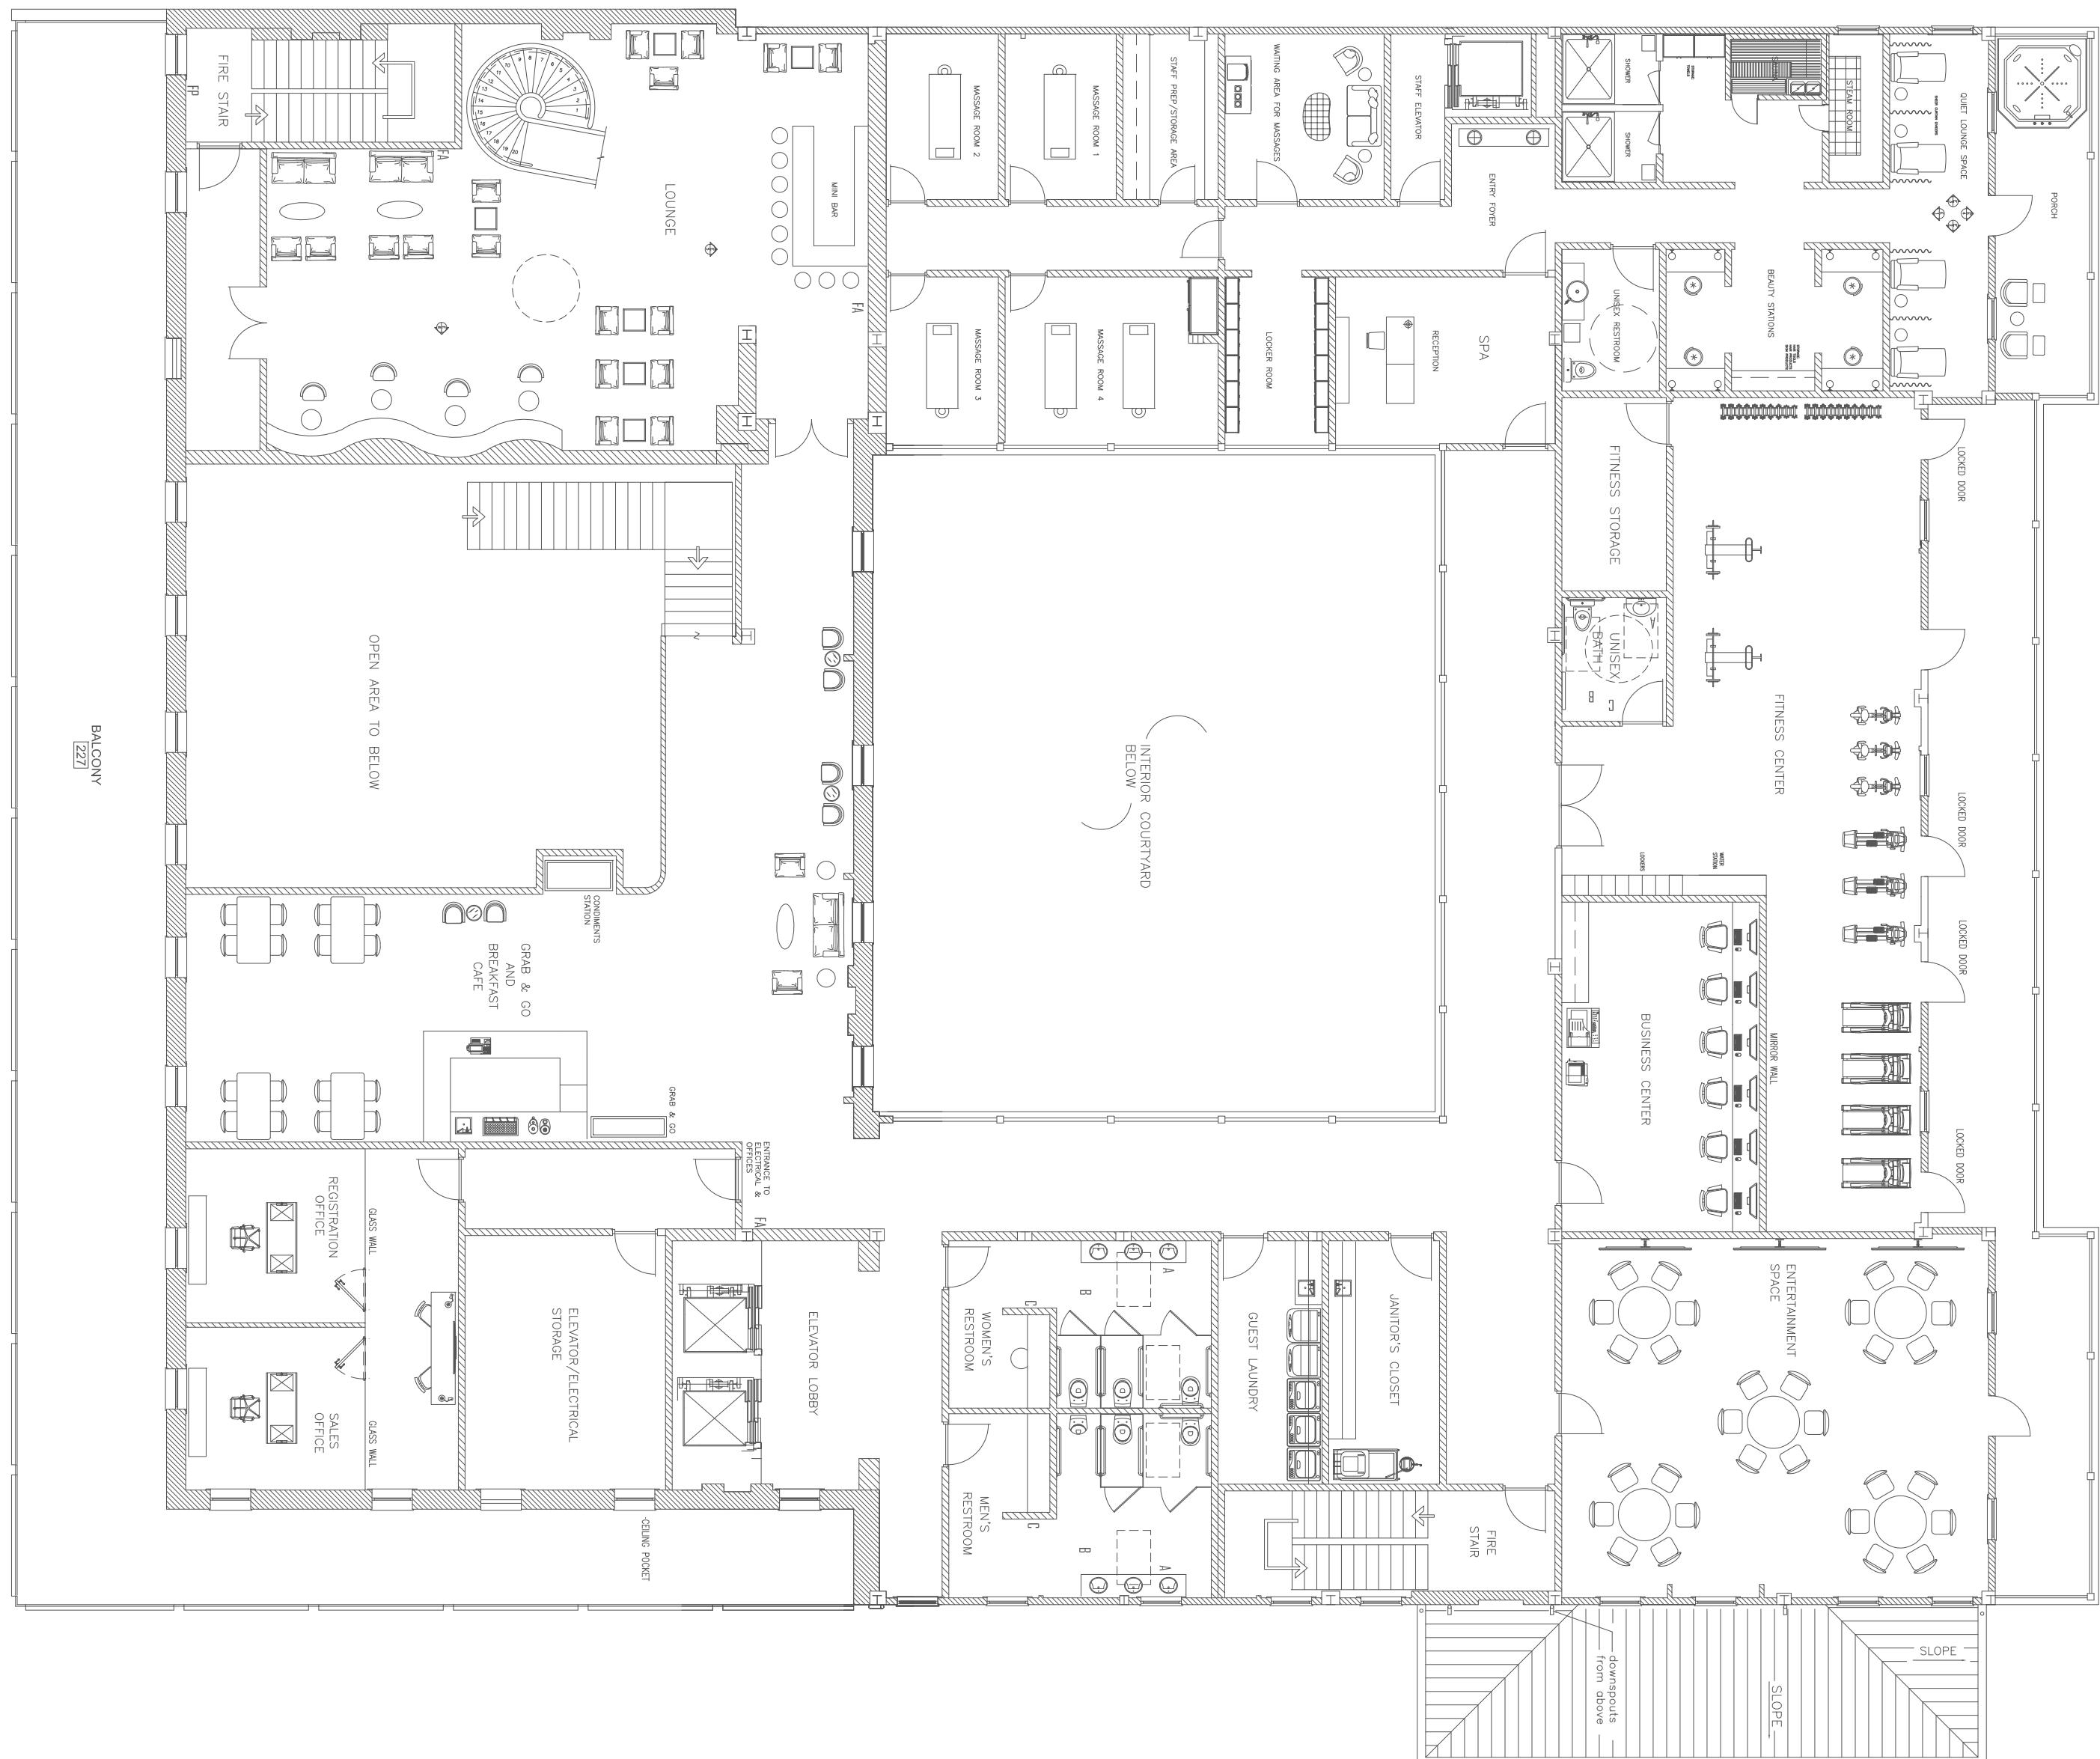

## GALINOIS

123 Ocean Drive,  
Naxos, Cyclades  
32480

### Overall Second Floor Plan

Project Number  
2000.01

Date  
10 April, 2025


Drawn By  
Beverly Bradshaw

Checked By  
Bethany Bleevins

Scale  
 $\frac{3}{32}'' = 1'-0''$

BB DESIGN  
BEVERLY BRADSHAW  
2313 ROSEMONT PLACE  
(334)320-1818  
BCBRADSHAW@CRIMSON.UA.EDU

UNIVERSITY OF ALABAMA - INTERIOR DESIGN

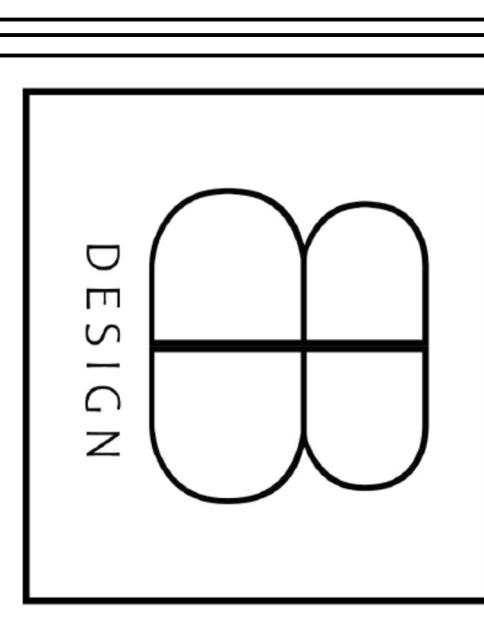




## Overall Typical 3rd-5th Floor Plan

**GALINOIS**

123 Ocean Drive,  
Naxos, Cyclades  
32480

**BB DESIGN**  
BEVERLY BRADSHAW  
2313 ROSEMONT PLACE  
(334)320-1818  
BCBRADSHAW@CRIMSON.UA.EDU

UNIVERSITY OF ALABAMA - INTERIOR DESIGN

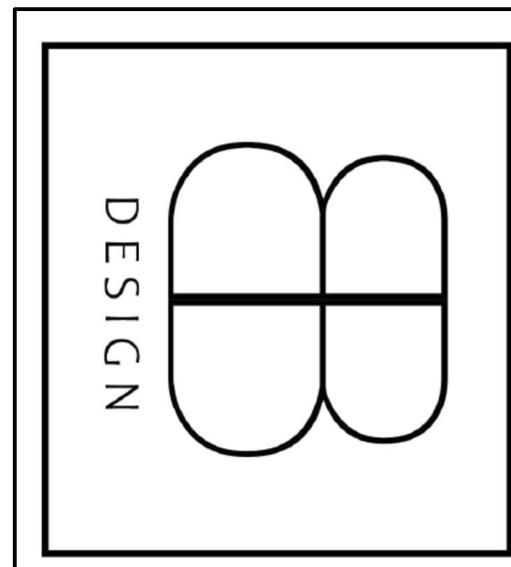


No.      Description      Date

Project Number      2000.01  
Drawn By      Beverly Bradshaw  
Checked By      Bethany Blevins

Scale

$\frac{3}{32}$ " = 1'-0"

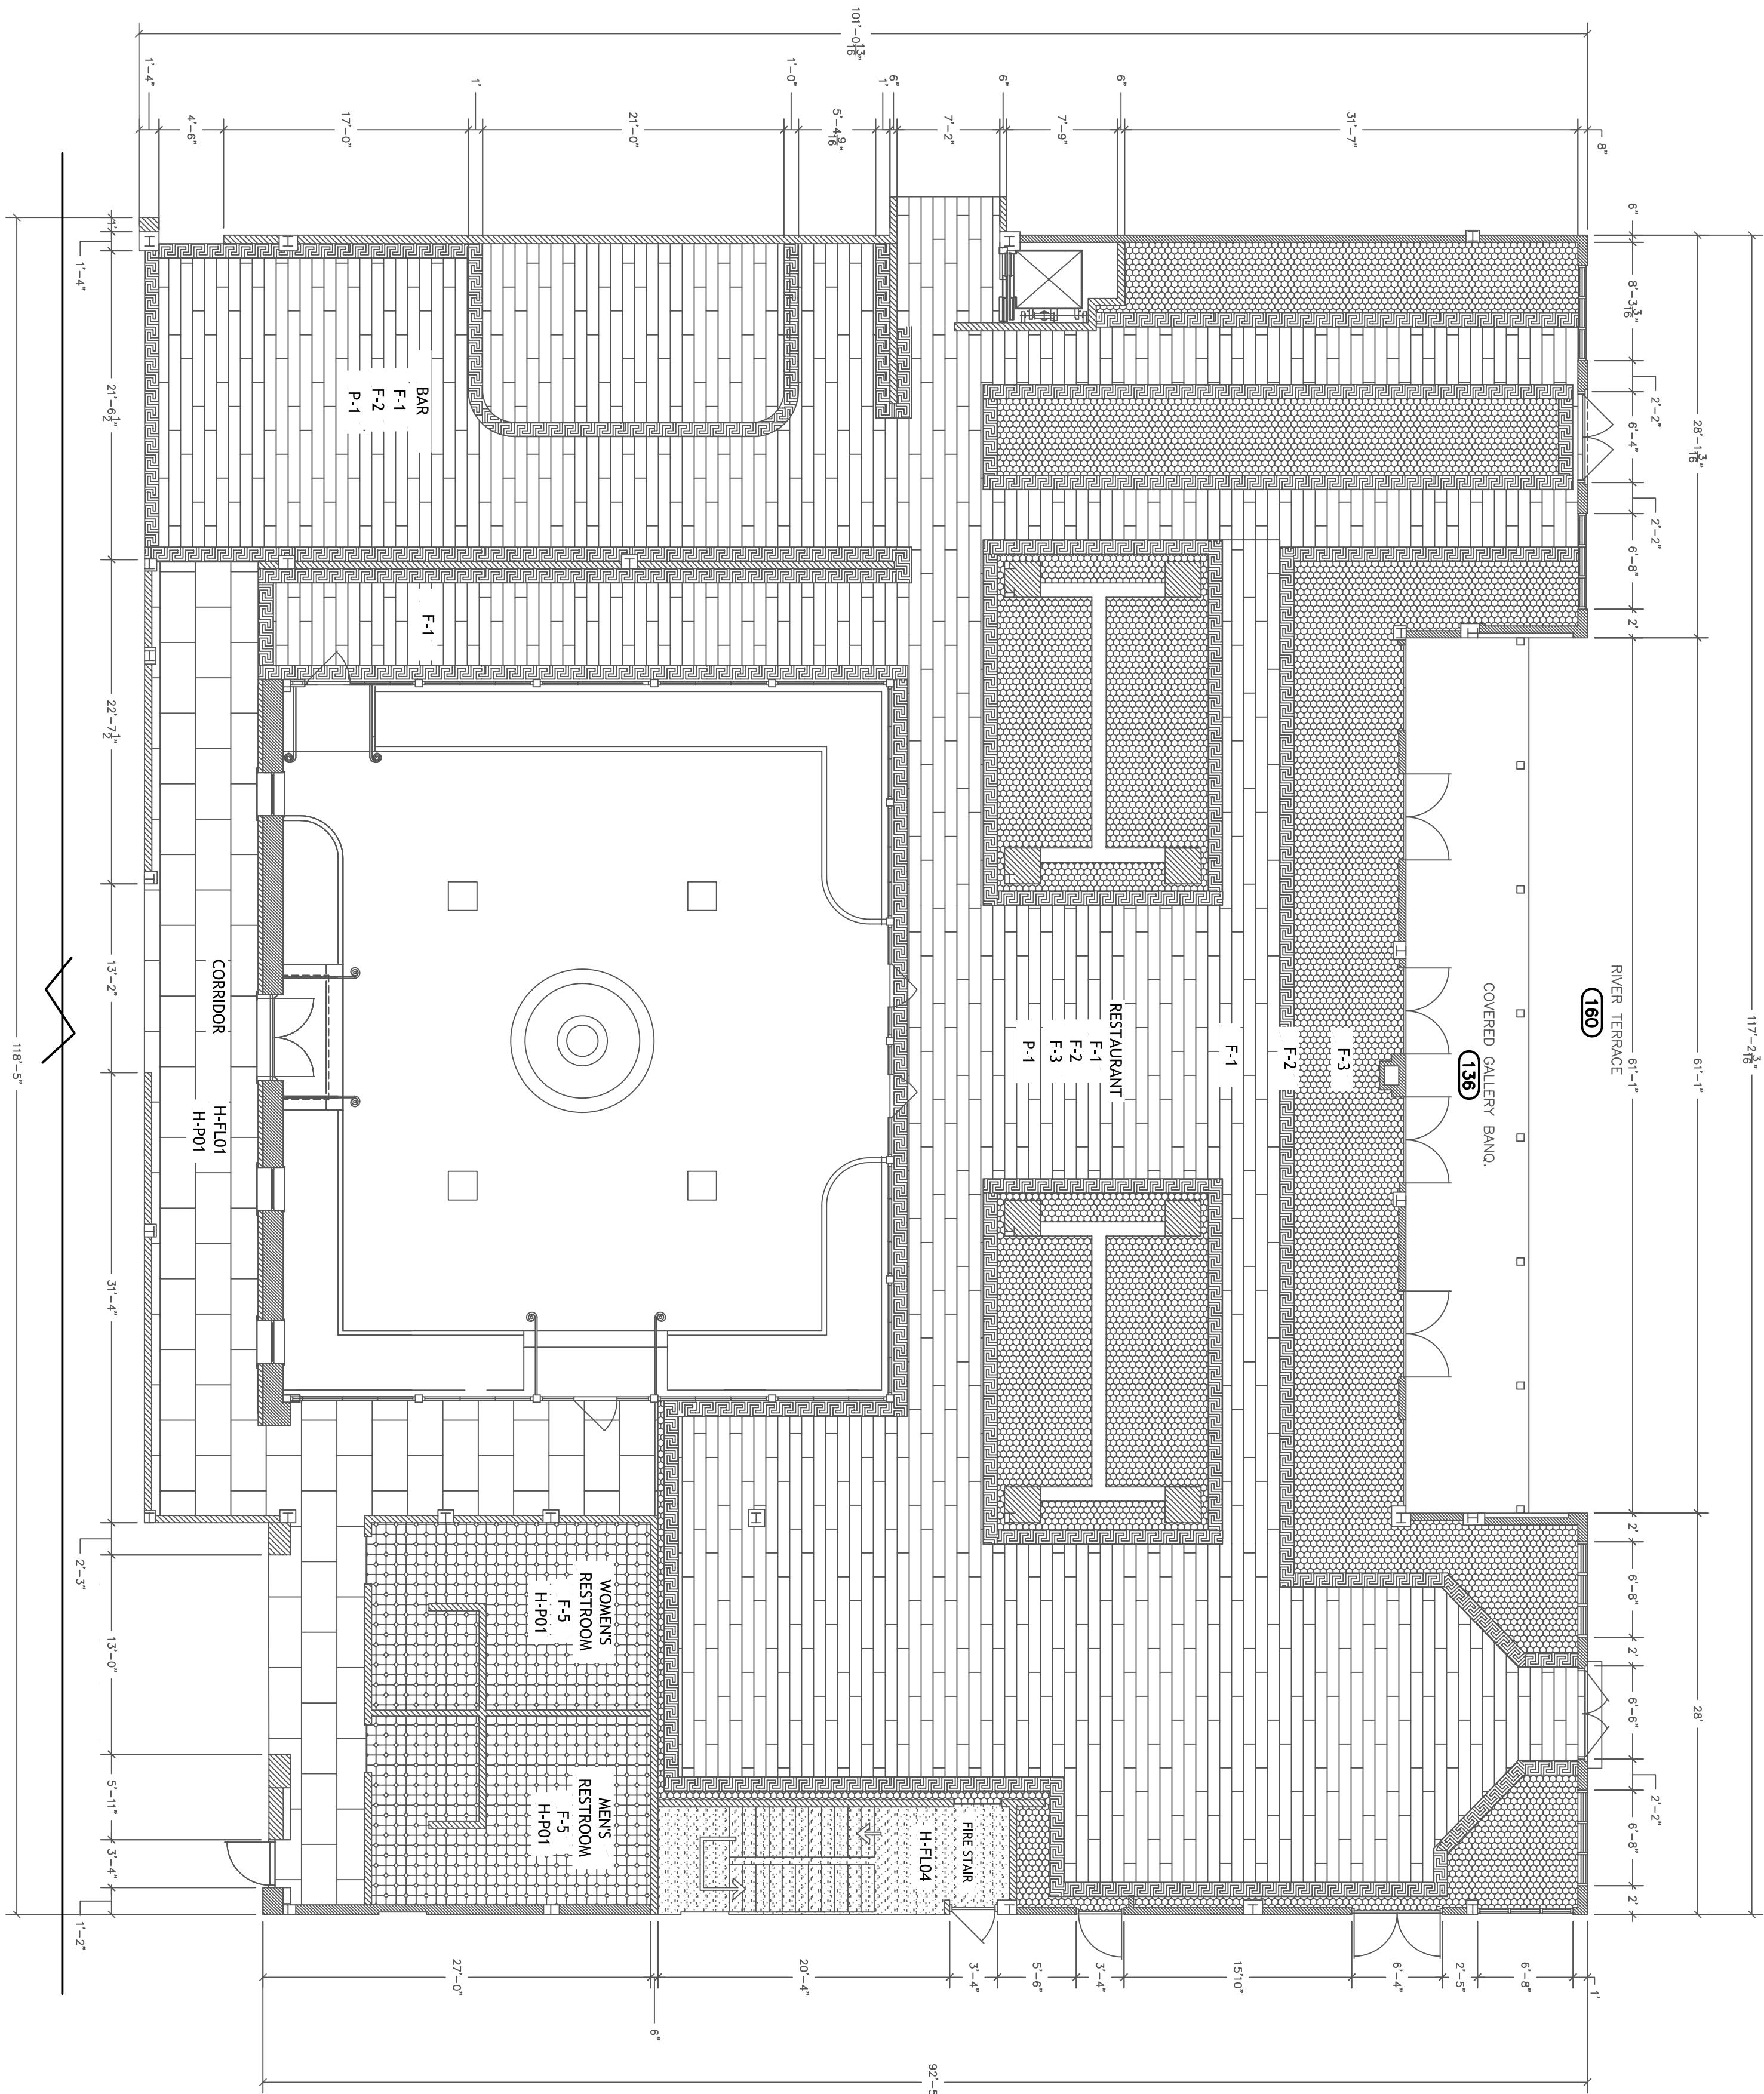

# GALINOIS

## 123 Ocean Drive, Naxos, Cyclades 32480

# Enlarged First Floor Finish Plan / Part A


02:00

$$8\frac{1}{2} = 1.0''$$

Project Number	2000.01
Date	10 April, 2025
Drawn By	Beverly Bradshaw
Checked By	Bethany Blevins

**ID2:00**

UNIVERSITY OF ALABAMA - INTERIOR DESIGN

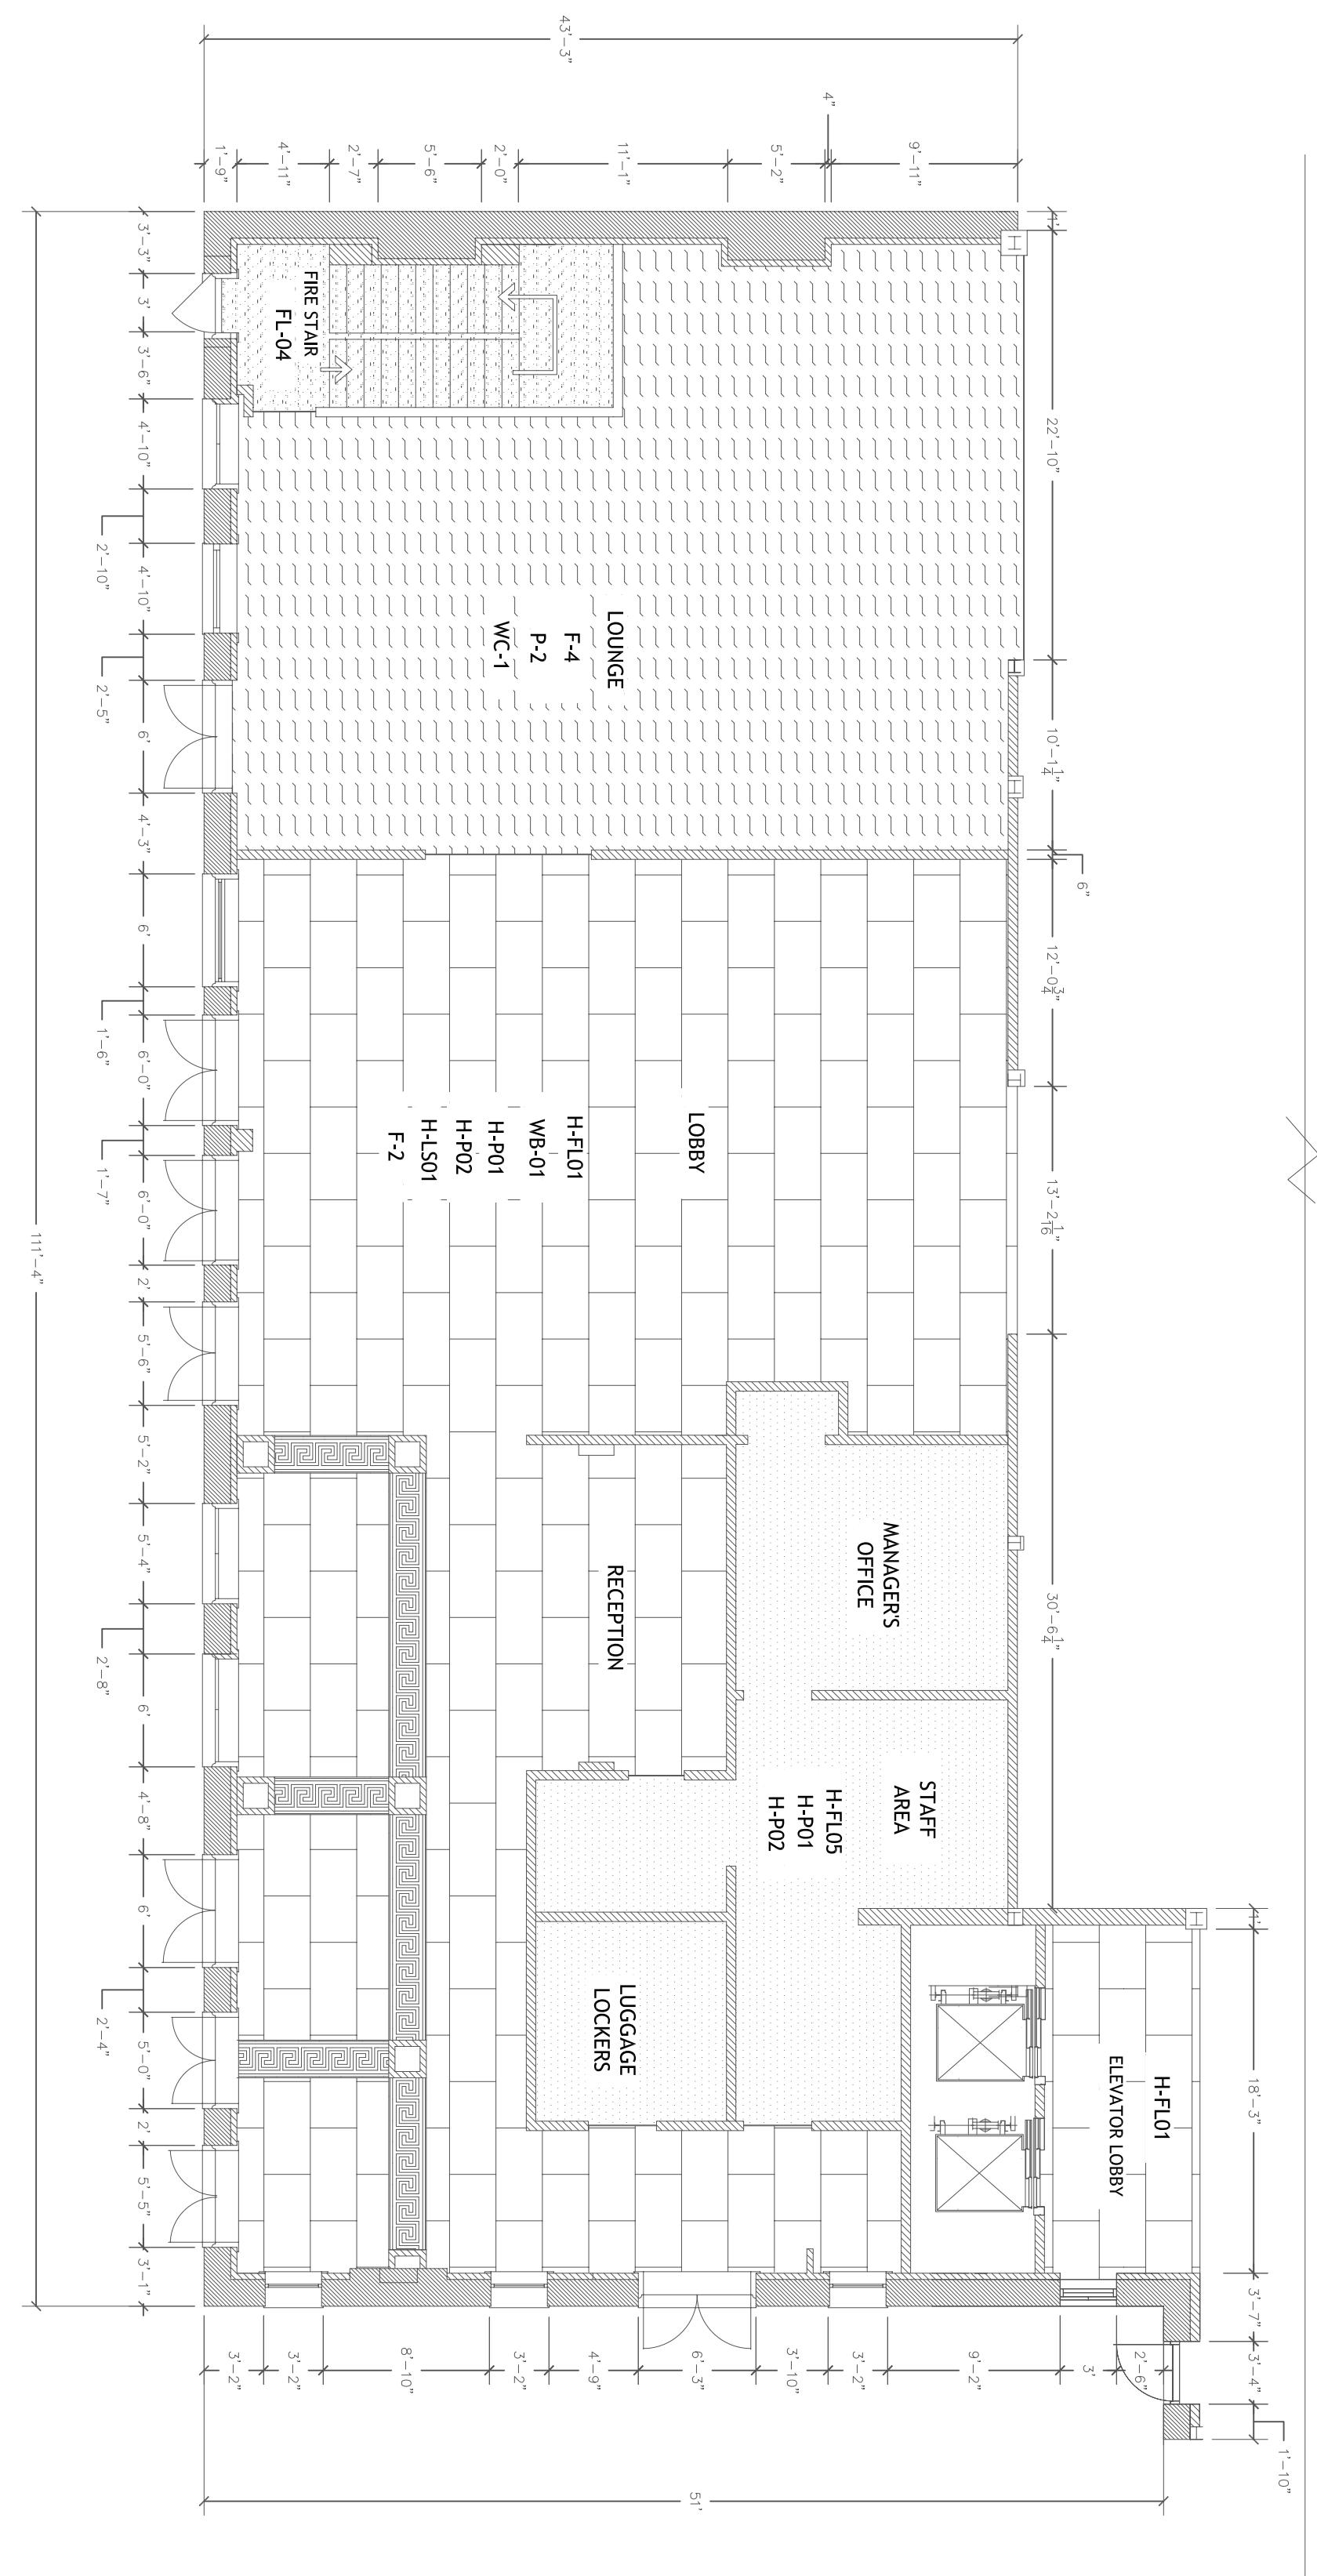

# GALINOIS


123 Ocean Drive,  
Naxos, Cyclades

Enlarged  
First Floor  
Finish Plan /  
Part B

UNIVERSITY OF ALABAMA - INTERIOR DESIGN

BB DESIGN  
BEVERLY BRADSHAW  
2313 ROSEMONT PLACE  
(334)320-1818  
BCBRADSHAW@CRIMSON.UA.EDU

No.      Description      Date

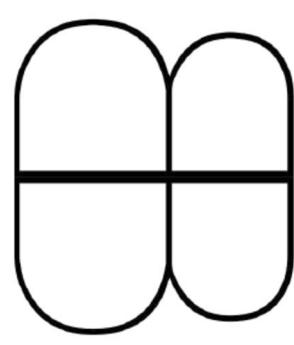

Project Number	2000.01
Drawn By	Beverly Bradshaw
Checked By	Bethany Blevins
Scale	1/8" = 1'-0"

ID2:01



**GALINOIS**  
123 Ocean Drive,  
Naxos, Cyclades  
32480

**Enlarged  
Second Floor  
Finish Plan /  
Part A**

Project Number 2000.01


Drawn By Beverly Bradshaw


Checked By Bethany Blevins

Scale  $\frac{1}{8}$ " = 1'-0"

UNIVERSITY OF ALABAMA - INTERIOR DESIGN


BB DESIGN  
BEVERLY BRADSHAW  
2313 ROSEMONT PLACE  
(334)320-1818  
BCBRADSHAW@CRIMSON.UA.EDU

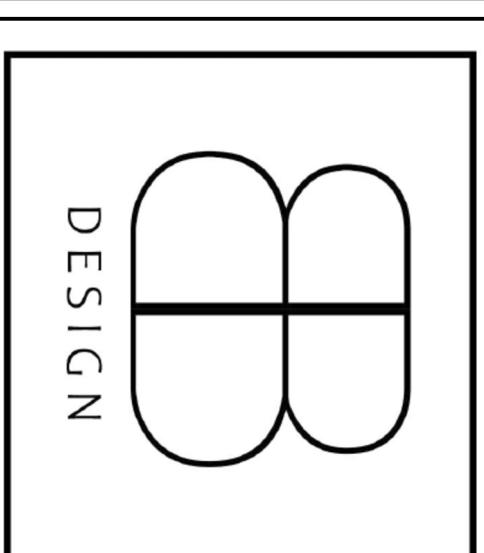

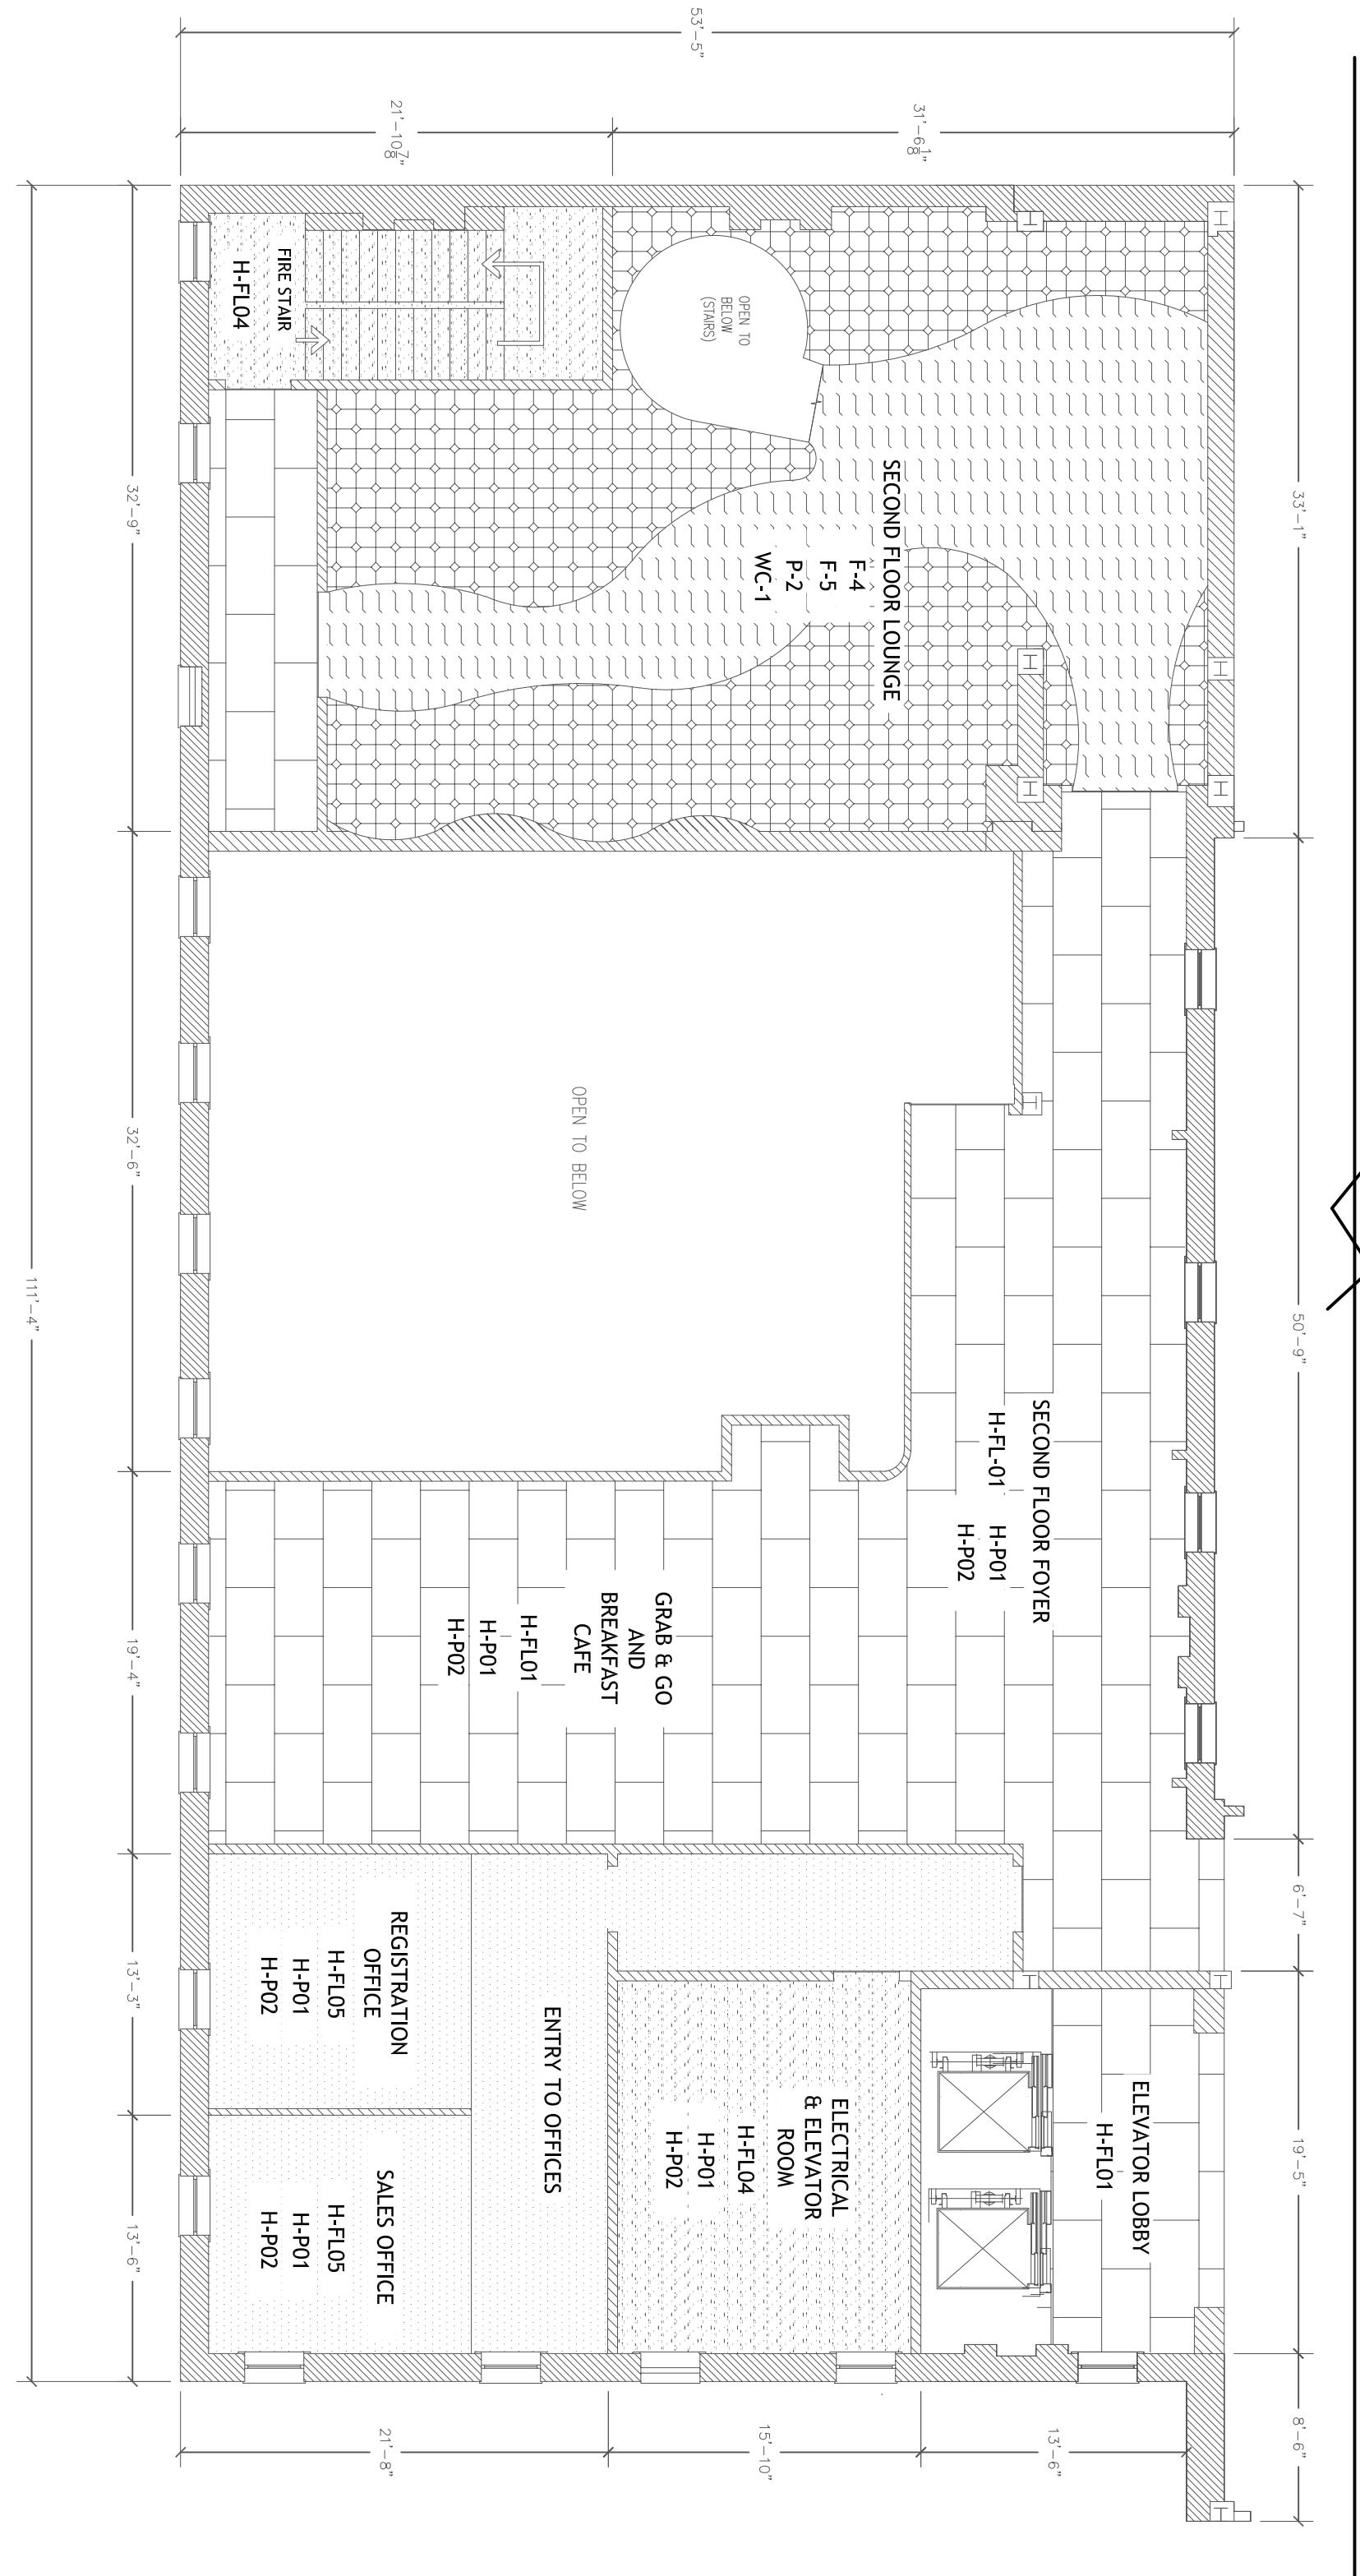

BB DESIGN  
BEVERLY BRADSHAW  
2313 ROSEMONT PLACE  
(334)320-1818  
BCBRADSHAW@CRIMSON.UA.EDU

UNIVERSITY OF ALABAMA - INTERIOR DESIGN

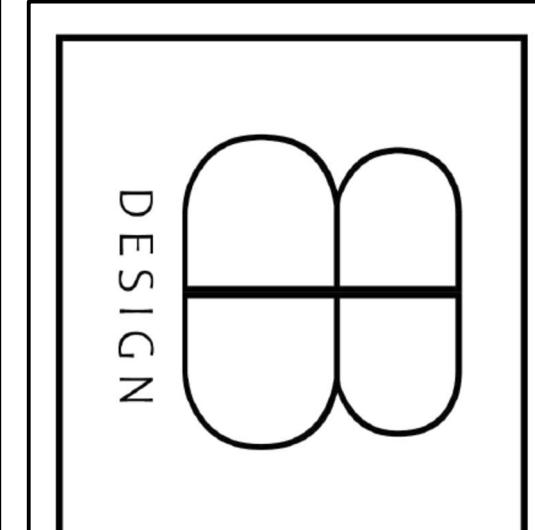


**GALINOIS**  
123 Ocean Drive,  
Naxos, Cyclades  
32480

Enlarged  
Second Floor  
Finish Plan /  
Part B

Project Number	2000.01
Drawn By	10 April, 2025 Beverly Bradshaw
Checked By	Bethany Blevins

**ID2:03**

Scale  
 $\frac{1}{8}$  = 1'-0"

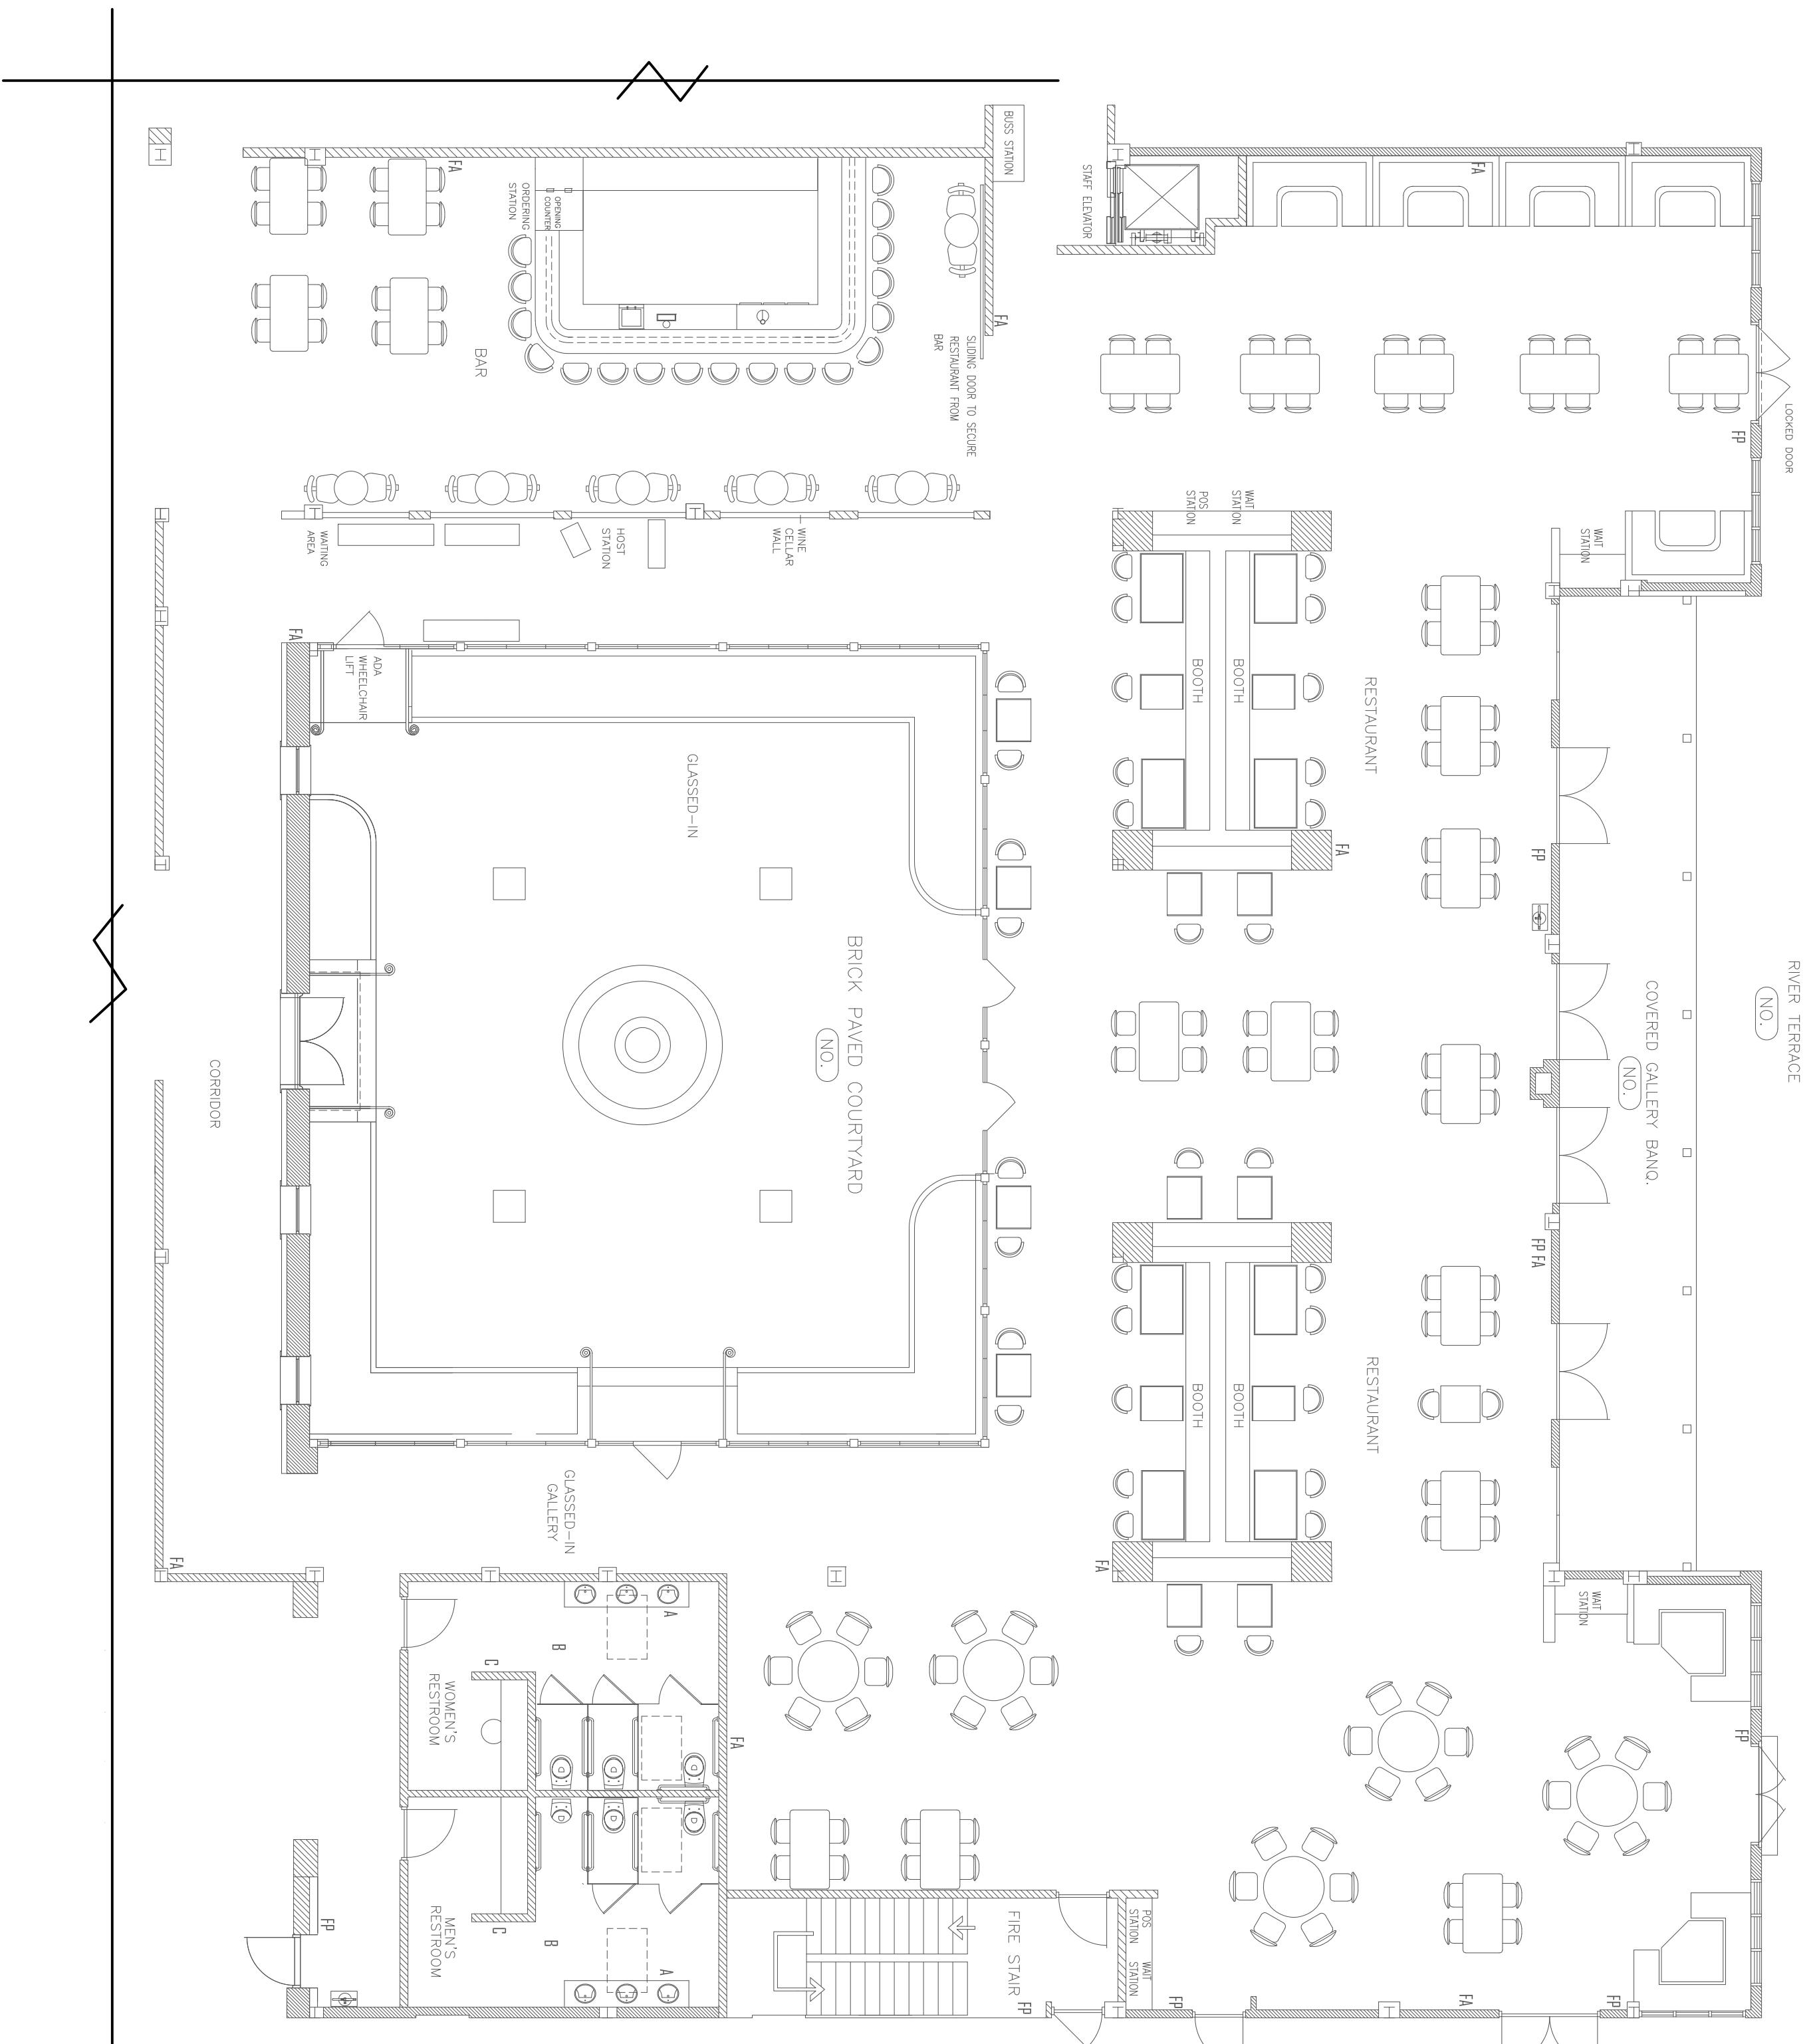

# Naxos, Cyclades 32480

---

## Enlarged First Floor Furniture Plan / Part A

# GALINOS

123 Ocean Drive,  
Naxos, Cyclades

32480

# Enlarged First

# Floor Furniture

## Plan / Part A

Project Number 700001

Date 10 April, 2025  
Drawn By Beverly Bradshaw

**ID 204**      **Checked By** Bethany Blevins


102:04

BEVERLY BRADSHAW  
2313 ROSEMONT PLACE  
(334)320-1818  
PCPRADSHAW@CRIMSON.EDU

UNIVERSITY OF ALABAMA - INTERIOR DESIGN

The logo for Design Within Reach (DWR) is centered on a white background. It features a large, stylized letter 'D' formed by two interlocking, rounded rectangular shapes that resemble a double door or a stylized '8'. To the left of this graphic, the word 'DESIGN' is written vertically in a simple, sans-serif font. The entire logo is contained within a thin black rectangular border.

$$= 1.0''$$

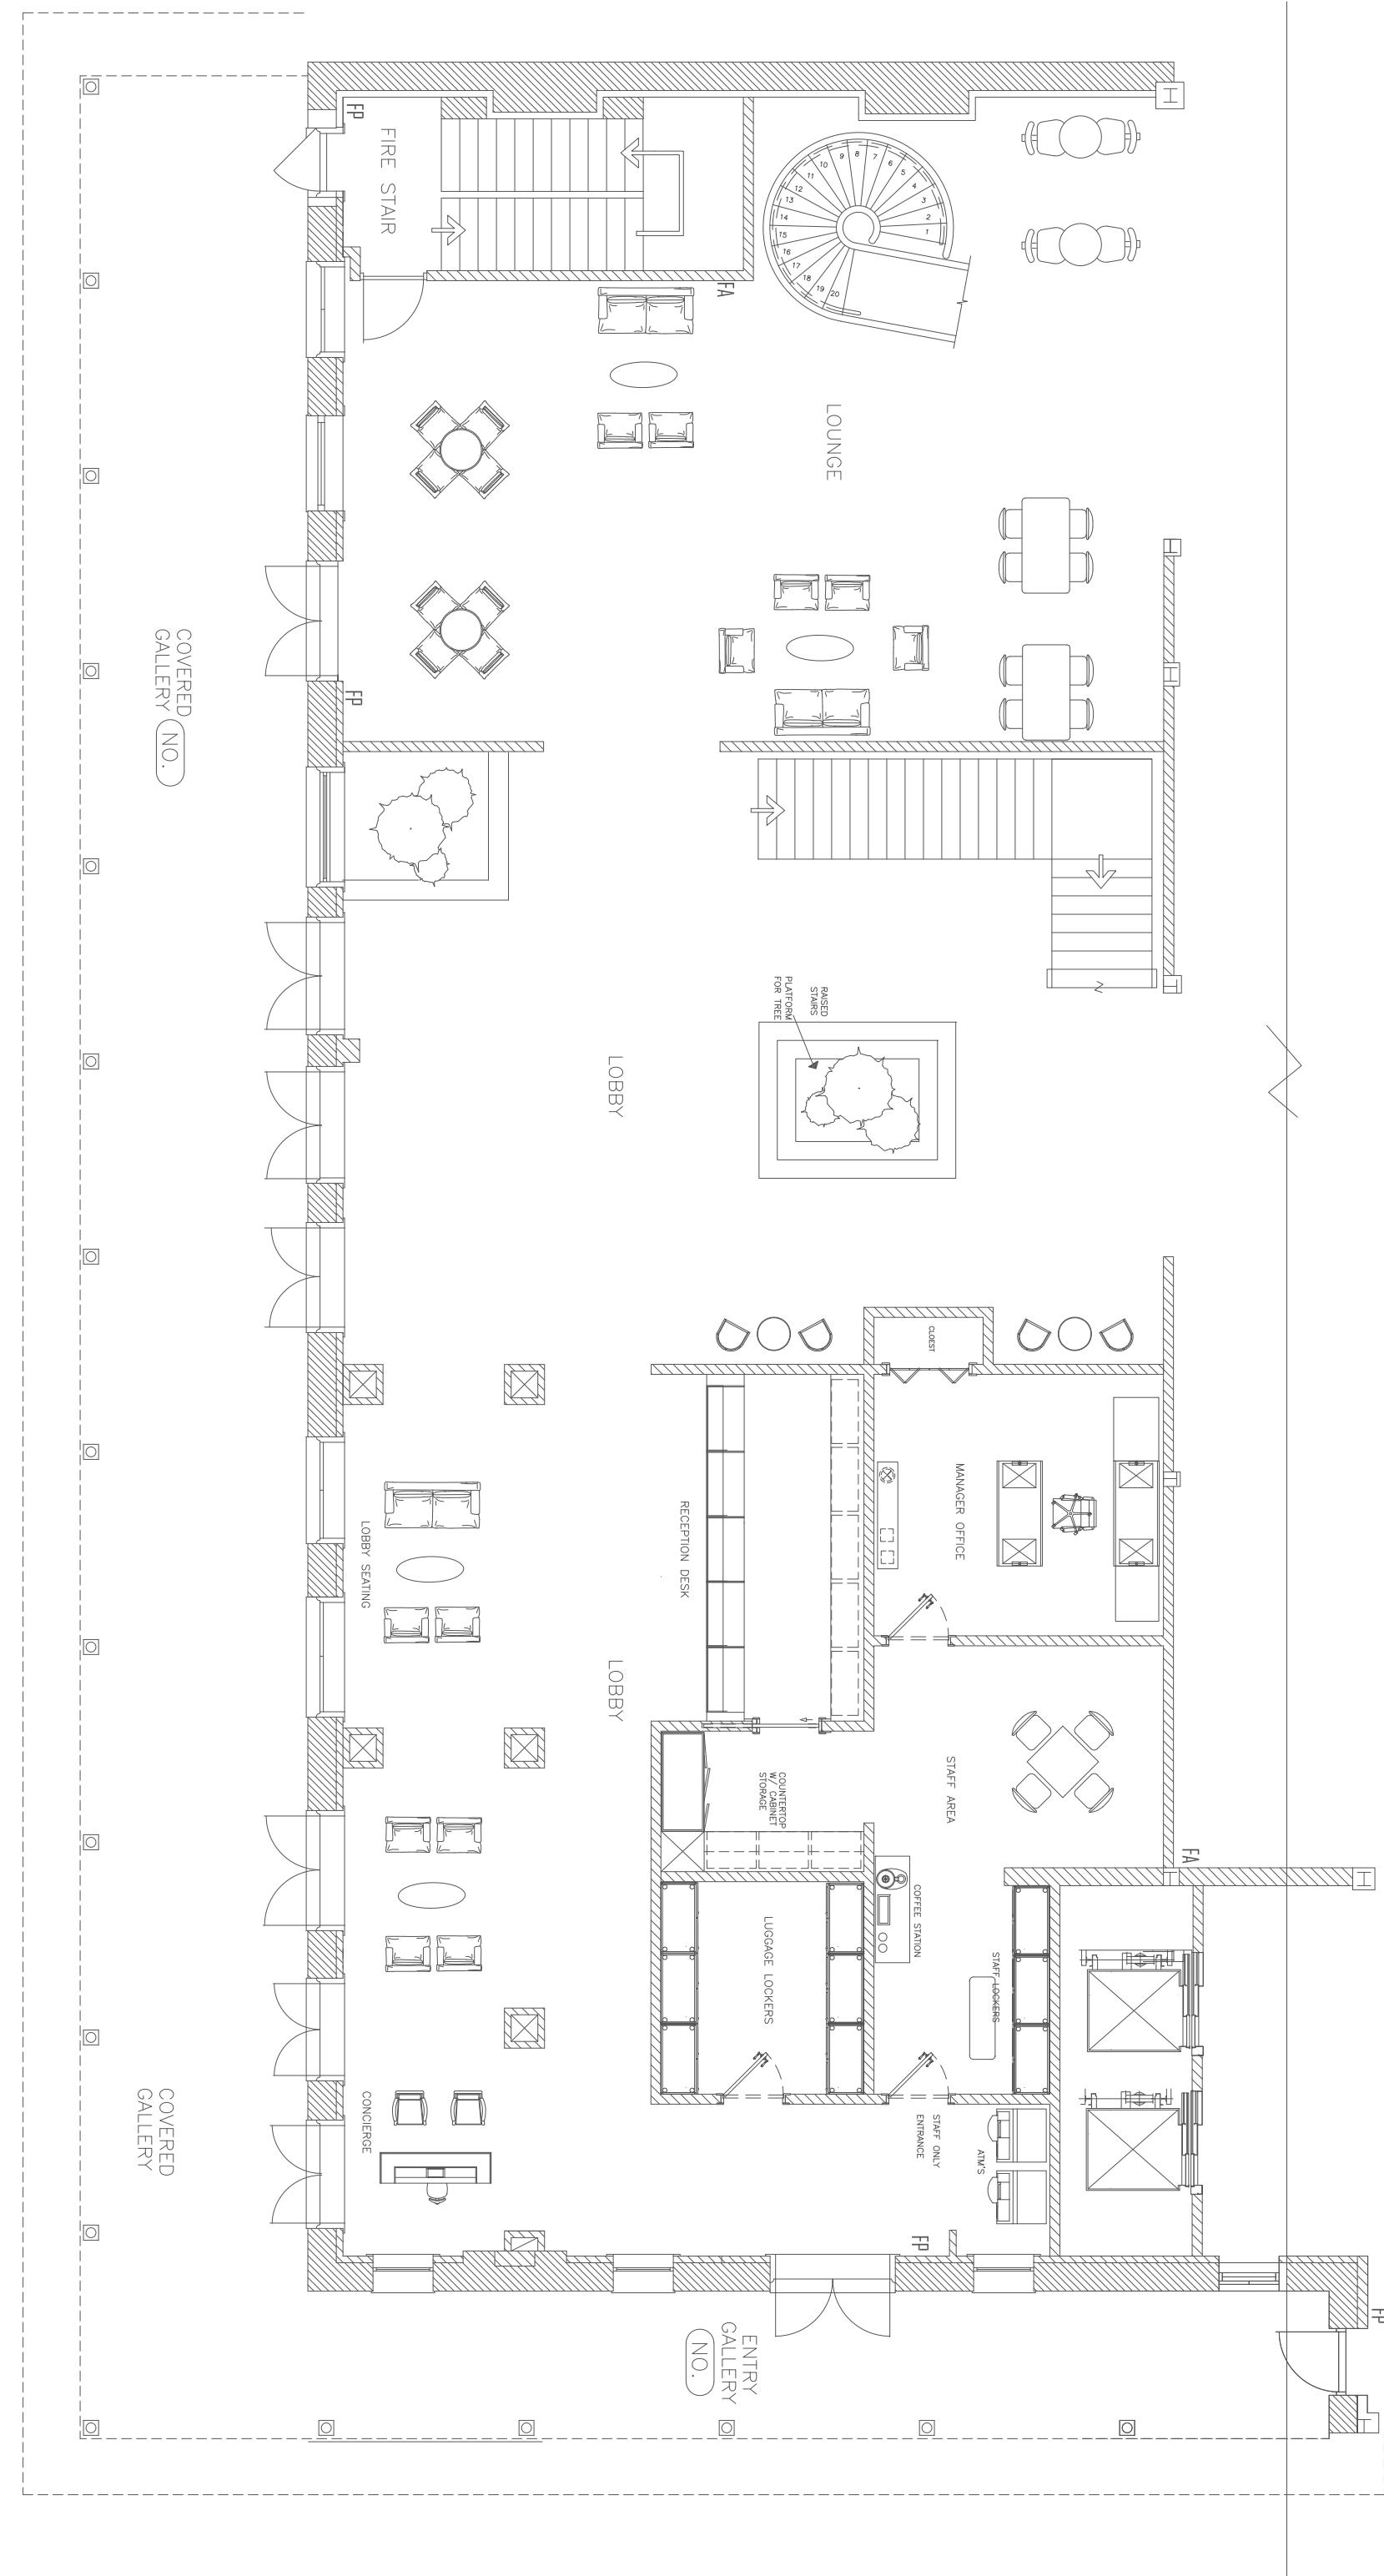

## GALINOIS

123 Ocean Drive,  
Naxos, Cyclades  
32480


## Enlarged First Floor Furniture Plan / Part B


Project Number	2000.01
Drawn By	10 April, 2025 Beverly Bradshaw
Checked By	Bethany Blevins

Scale  
 $\frac{1}{8}$  = 1'-0"

UNIVERSITY OF ALABAMA - INTERIOR DESIGN  
BB DESIGN  
BEVERLY BRADSHAW  
2313 ROSEMONT PLACE  
(334)320-1818  
BCBRADSHAW@CRIMSON.UA.EDU

No.      Description      Date

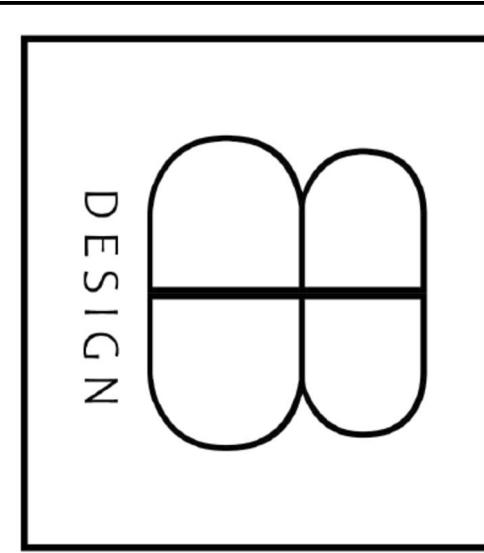

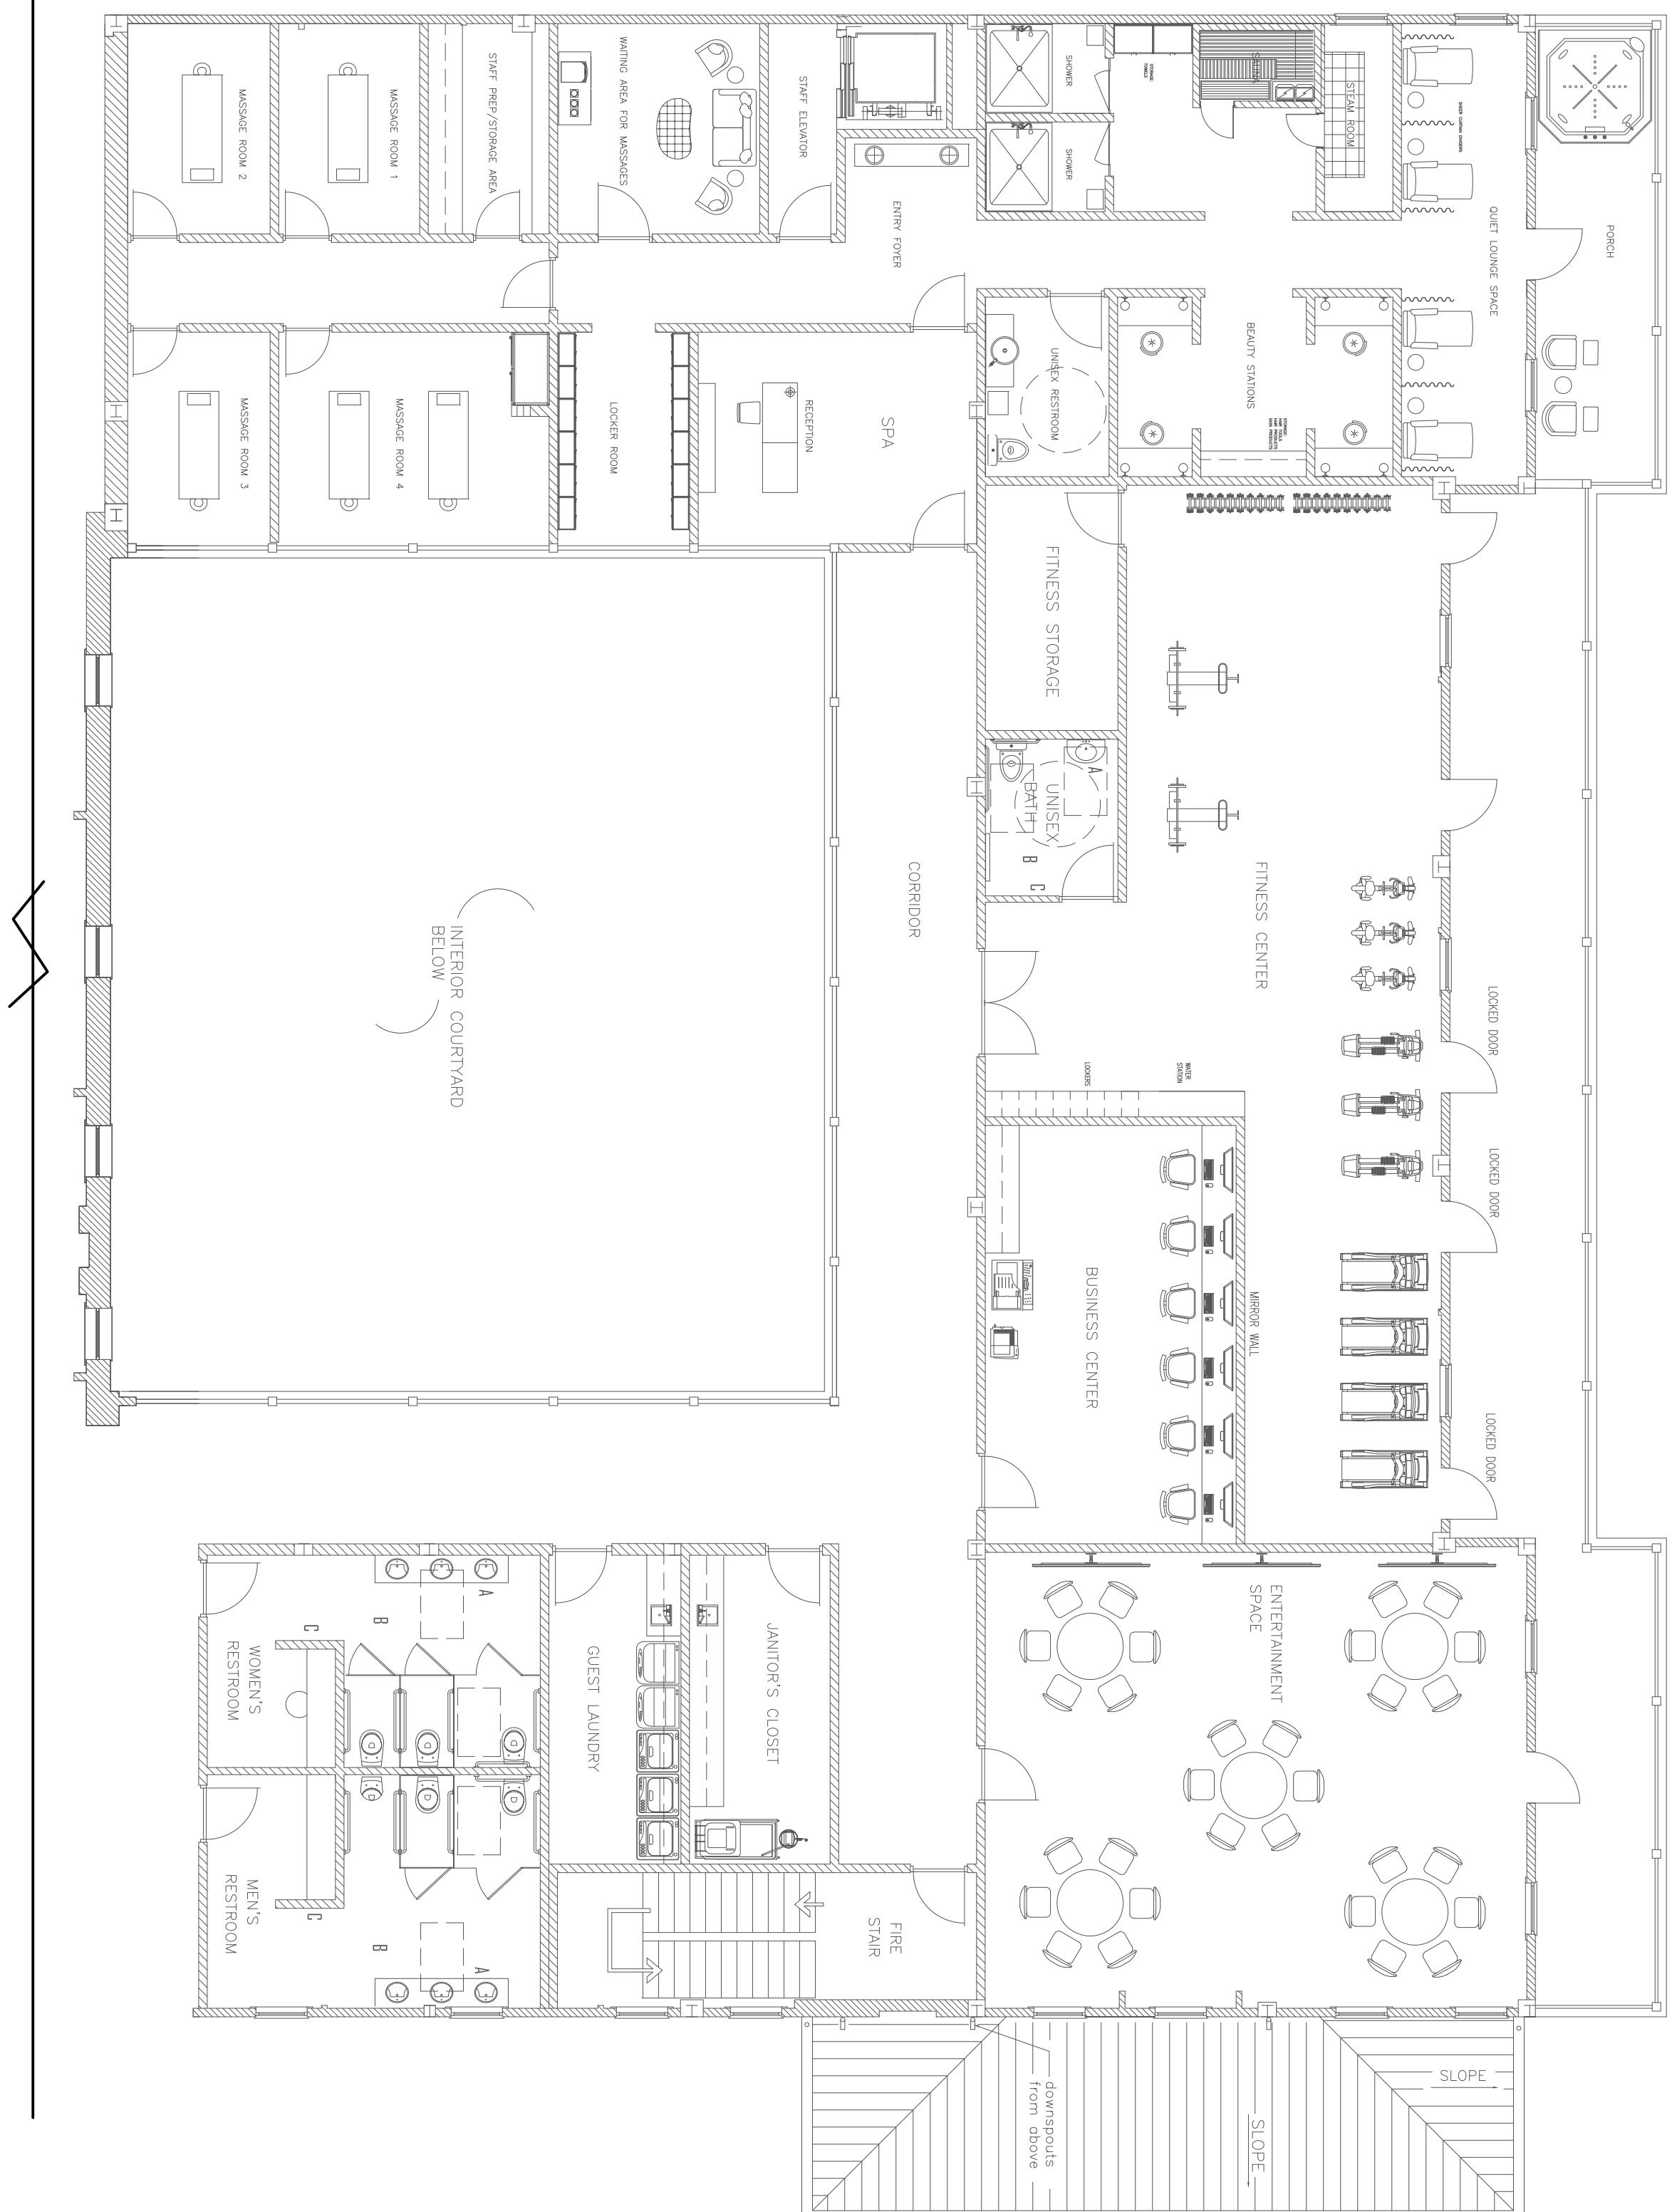


## Enlarged Second Floor Furniture Plan / Part A


Project Number 2000.01  
Drawn By Beverly Bradshaw  
Checked By Bethany Blevins  
10 April, 2025

Scale  $\frac{1}{8} = 1' - 0''$

BB DESIGN  
BEVERLY BRADSHAW  
2313 ROSEMONT PLACE  
(334)320-1818  
BCBRADSHAW@CRIMSON.UA.EDU

UNIVERSITY OF ALABAMA - INTERIOR DESIGN

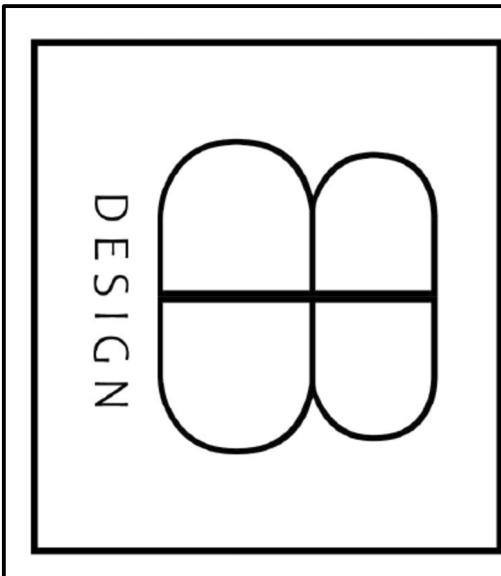

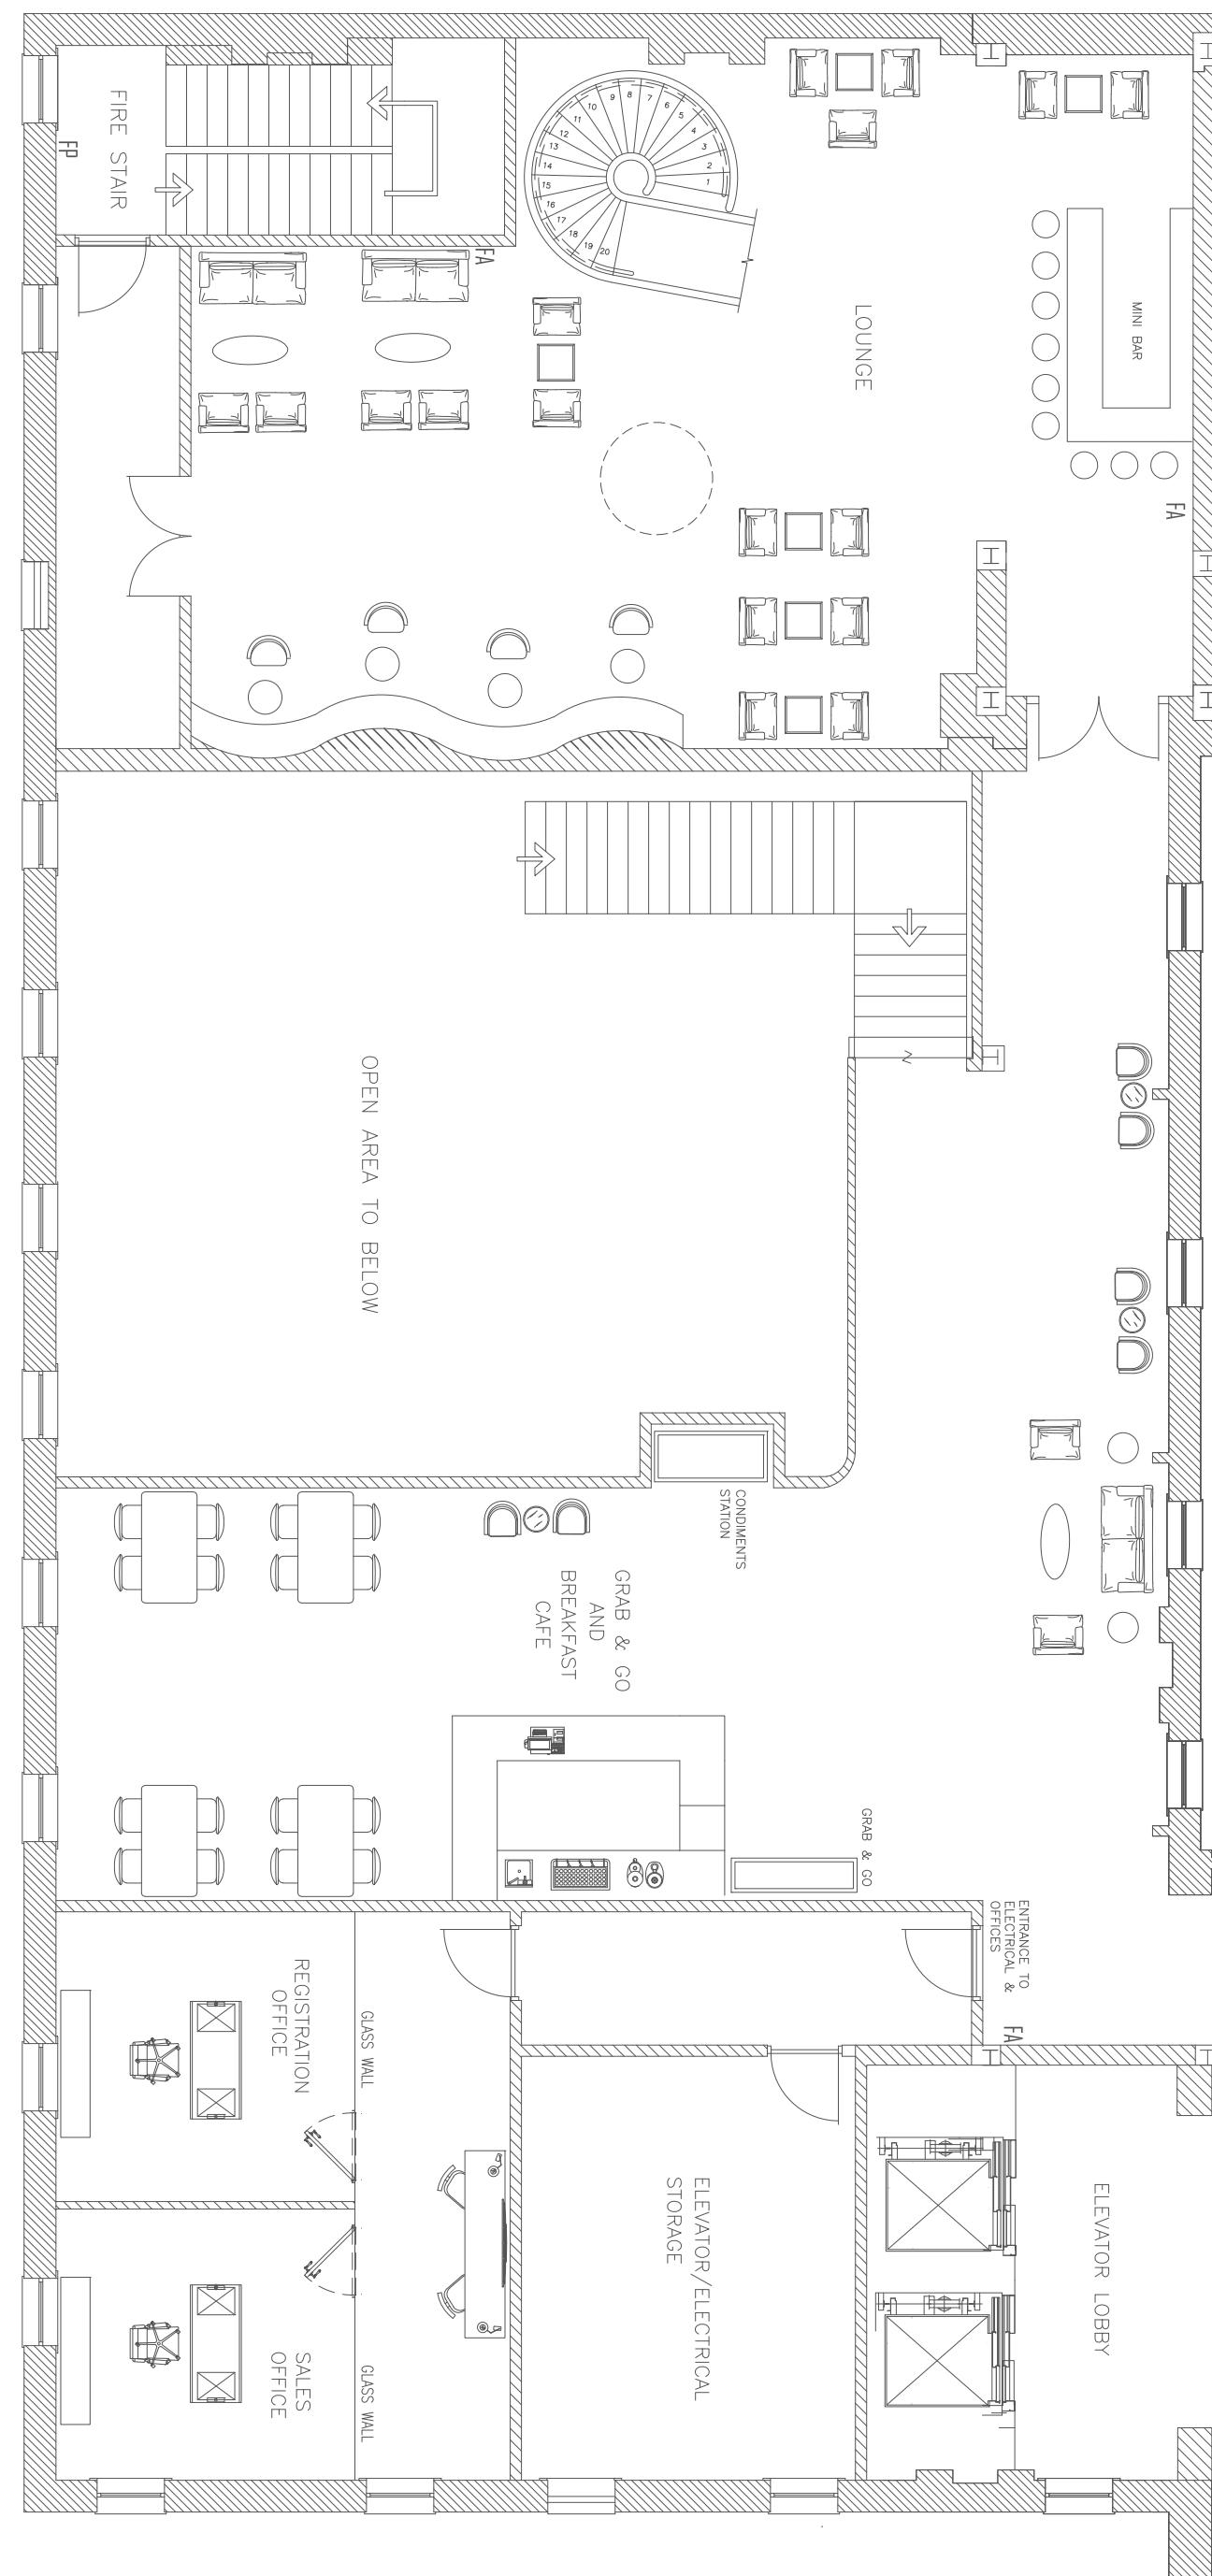

# Enlarged Second Floor Furniture Plan / Part B

---

Project Number      2000

Date      10 April, 2000

Drawn By      Beverly Bradsl

Checked By      Bethany Blew


# ID 2:07

**GALINOIS**  
123 Ocean Drive,  
Naxos, Cyclades  
32480

Project Number	2000.01
Date	10 April, 2025
Drawn By	Beverly Bradshaw
Checked By	Bethany Blevins
<b>ID 2:07</b>	
Scale	$\frac{1}{8}'' = 1'-0''$

BB DESIGN  
BEVERLY BRADSHAW  
2313 ROSEMONT PLACE  
(334)320-1818  
BCBRADSHAW@CRIMSON.UA.EDU

DESIGN

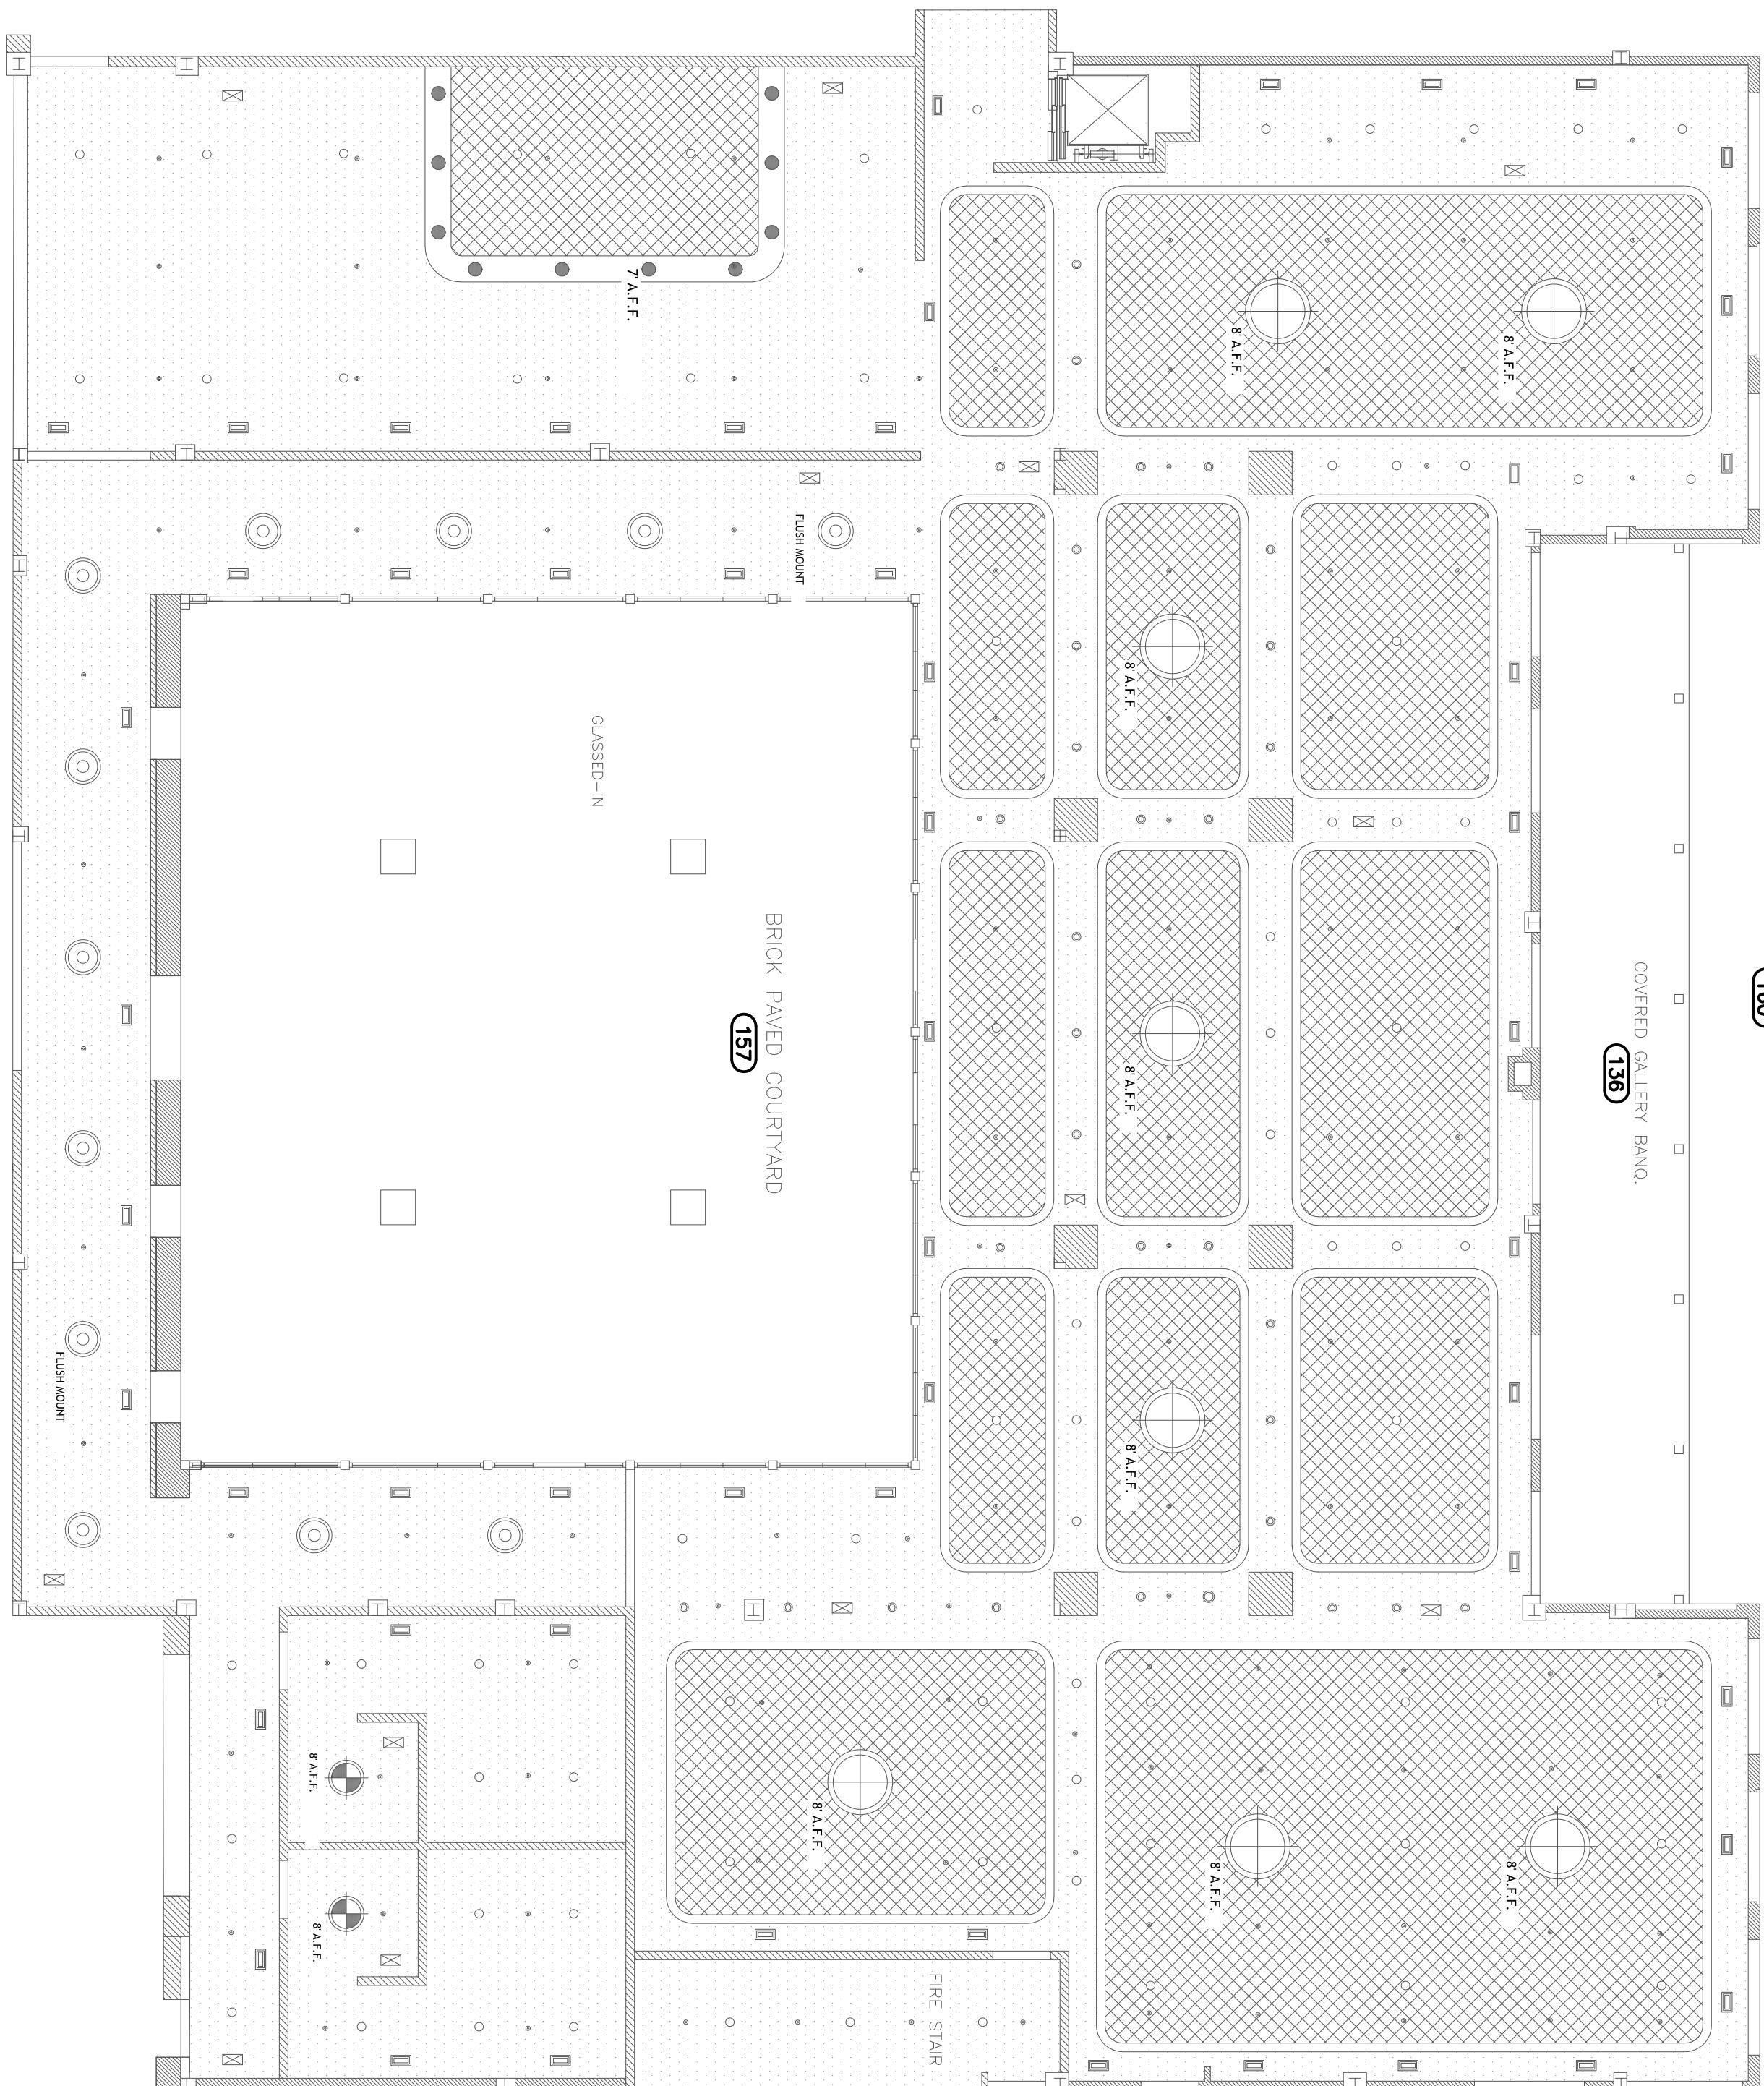

# GALINOIS

123 Ocean Drive,  
Naxos, Cyclades  
32480

# Enlarged First Floor Reflected Ceiling Plan / Part A

Elect. Number: 20000  
Drawn By: Beverly Brad  
Checked By: Bethany Ble  
ID2:08

$$\frac{1}{8}'' = 1'-0''$$


2313 ROSEMONT PLACE  
(334)320-1818  
BCBROADSHAW@CBIMSON.IIA.EDU

UNIVERSITY OF ALABAMA - INTERIOR DESIGN

The logo for DESIGN consists of a stylized double circle, resembling a figure-eight or two joined circles, rendered in black. To the left of this graphic, the word "DESIGN" is written vertically in a bold, sans-serif font, also in black.





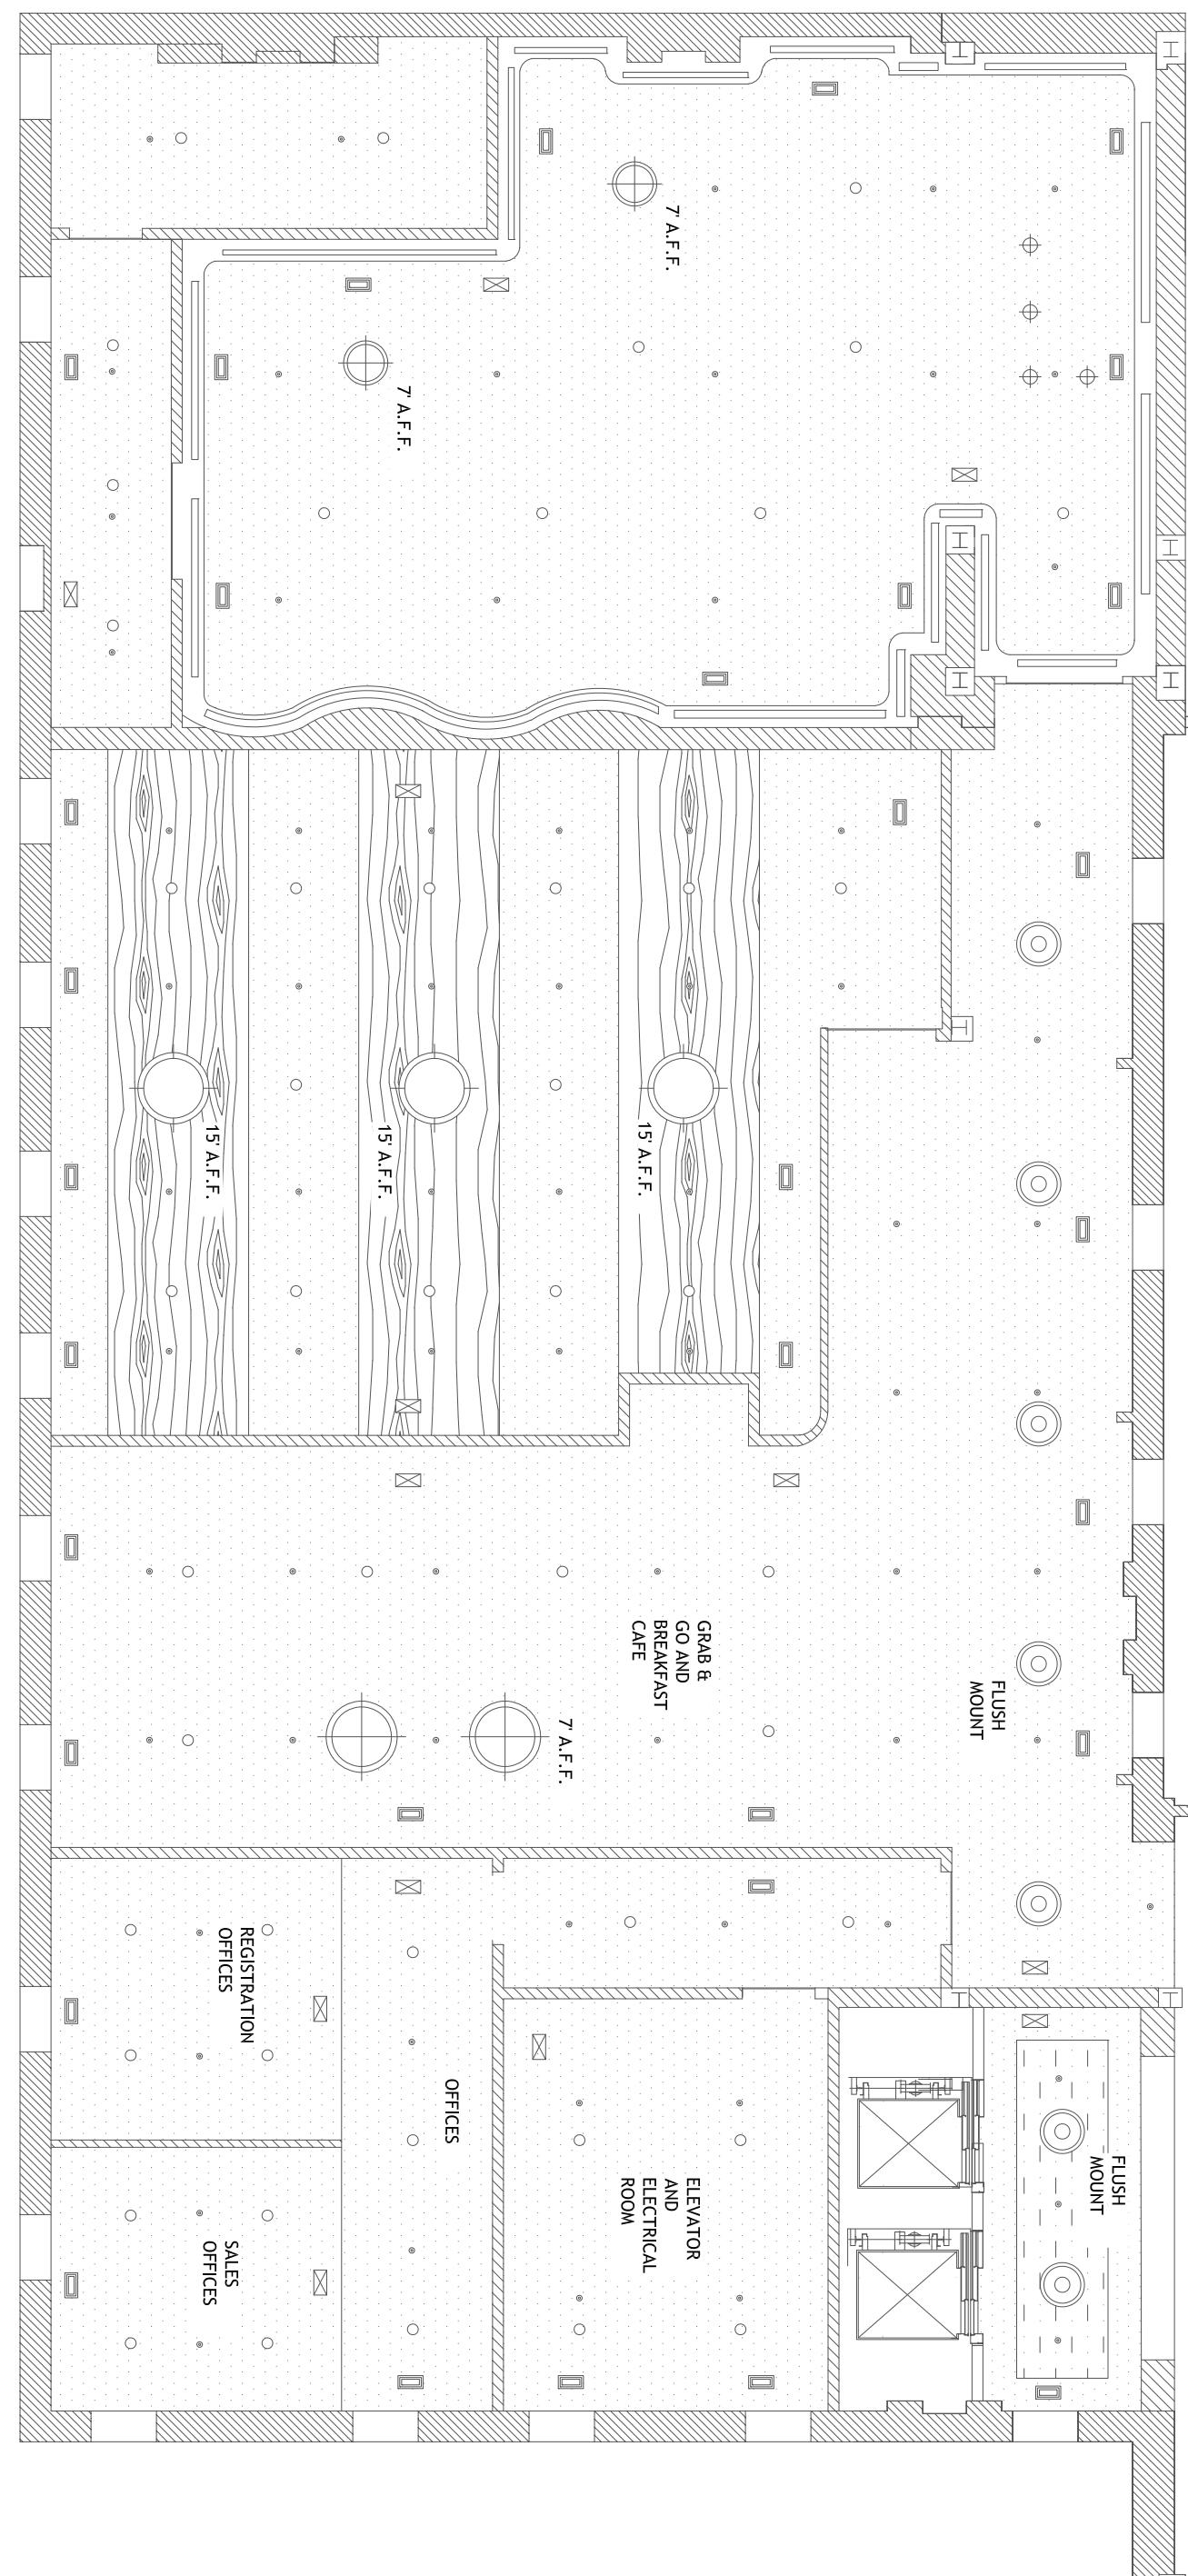


**Enlarged  
Second Floor  
Reflected  
Ceiling Plan /  
Part B**


**GALINOIS**  
123 Ocean Drive,  
Naxos, Cyclades  
32480

Scale  
 $\frac{1}{8}'' = 1'-0''$

**BB DESIGN**  
BEVERLY BRADSHAW  
2313 ROSEMONT PLACE  
334)320-1818  
BCBRADSHAW@CRIMSON.UA.EDU

UNIVERSITY OF ALABAMA - INTERIOR DESIGN


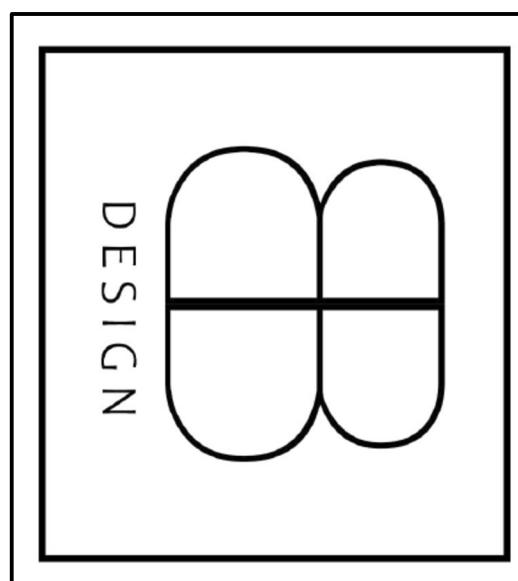


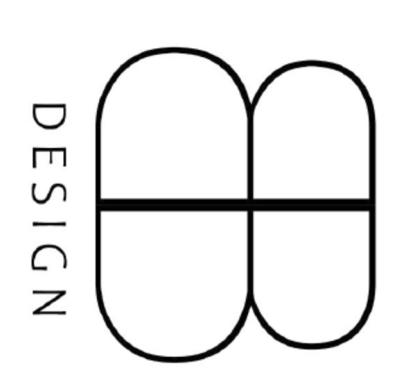

FFE LEGEND	
H-01	TOILET
H-02	FREE STANDING TUB
H-03	SHOWER HEAD KIT
H-04	BATH TUB KIT
H-05	SINK FAUCET
H-06	DROP IN TUB
H-07	MINI FRIDGE
H-08	TV
H-09	SINGLE VANITY
H-10	QUEEN BED SET
H-11	KING BED SET
H-12	BEDSIDE TABLE
H-13	TV UNIT
H-14	DINING TABLE
H-15	SIDE TABLE
H-16	ACCENT TABLE
H-17	DESK
H-18	CUSTOM CABINET UNIT
H-19	COFFEE TABLE
H-20	WALL ART 3
H-21	END TABLE
H-22	SIDE CHAIR
H-23	UPHOLSTERED BENCH
H-24	LARGE SOFA
H-25	SMALL SOFA
H-26	SIDE CHAIR 2
H-27	LOUNGE CHAIR
H-28	DINGING CHAIR
H-29	QUEEN MATTRESS
H-30	KING MATTRESS
H-31	QUEEN DUVET COVER/SHAMS
H-32	KING DUVET COVER/SHAMS
H-33	FULL LENGTH MIRROR
H-34	CUSTOM BATH MIRROR
H-35	WALL ART 1
H-36	WALL ART 2
H-37	CIRCULAR MIRROR
H-38	QUEEN MATTRESS
H-39	KING MATTRESS
H-40	QUEEN DUVET COVER/SHAMS
H-41	KING DUVET COVER/SHAMS
H-42	FULL LENGTH MIRROR
H-43	CUSTOM BATH MIRROR
H-44	WALL ART 1
H-45	WALL ART 2
H-46	CIRCULAR MIRROR
H-47	QUEEN MATTRESS
H-48	KING MATTRESS
H-49	QUEEN DUVET COVER/SHAMS
H-50	KING DUVET COVER/SHAMS



No.	Description	Date

**BB DESIGN**  
BEVERLY BRADSHAW  
2313 ROSEBROOK PLACE  
(334)320-1818  
BCBRADSHAW@CRIMSON.UA.EDU

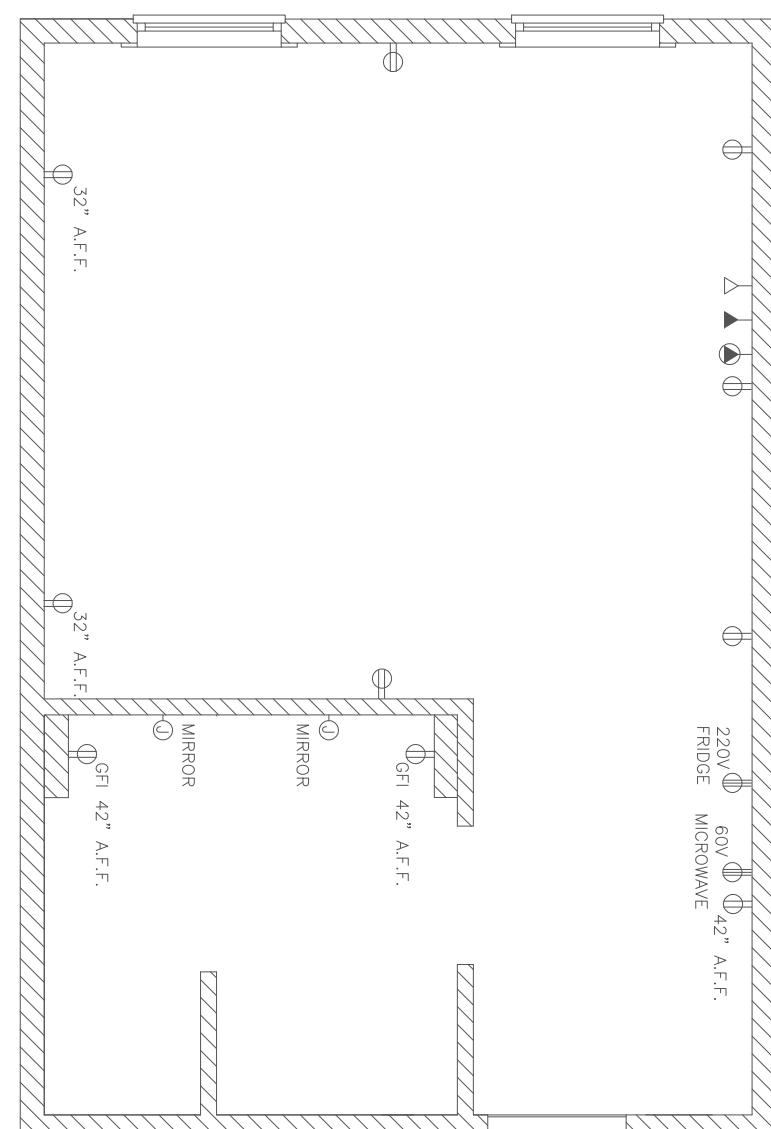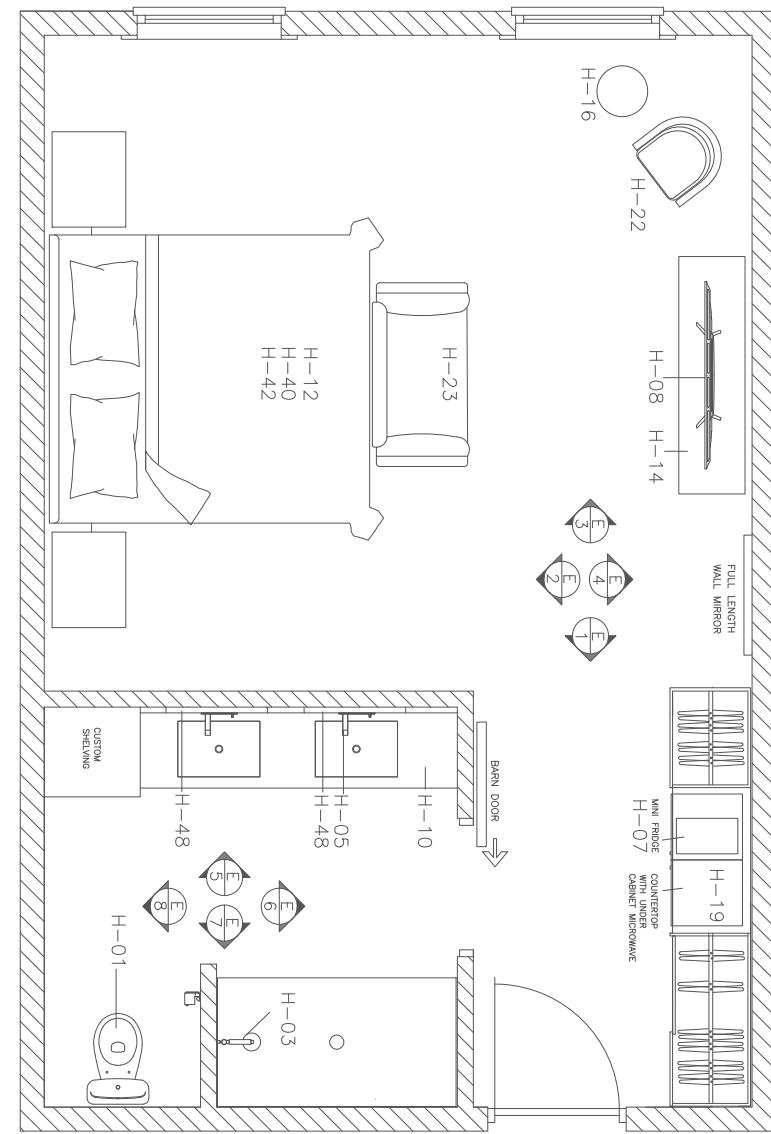



ELECTRICAL LEGEND	
⊖	DUPLEX CONVENIENCE OUTLET
⊖	GFI OUTLET
⊖	220V OUTLET
⊖	60V OUTLET
⊖	JUNCTION BOX
⊖	TELEPHONE
⊖	CABLE
⊖	INTERNET

NOTES:  
UNLESS OTHERWISE NOTED, ALL  
OUTLETS ARE 15 A.F.F. STANDARD  
AND 18 A.F.F. IN ADA ROOMS

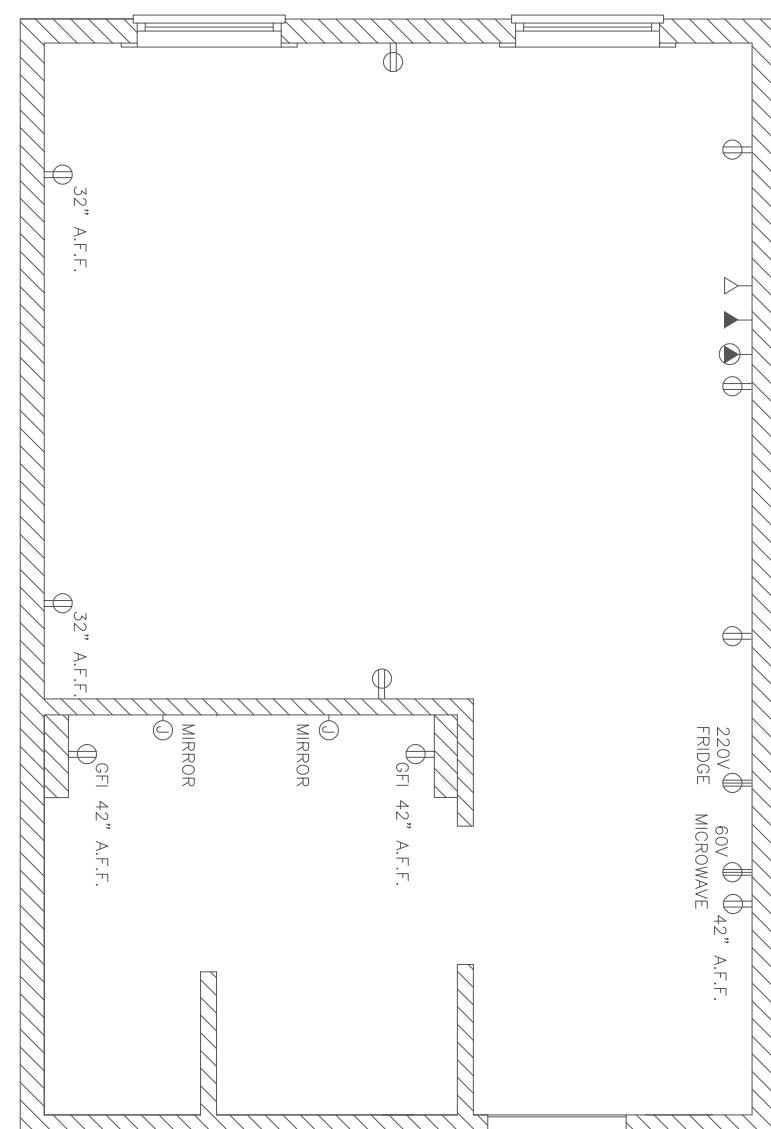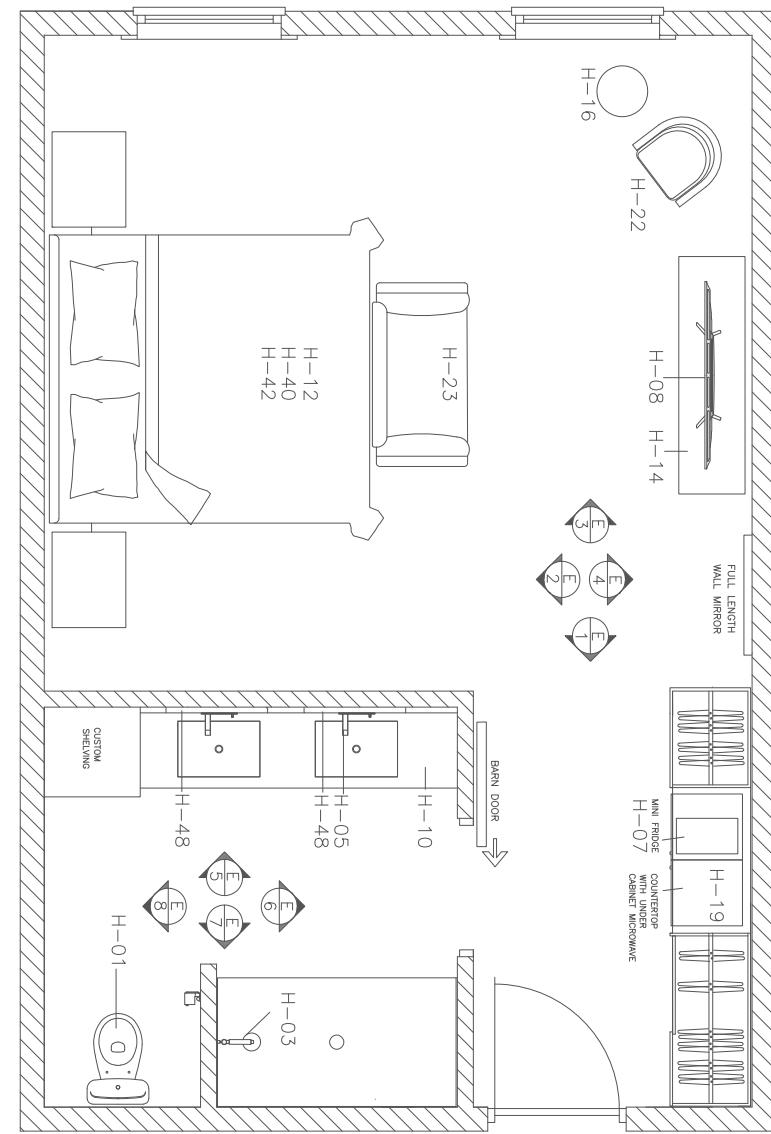

ELECTRICAL LEGEND	
⊖	H-30 HANGING PENDANT LIGHT
⊖	H-32 LARGE HANGING PENDANT
⊖	H-34 6" RECESSED CAN LIGHT
⊖	H-35 4" RECESSED CAN LIGHT
⊖	H-36 LED STRIP LIGHT
⊖	H-37 DINING TABLE CHANDELIER
⊖	H-38 FIRE SPRINKLER
⊖	H-39 HVAC SUPPLY VENT
⊖	H-40 HVAC RETURN VENT
⊖	H-41 EXHAUST FAN
⊖	H-42 8' HANGING PENDANT
⊖	H-43 CEILING FLUSH PENDANT
⊖	H-44 10" HANGING PENDANT
⊖	H-45 LARGE CHANDELIER
⊖	H-46 RETRO CHANDELIER

NOTES:  
UNLESS OTHERWISE NOTED, ALL  
OUTLETS ARE 15 A.F.F. STANDARD  
AND 18 A.F.F. IN ADA ROOMS

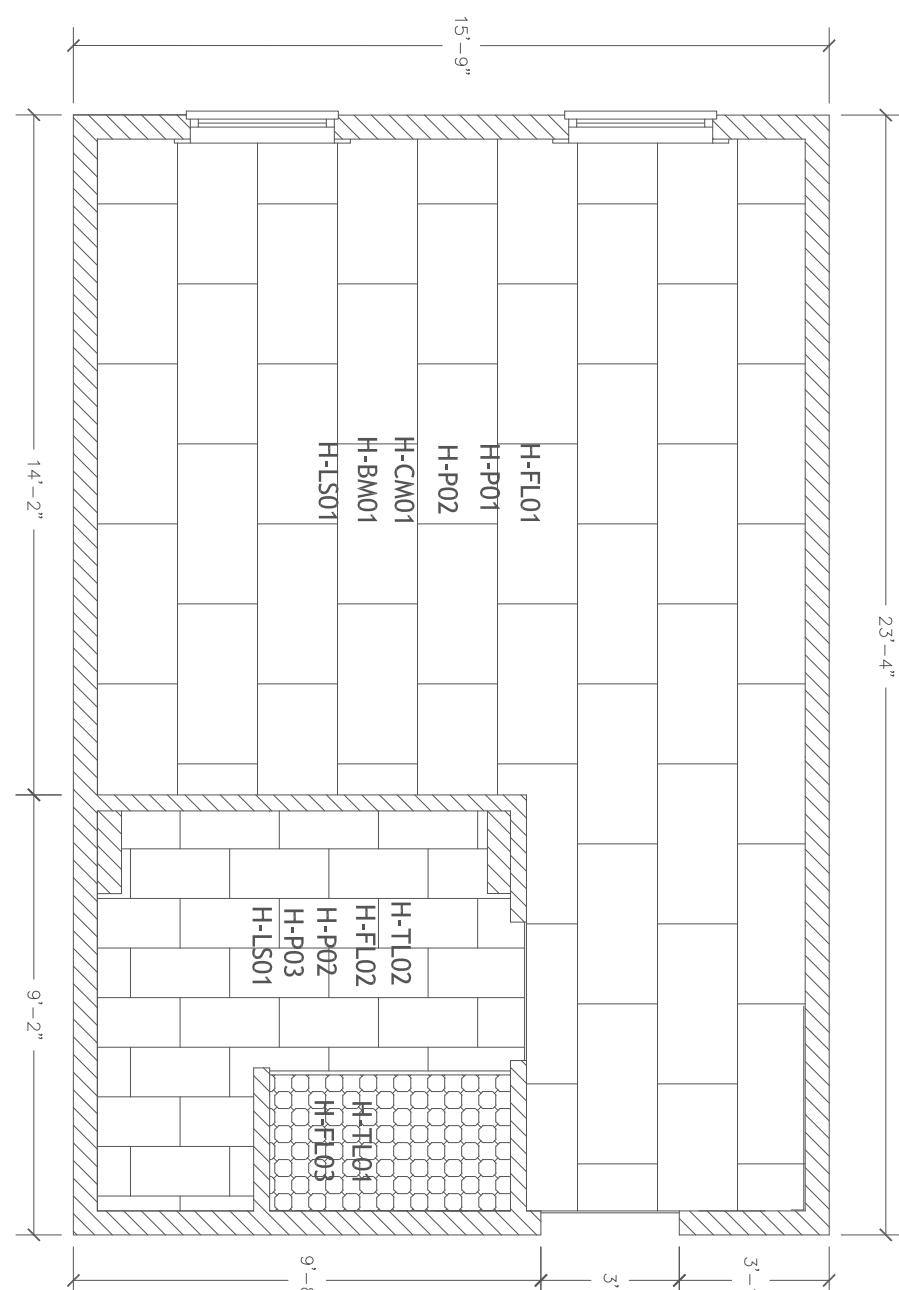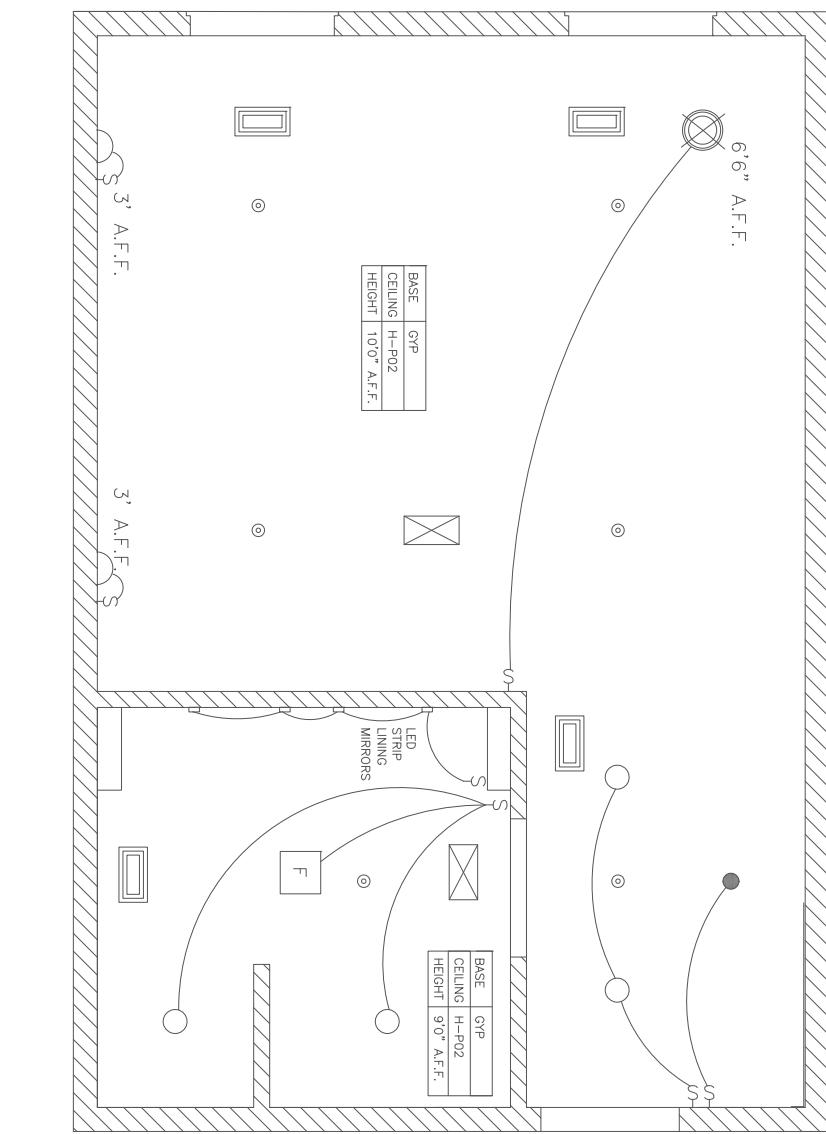

RCP LEGEND	
⊖	H-30 HANGING PENDANT LIGHT
⊖	H-32 LARGE HANGING PENDANT
⊖	H-34 6" RECESSED CAN LIGHT
⊖	H-35 4" RECESSED CAN LIGHT
⊖	H-36 LED STRIP LIGHT
⊖	H-37 DINING TABLE CHANDELIER
⊖	H-38 FIRE SPRINKLER
⊖	H-39 HVAC SUPPLY VENT
⊖	H-40 HVAC RETURN VENT
⊖	H-41 EXHAUST FAN
⊖	H-42 8' HANGING PENDANT
⊖	H-43 CEILING FLUSH PENDANT
⊖	H-44 10" HANGING PENDANT
⊖	H-45 LARGE CHANDELIER
⊖	H-46 RETRO CHANDELIER

**GALINOIS**  
123 Ocean Drive,  
Naxos, Cyclades  
32480

Enlarged  
King

Guestroom  
Floor Plans

**TYPICAL KING GUESTROOM**  
**REFLECTED CEILING PLAN**  
SCALE: 1/4"=1'-0"


**TYPICAL KING GUESTROOM**  
**FINISH PLAN**  
SCALE: 1/4"=1'-0"

Project Number 2000.01  
Date 10 April, 2025  
Drawn By Beverly Bradshaw  
Checked By Bethany Blevins

Scale 1/4"=1'-0"

1/4"=1'-0"




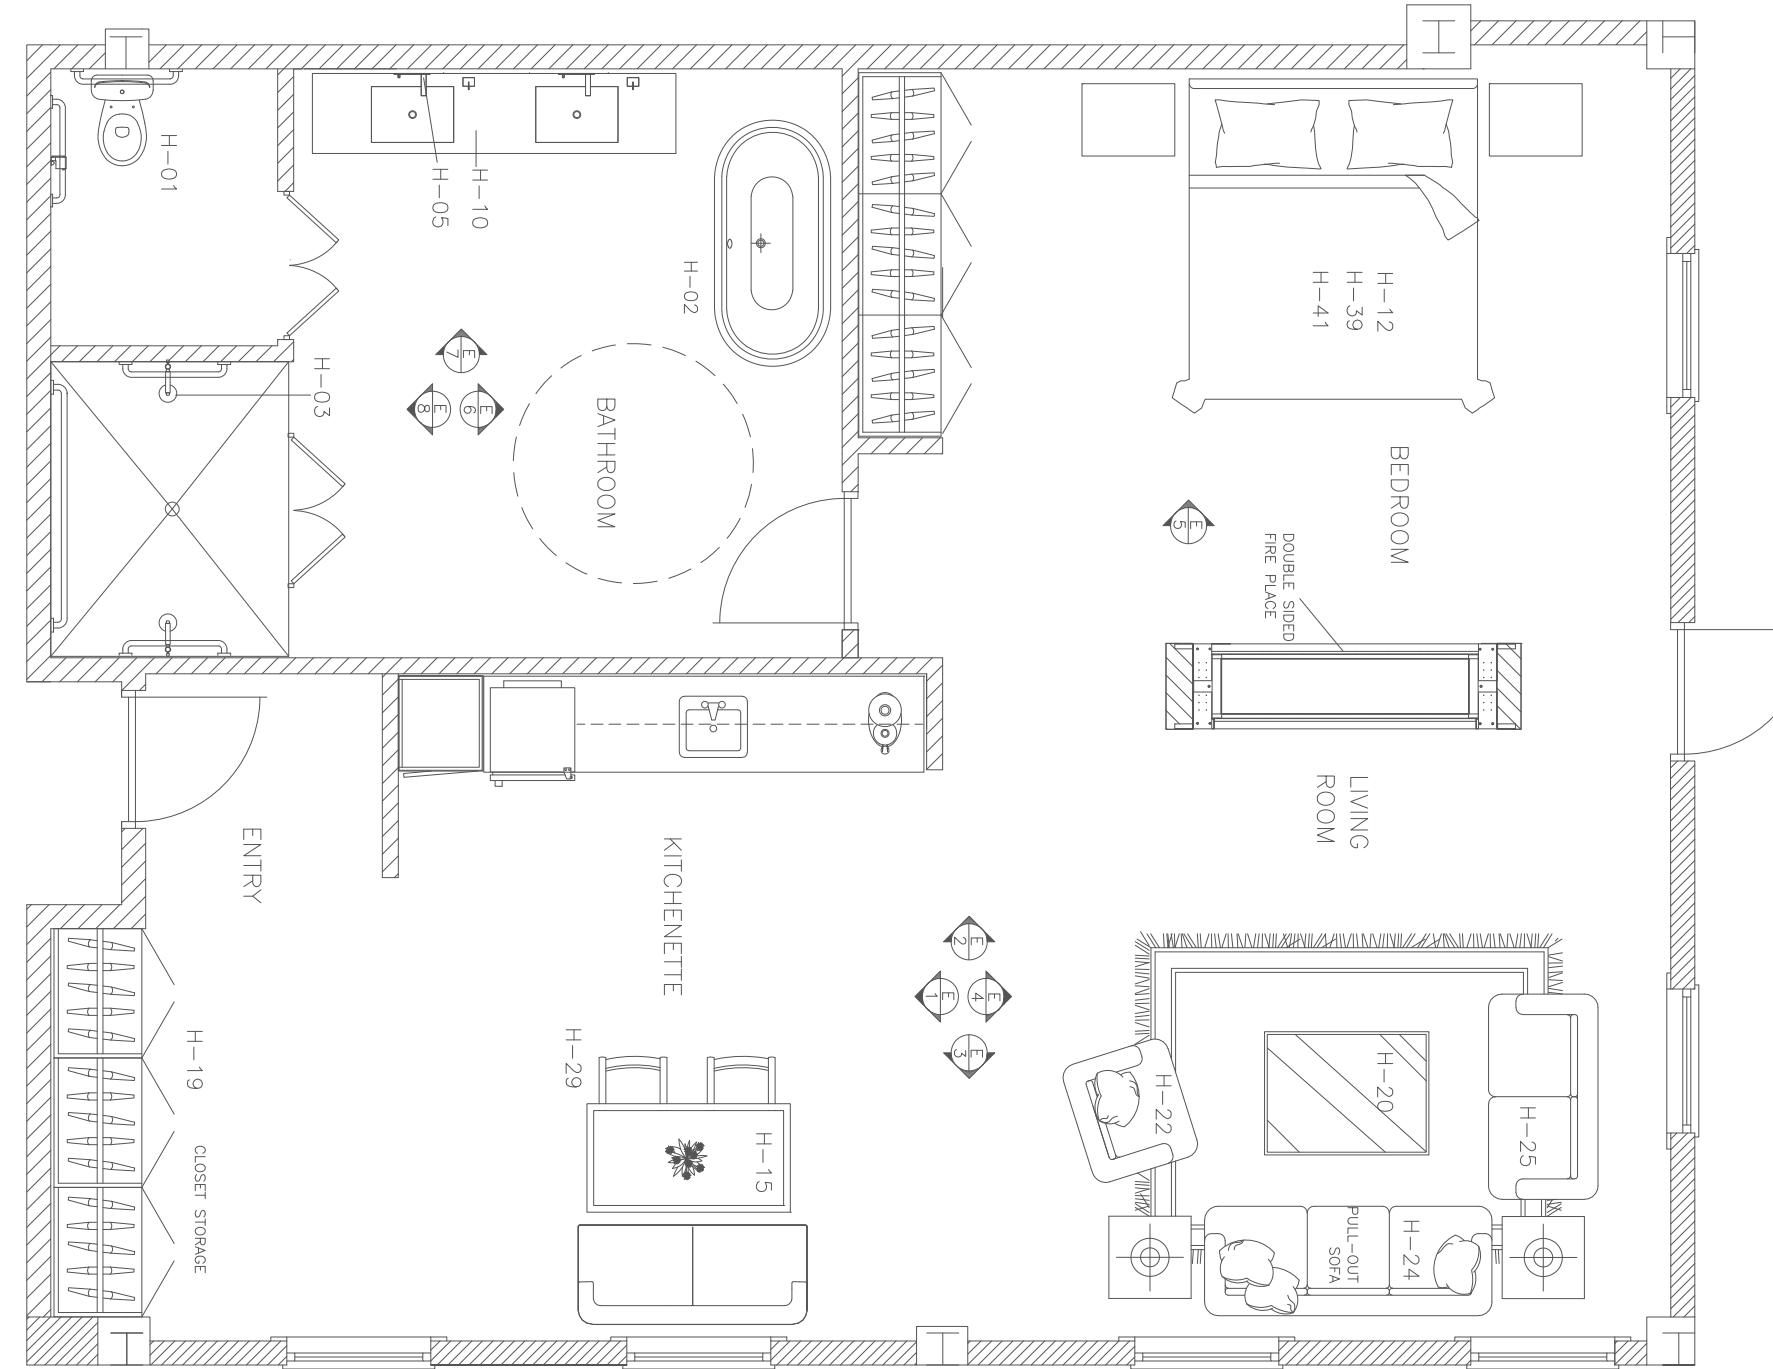

KING SUITE ADA GUESTROOM

FURNITURE PLAN

SCALE: 1/4"=1'-0"

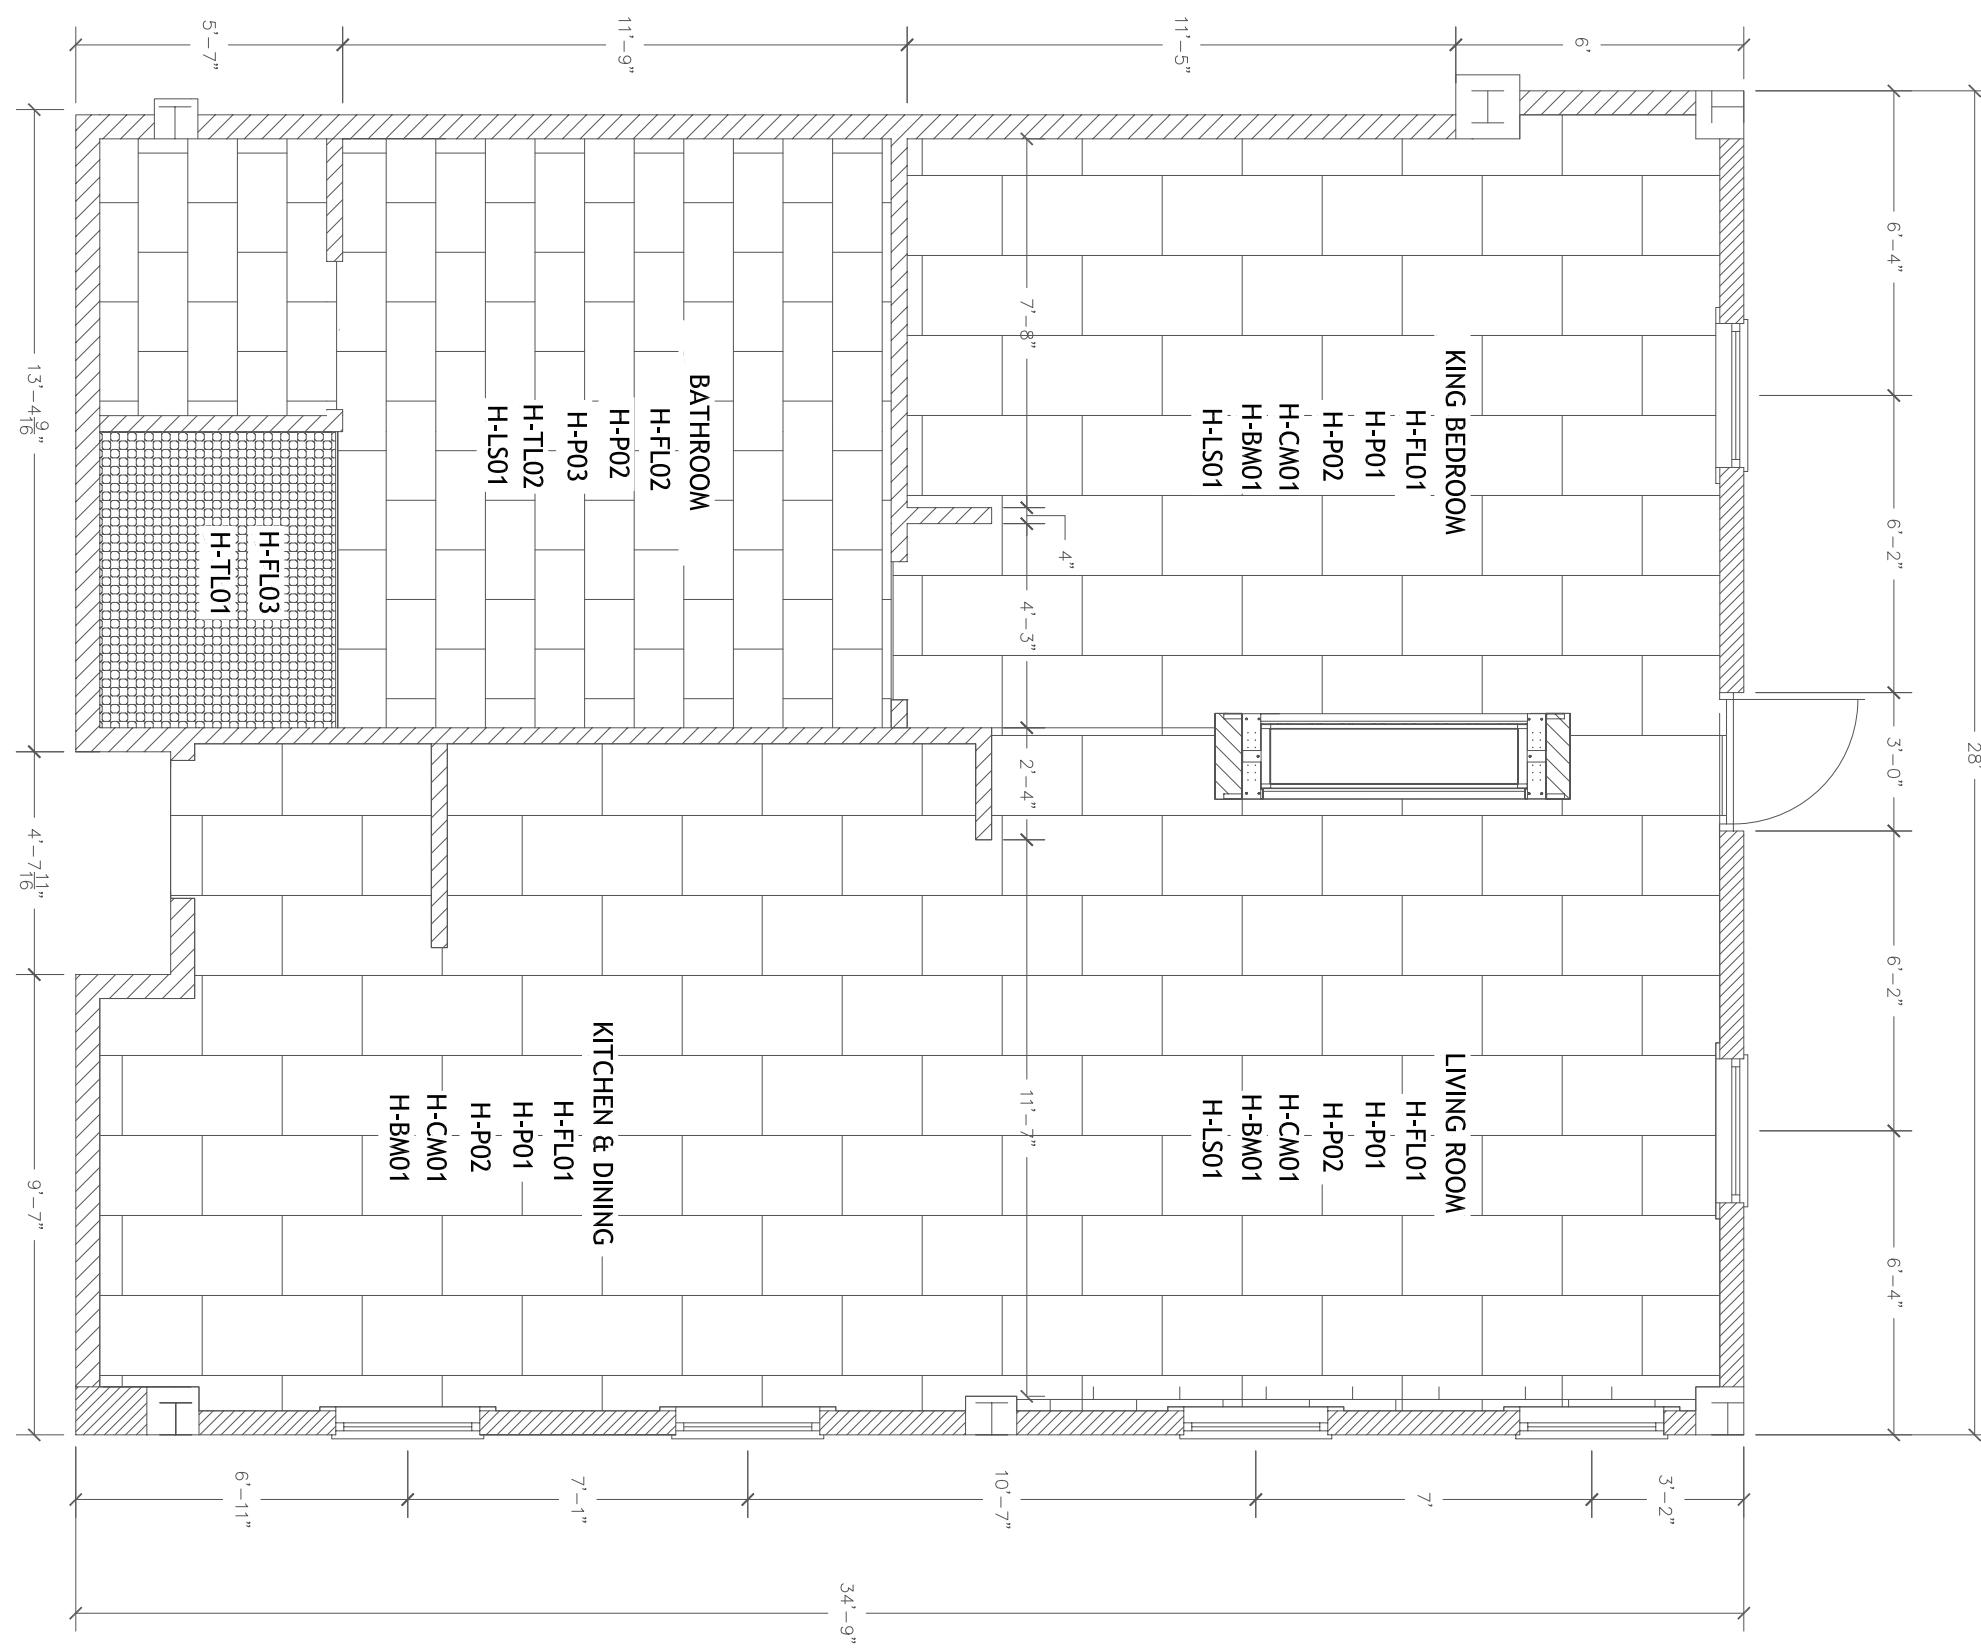

KING SUITE ADA GUESTROOM

FINISH PLAN

SCALE: 1/4"=1'-0"


**GALINOIS**  
123 Ocean Drive,  
Naxos, Cyclades  
32480

**Enlarged King  
Suite ADA  
Guestroom  
Floor Plans A**

FEE LEGEND	
H-01	TOILET
H-02	FREE STANDING TUB
H-03	SHOWER HEAD KIT
H-04	BATH TUB KIT
H-05	DRINK FAUCET
H-06	DROP IN TUB
H-07	MINI FRIDGE
H-08	TV
H-09	SINGLE VANITY
H-10	CUSTOM VANITY
H-11	QUEEN BED SET
H-12	KING BED SET
H-13	BEDSIDE TABLE
H-14	TV UNIT
H-15	DINING TABLE
H-16	SIDE TABLE
H-17	ACCENT TABLE
H-18	DESK
H-19	CUSTOM CABINET UNIT
H-20	COFFEE TABLE
H-41	KING DUVET COVER/SHAMS
H-44	FULL LENGTH MIRROR
H-45	CUSTOM BATH MIRROR
H-46	WALL ART 1
H-47	WALL ART 2
H-48	CIRCULAR MIRROR
H-49	WALL ART 3

BB DESIGN  
BEVERLY BRADSHAW  
2313 ROSEMONT PLACE  
(334)320-1818  
BCBRADSHAW@CRIMSON.UA.EDU


UNIVERSITY OF ALABAMA - INTERIOR DESIGN

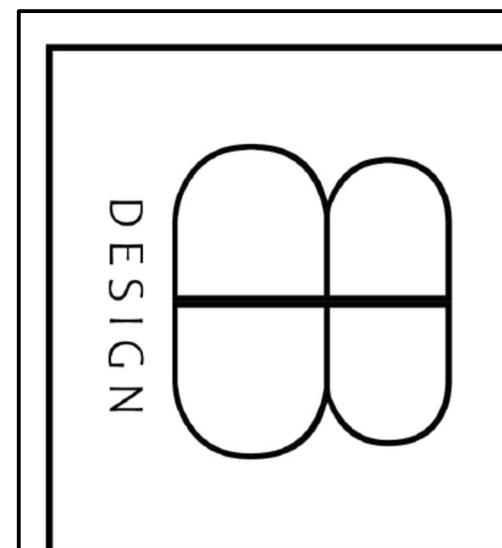

**ID3:02**  
Scale  
 $\frac{1}{4}$ "=1'-0"


RCP LEGEND	
⊗	H-30 HANGING PENDANT LIGHT
⊗	H-32 LARGE HANGING PENDANT
○	H-34 6" RECESSED CAN LIGHT
●	H-35 4" RECESSED CAN LIGHT
△	H-31 WALL SCONCE
□	H-33 LED STRIP LIGHT
⊗	H-36 DINING TABLE CHANDELIER
○	— FIRE SPRINKLER
—	— HVAC RETURN VENT
—	— EXHAUST FAN
●	— 8" HANGING PENDANT
○	— CEILING FLUSH PENDANT
—	— 10" HANGING PENDANT
○	— LARGE CHANDELIER
⊕	— RETRO CHANDELIER

KING SUITE ADA GUESTROOM  
REFLECTED CEILING PLAN  
SCALE: 1/4"=1'-0"

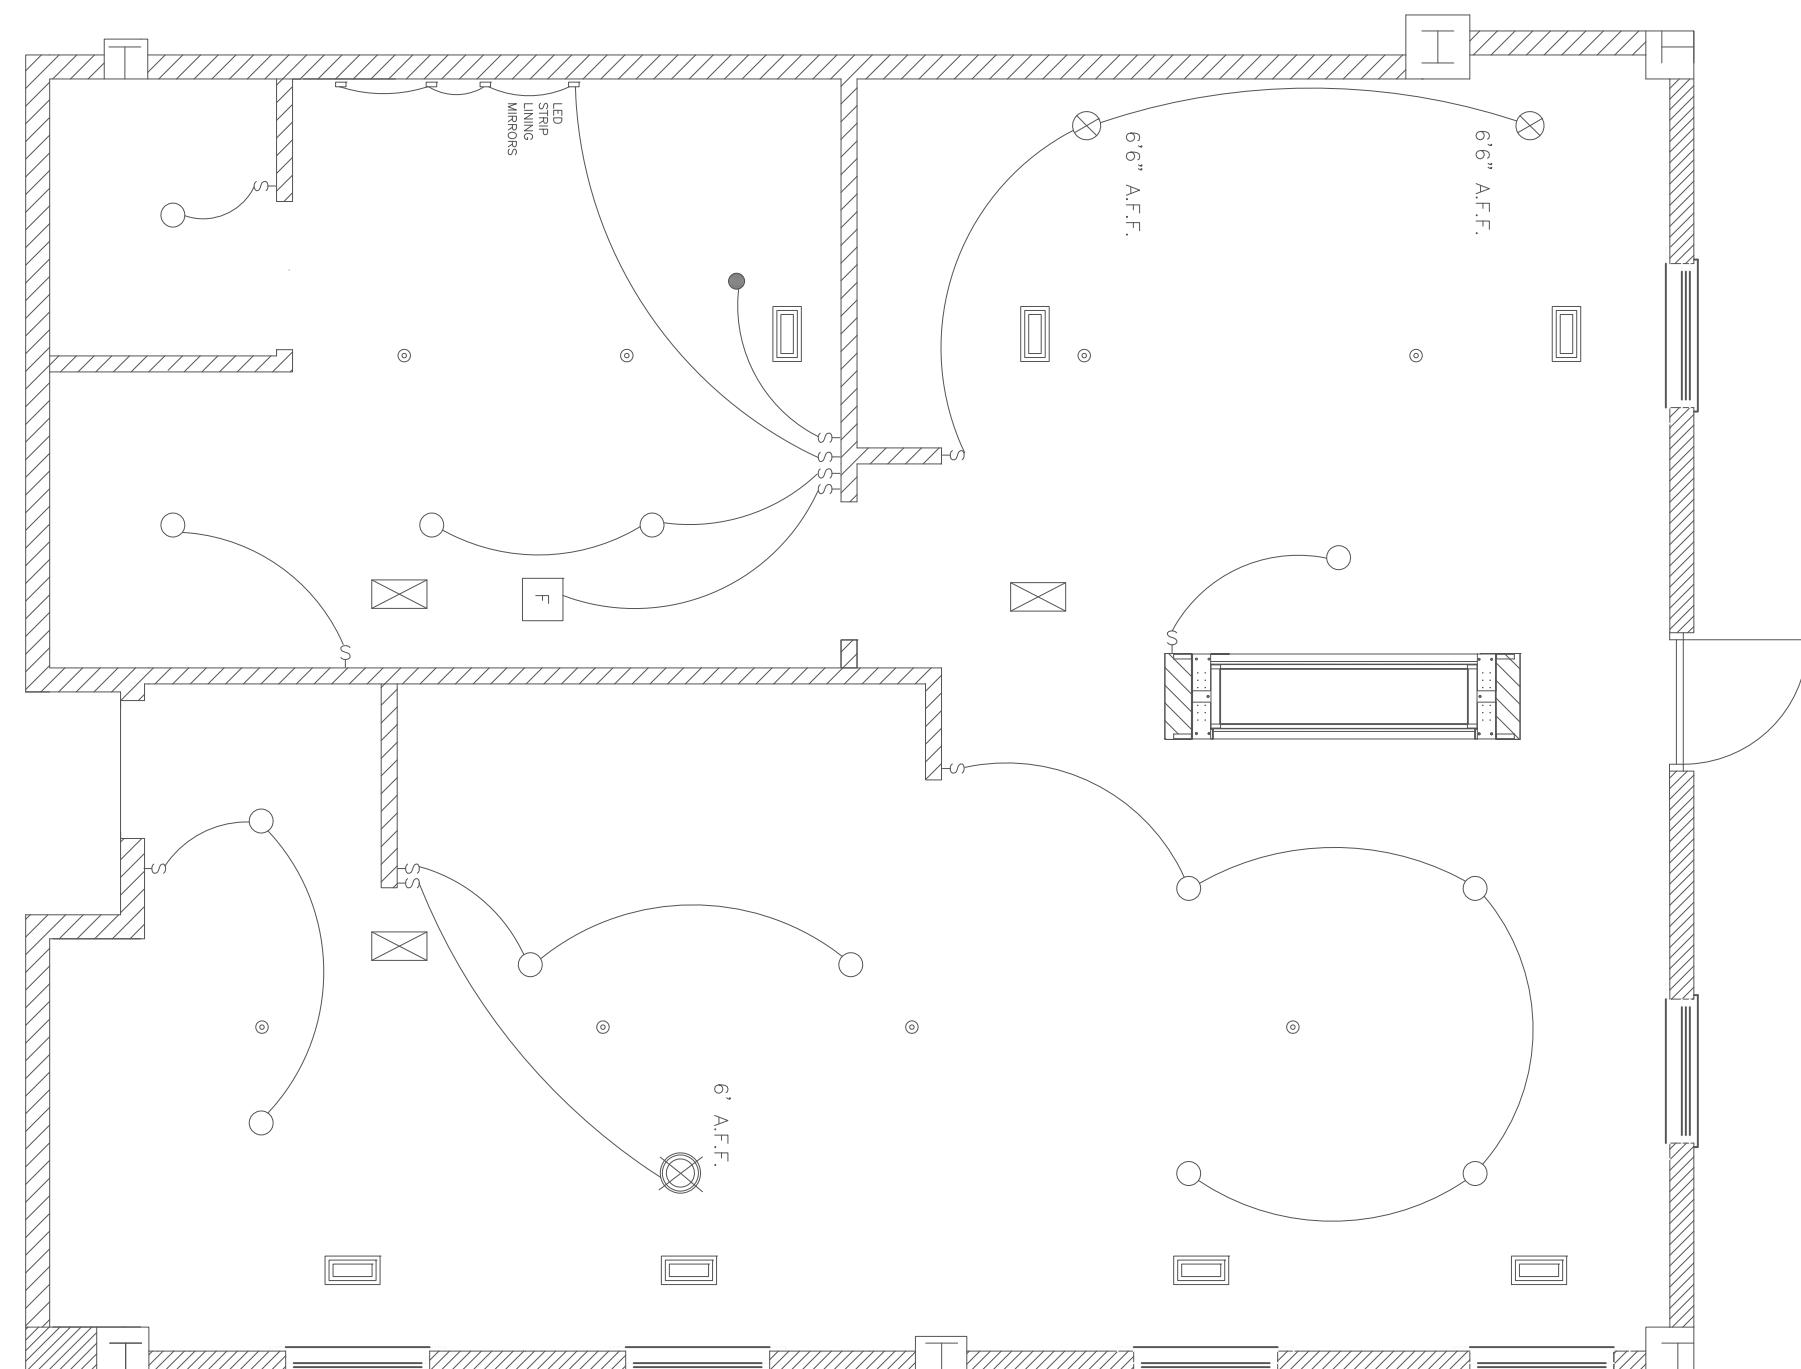


ELECTRICAL LEGEND	
⊕	DUPLEX CONVENIENCE OUTLET
⊕	GFI OUTLET
⊕	220V OUTLET
⊕	60V OUTLET
⊕	JUNCTION BOX
▷	TELEPHONE
▼	CABLE
⌚	INTERNET
NOTES:	
UNLESS OTHERWISE NOTED, ALL OUTLETS ARE 15" A.F. STANDARD AND 18" A.F.F. IN ADA ROOMS	

KING SUITE ADA GUESTROOM  
ELECTRICAL PLAN  
SCALE: 1/4"=1'-0"

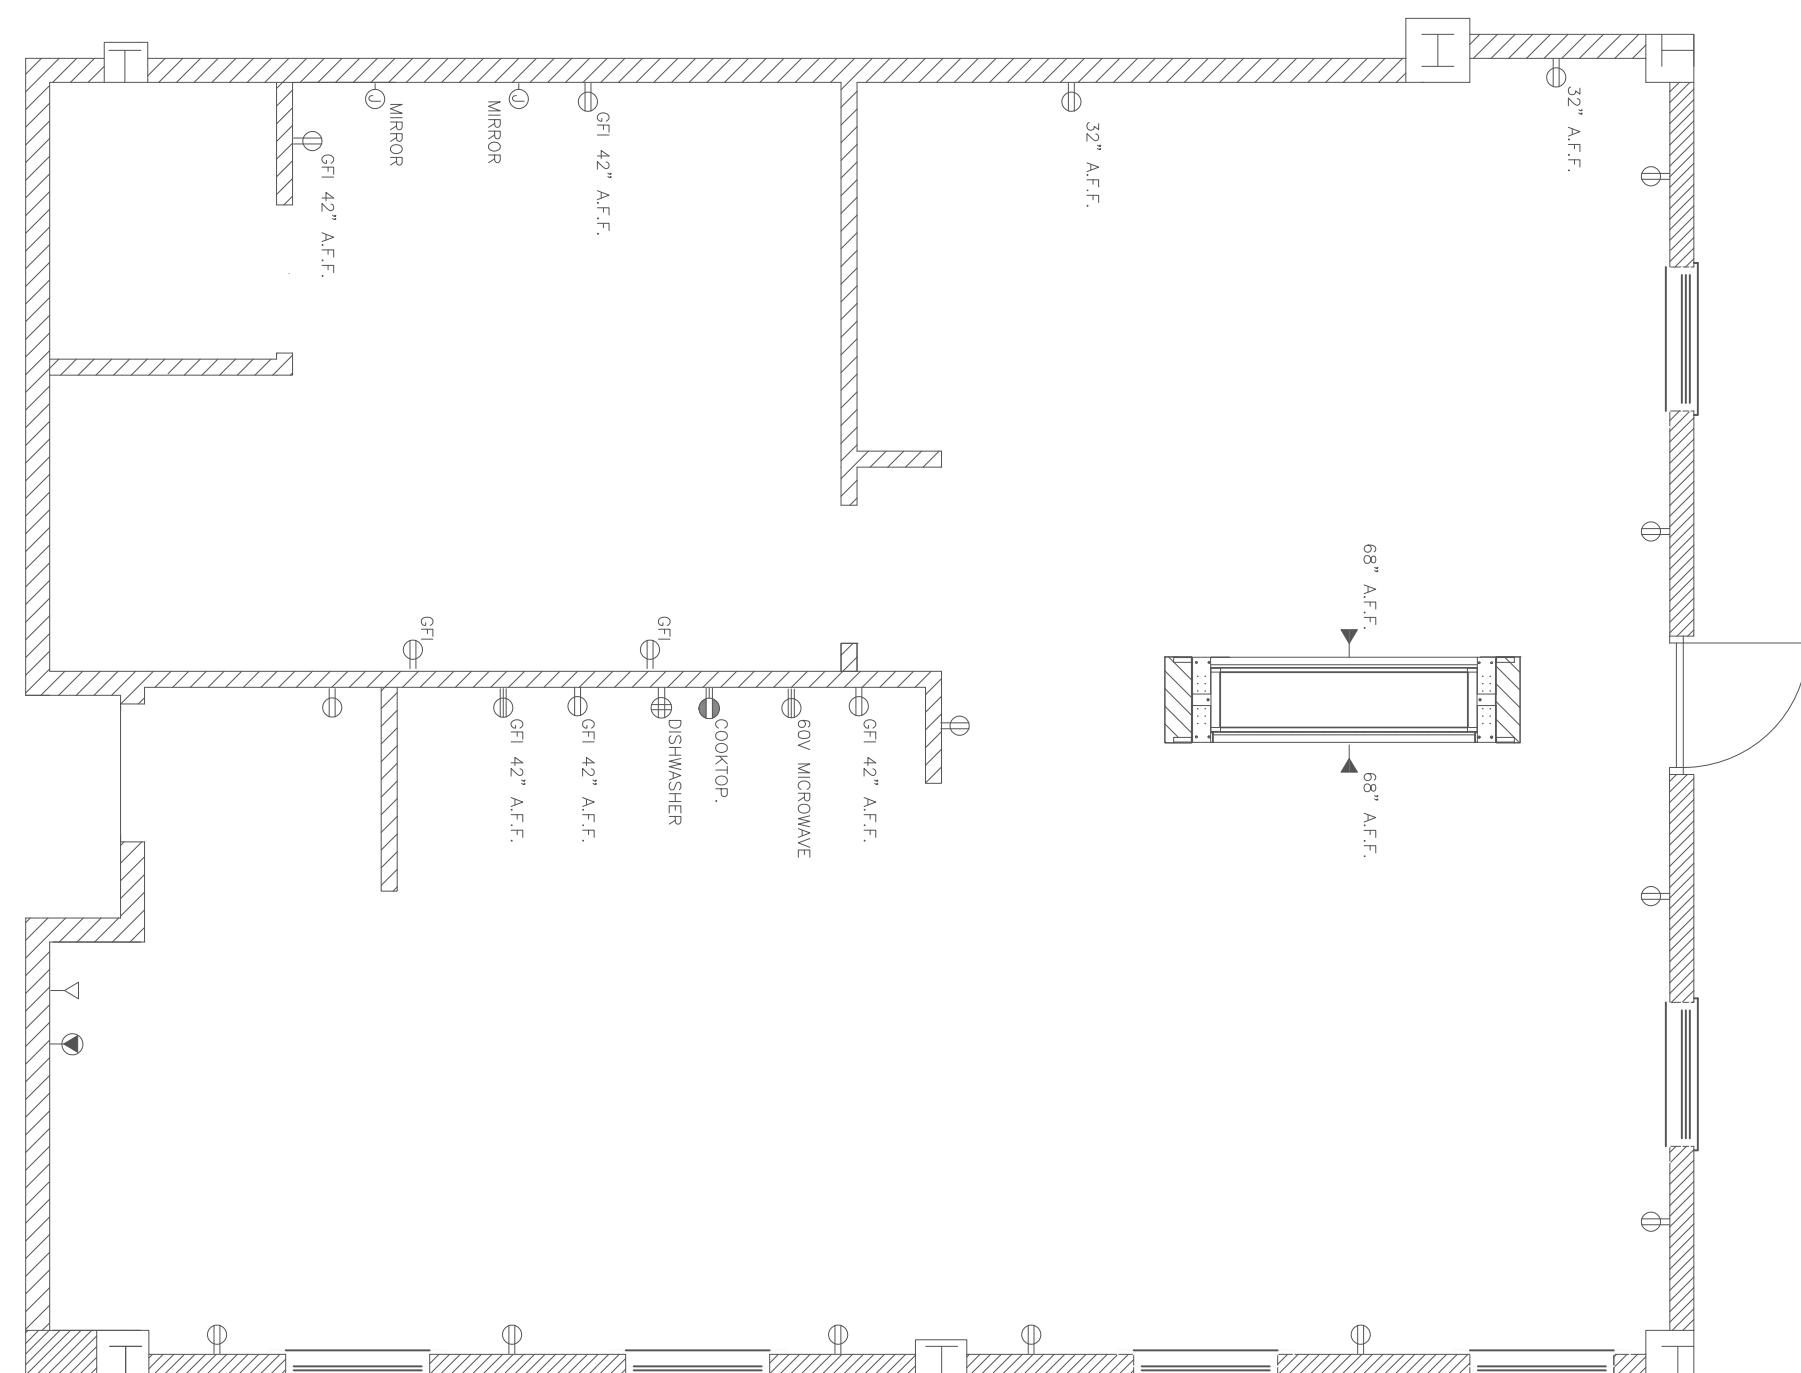


Floor Plans - B	
Project Number	2000.01
Drawn By	10 April, 2025
Checked By	Beverly Bradshaw
	Bethany Blevins
ID3:03	
Scale	
1/4"=1'-0"	

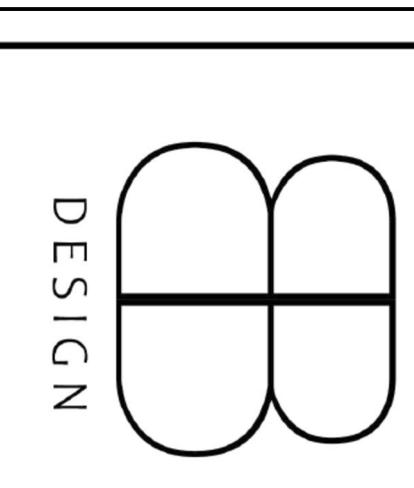


UNIVERSITY OF ALABAMA - INTERIOR DESIGN		
BB DESIGN	BEVERLY BRADSHAW	2313 ROSEMONT PLACE
		(334)320-8188
		BCBRADSHAW@CRIMSON.UA.EDU
No.	Description	Date


**E 1 KING SUITE ADA SOUTH ELEVATION**  
SCALE: 1/4"=1'-0"

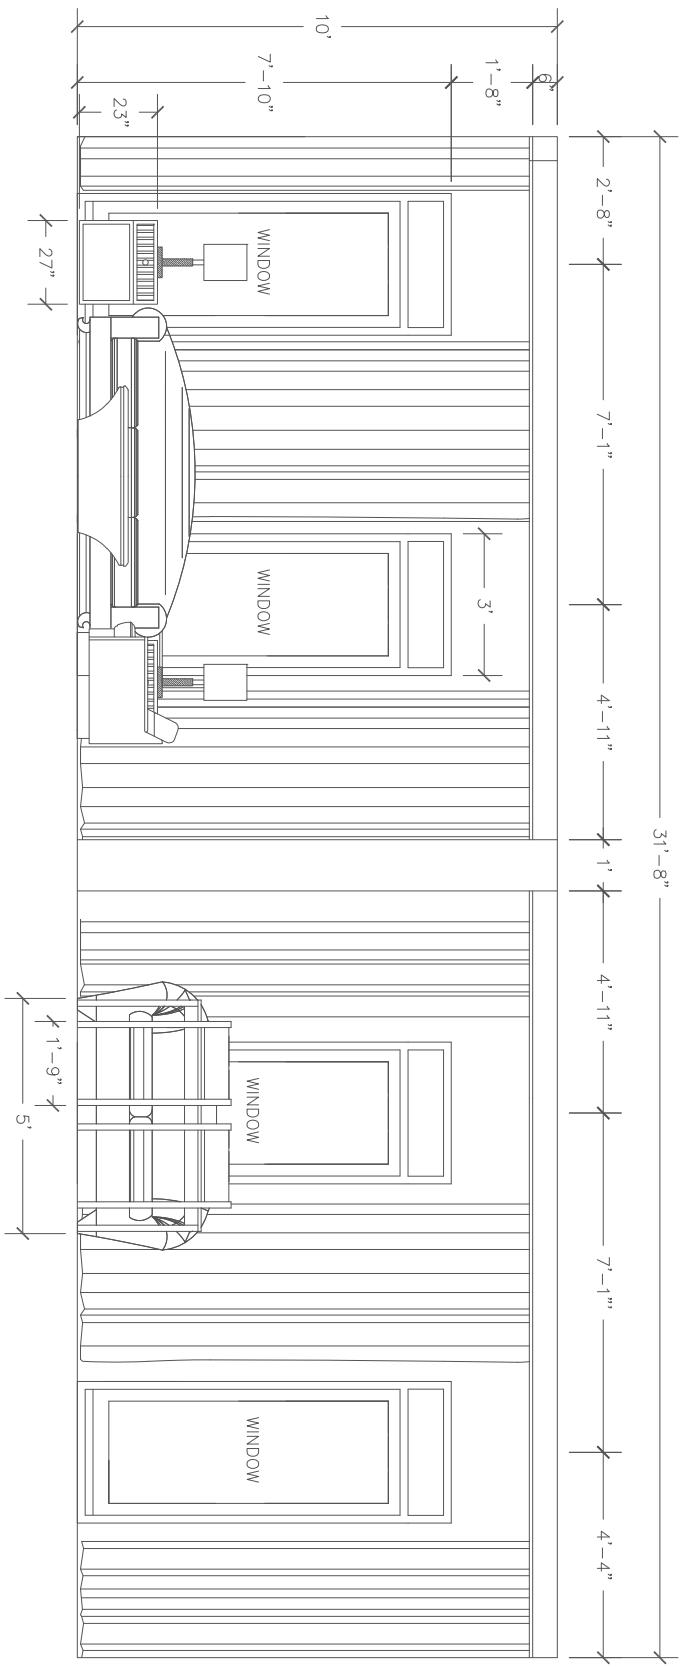


**E 2 KING SUITE ADA WEST ELEVATION**  
SCALE: 1/4"=1'-0"

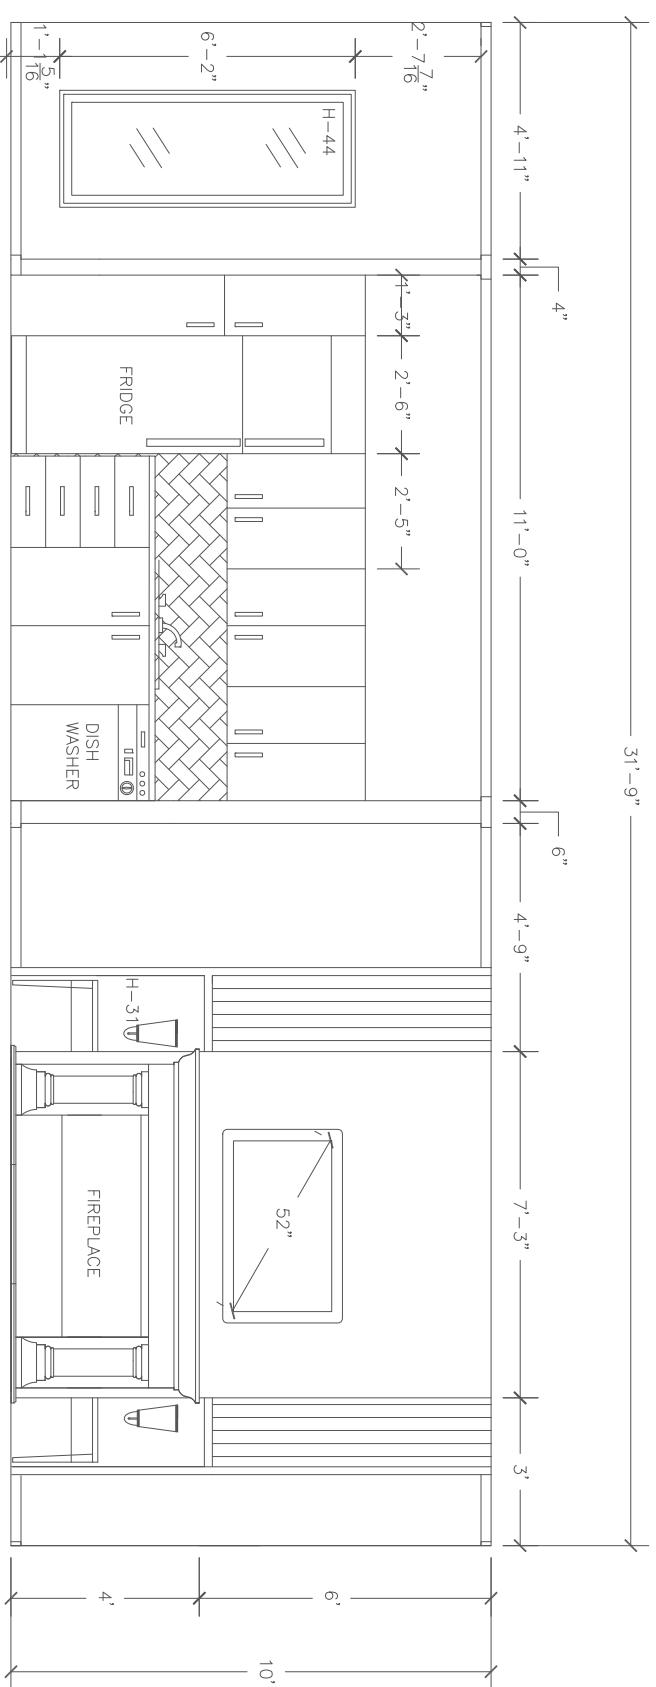


**E 3 KING SUITE ADA EAST ELEVATION**  
SCALE: 1/4"=1'-0"

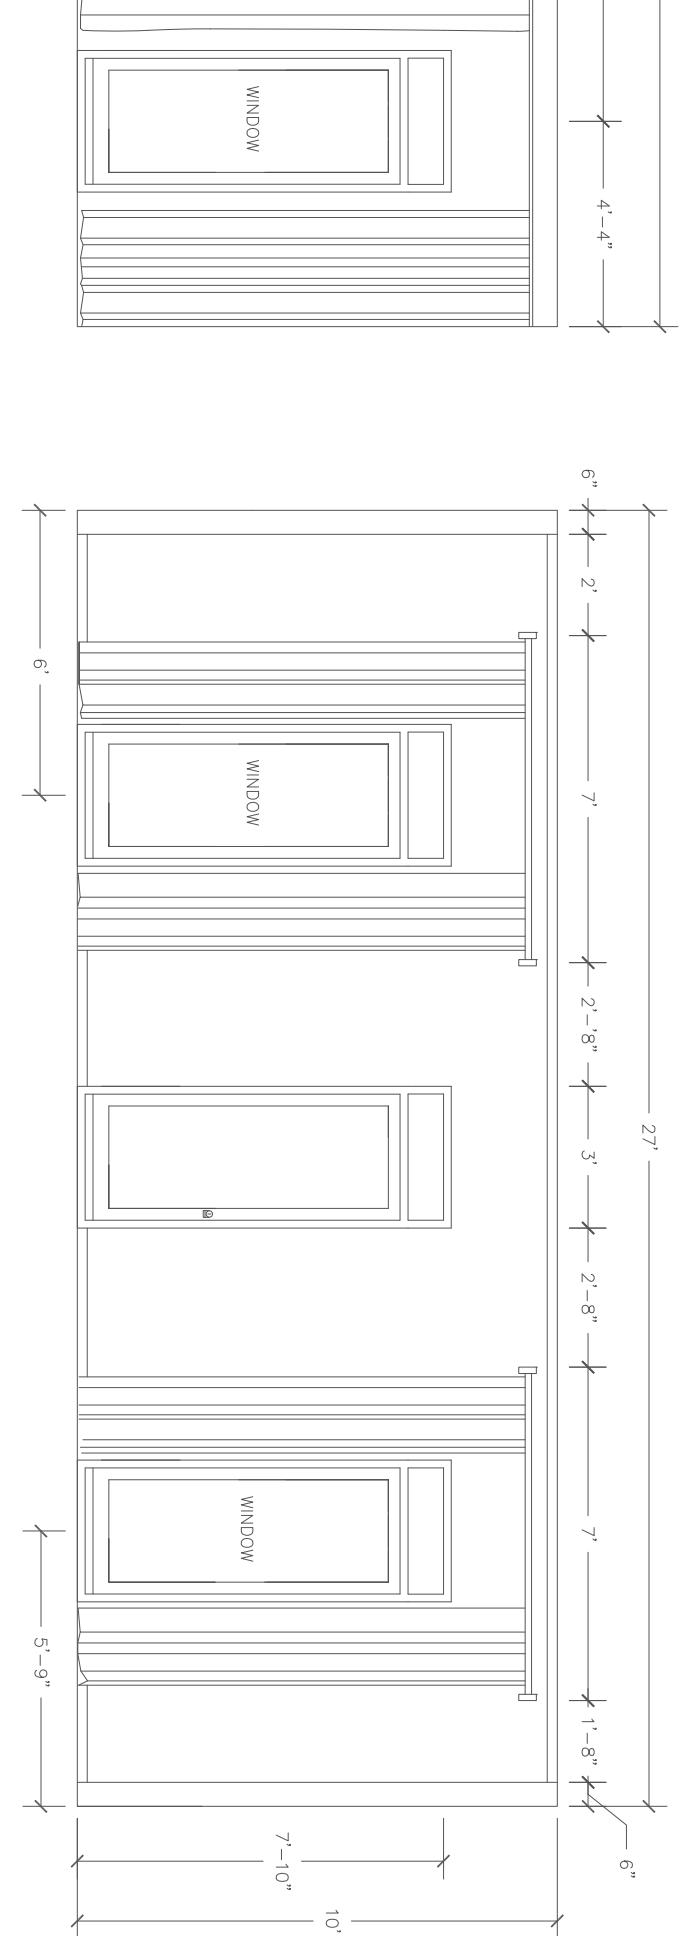


**E 4 KING SUITE ADA NORTH ELEVATION**  
SCALE: 1/4"=1'-0"

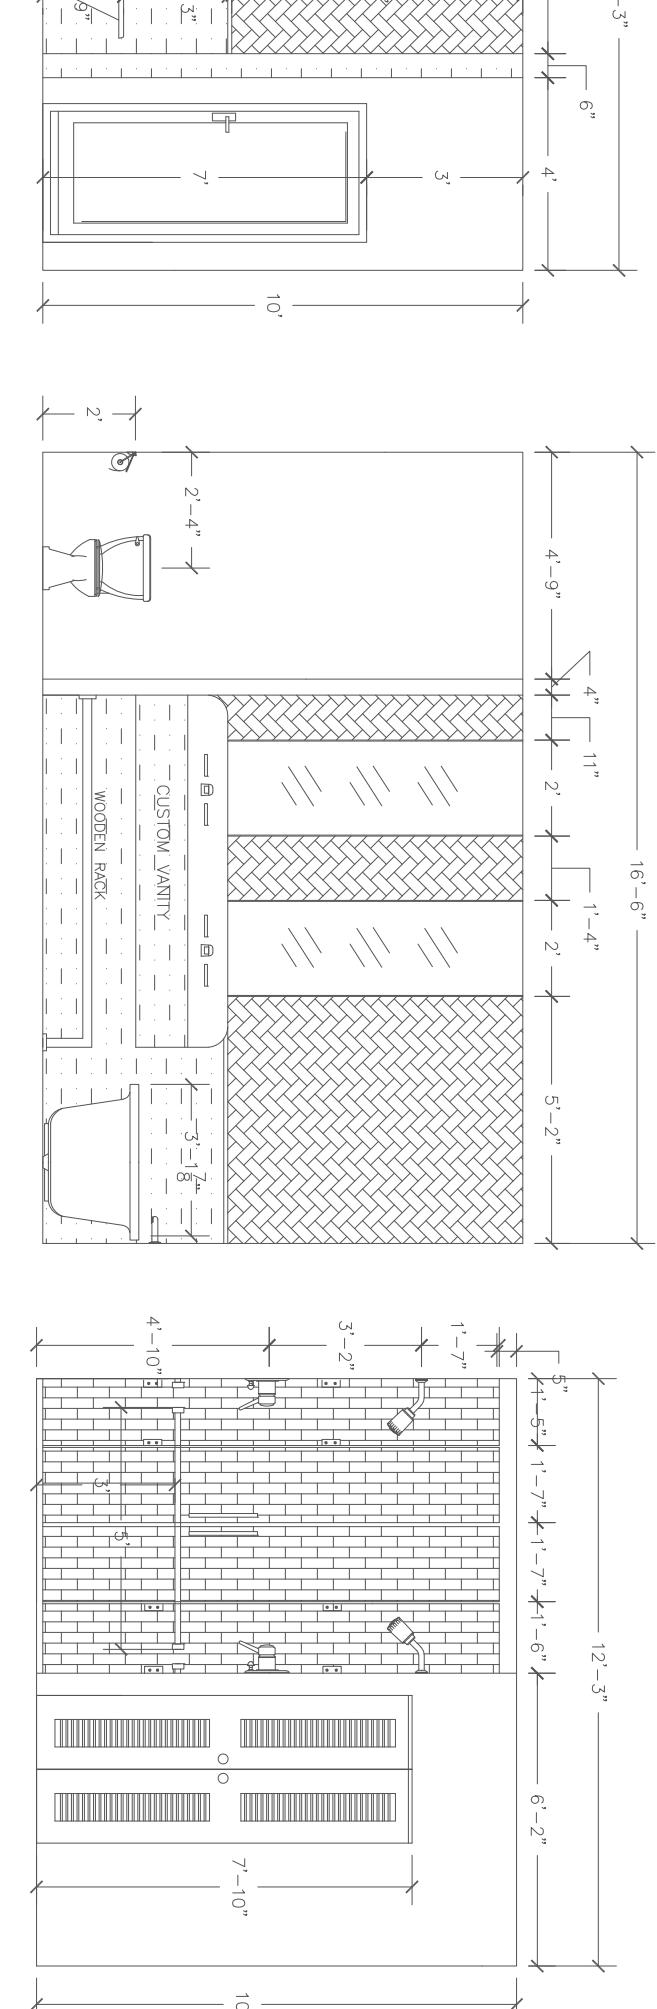


**E 5 KING SUITE ADA BEDROOM ELEVATION**  
SCALE: 1/4"=1'-0"

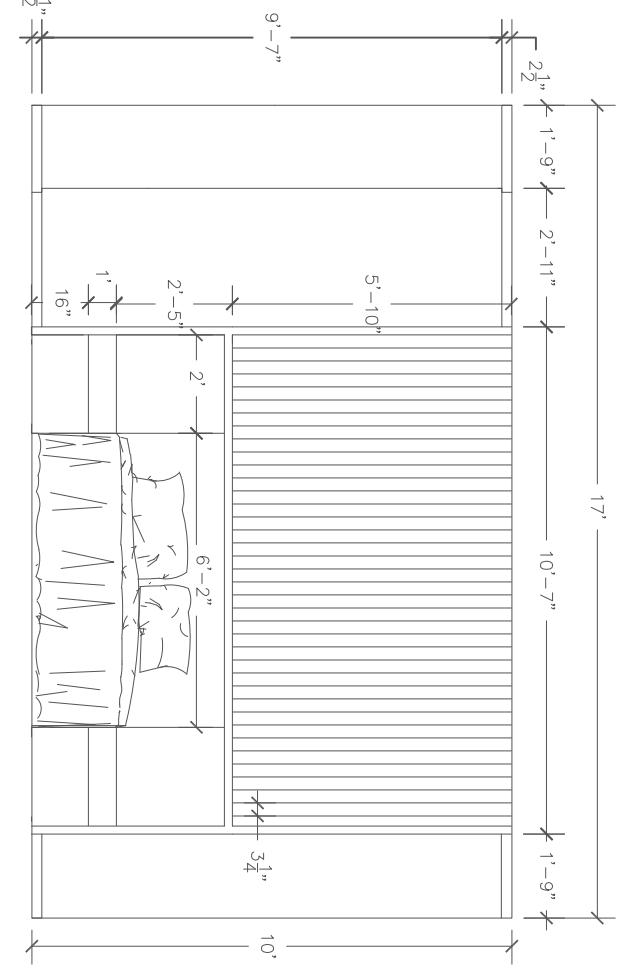


**E 6 BATH NORTH ELEVATION**  
SCALE: 1/4"=1'-0"

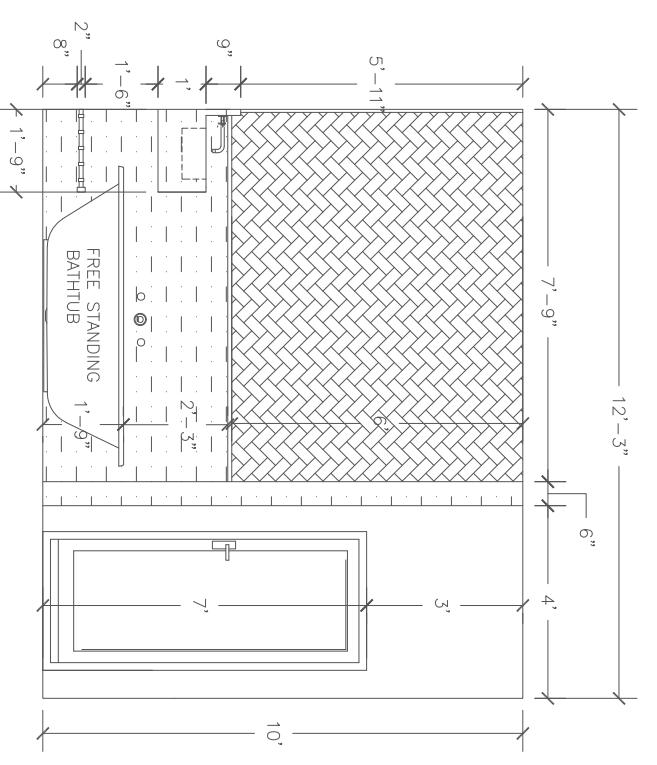

**E 7 BATH WEST ELEVATION**  
SCALE: 1/4"=1'-0"

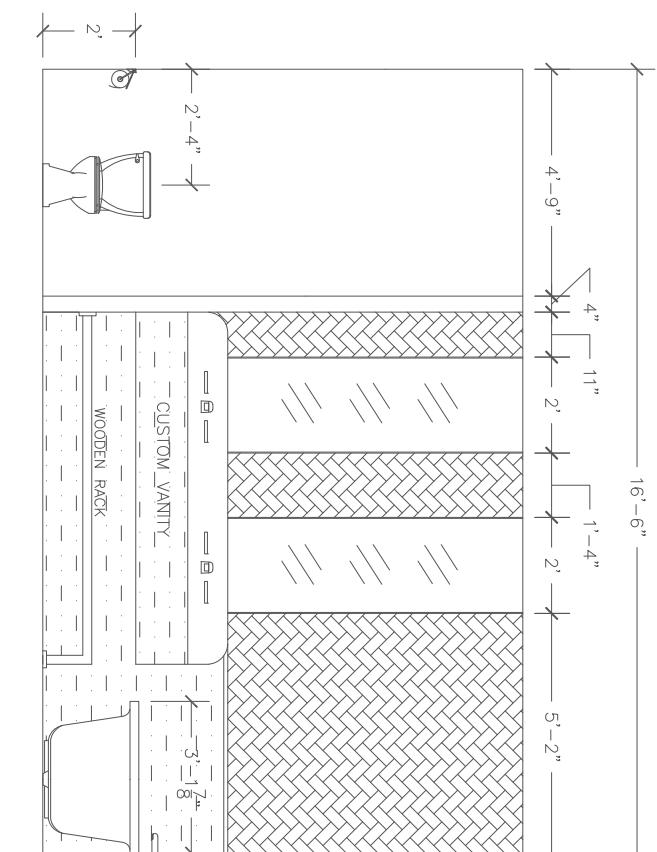

**E 8 BATH SOUTH ELEVATION**  
SCALE: 1/4"=1'-0"

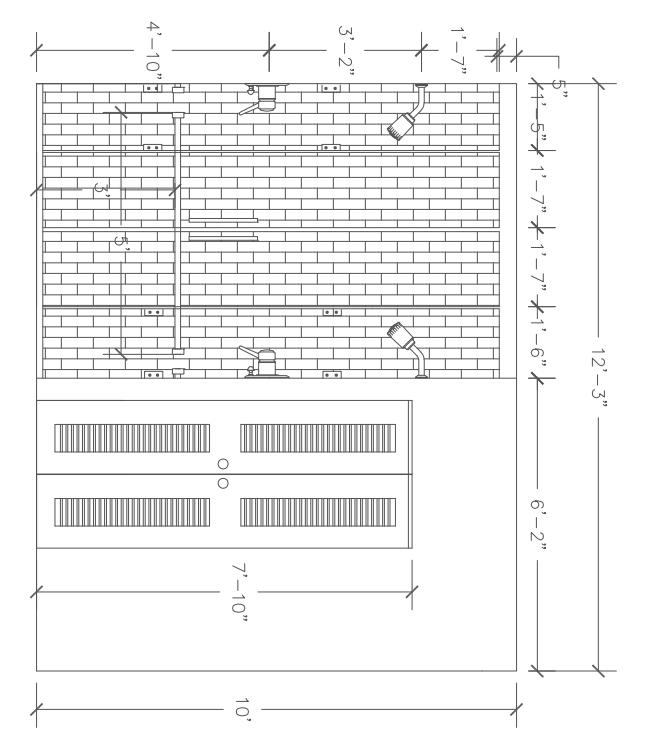

## GALINOIS

123 Ocean Drive,  
Naxos, Cyclades

32480

### King Suite ADA Guestroom Elevations


Project Number 2000.01  
Drawn By Beverly Bradshaw  
Checked By Bethany Bleivins

Scale

$\frac{1}{4}$ "=1'-0"


**BB DESIGN**  
BEVERLY BRADSHAW  
2313 ROSEMONT PLACE  
(334)320-1818  
BCBRADSHAW@CRIMSON.UA.EDU

UNIVERSITY OF ALABAMA - INTERIOR DESIGN

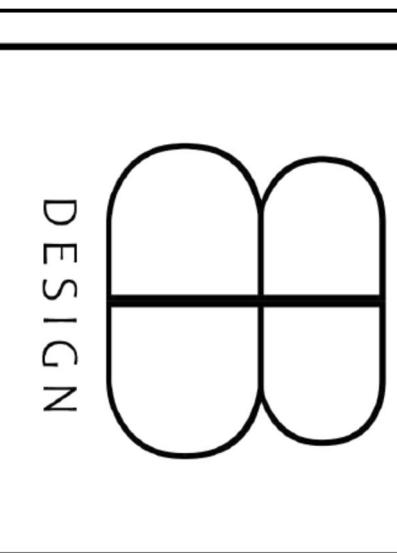






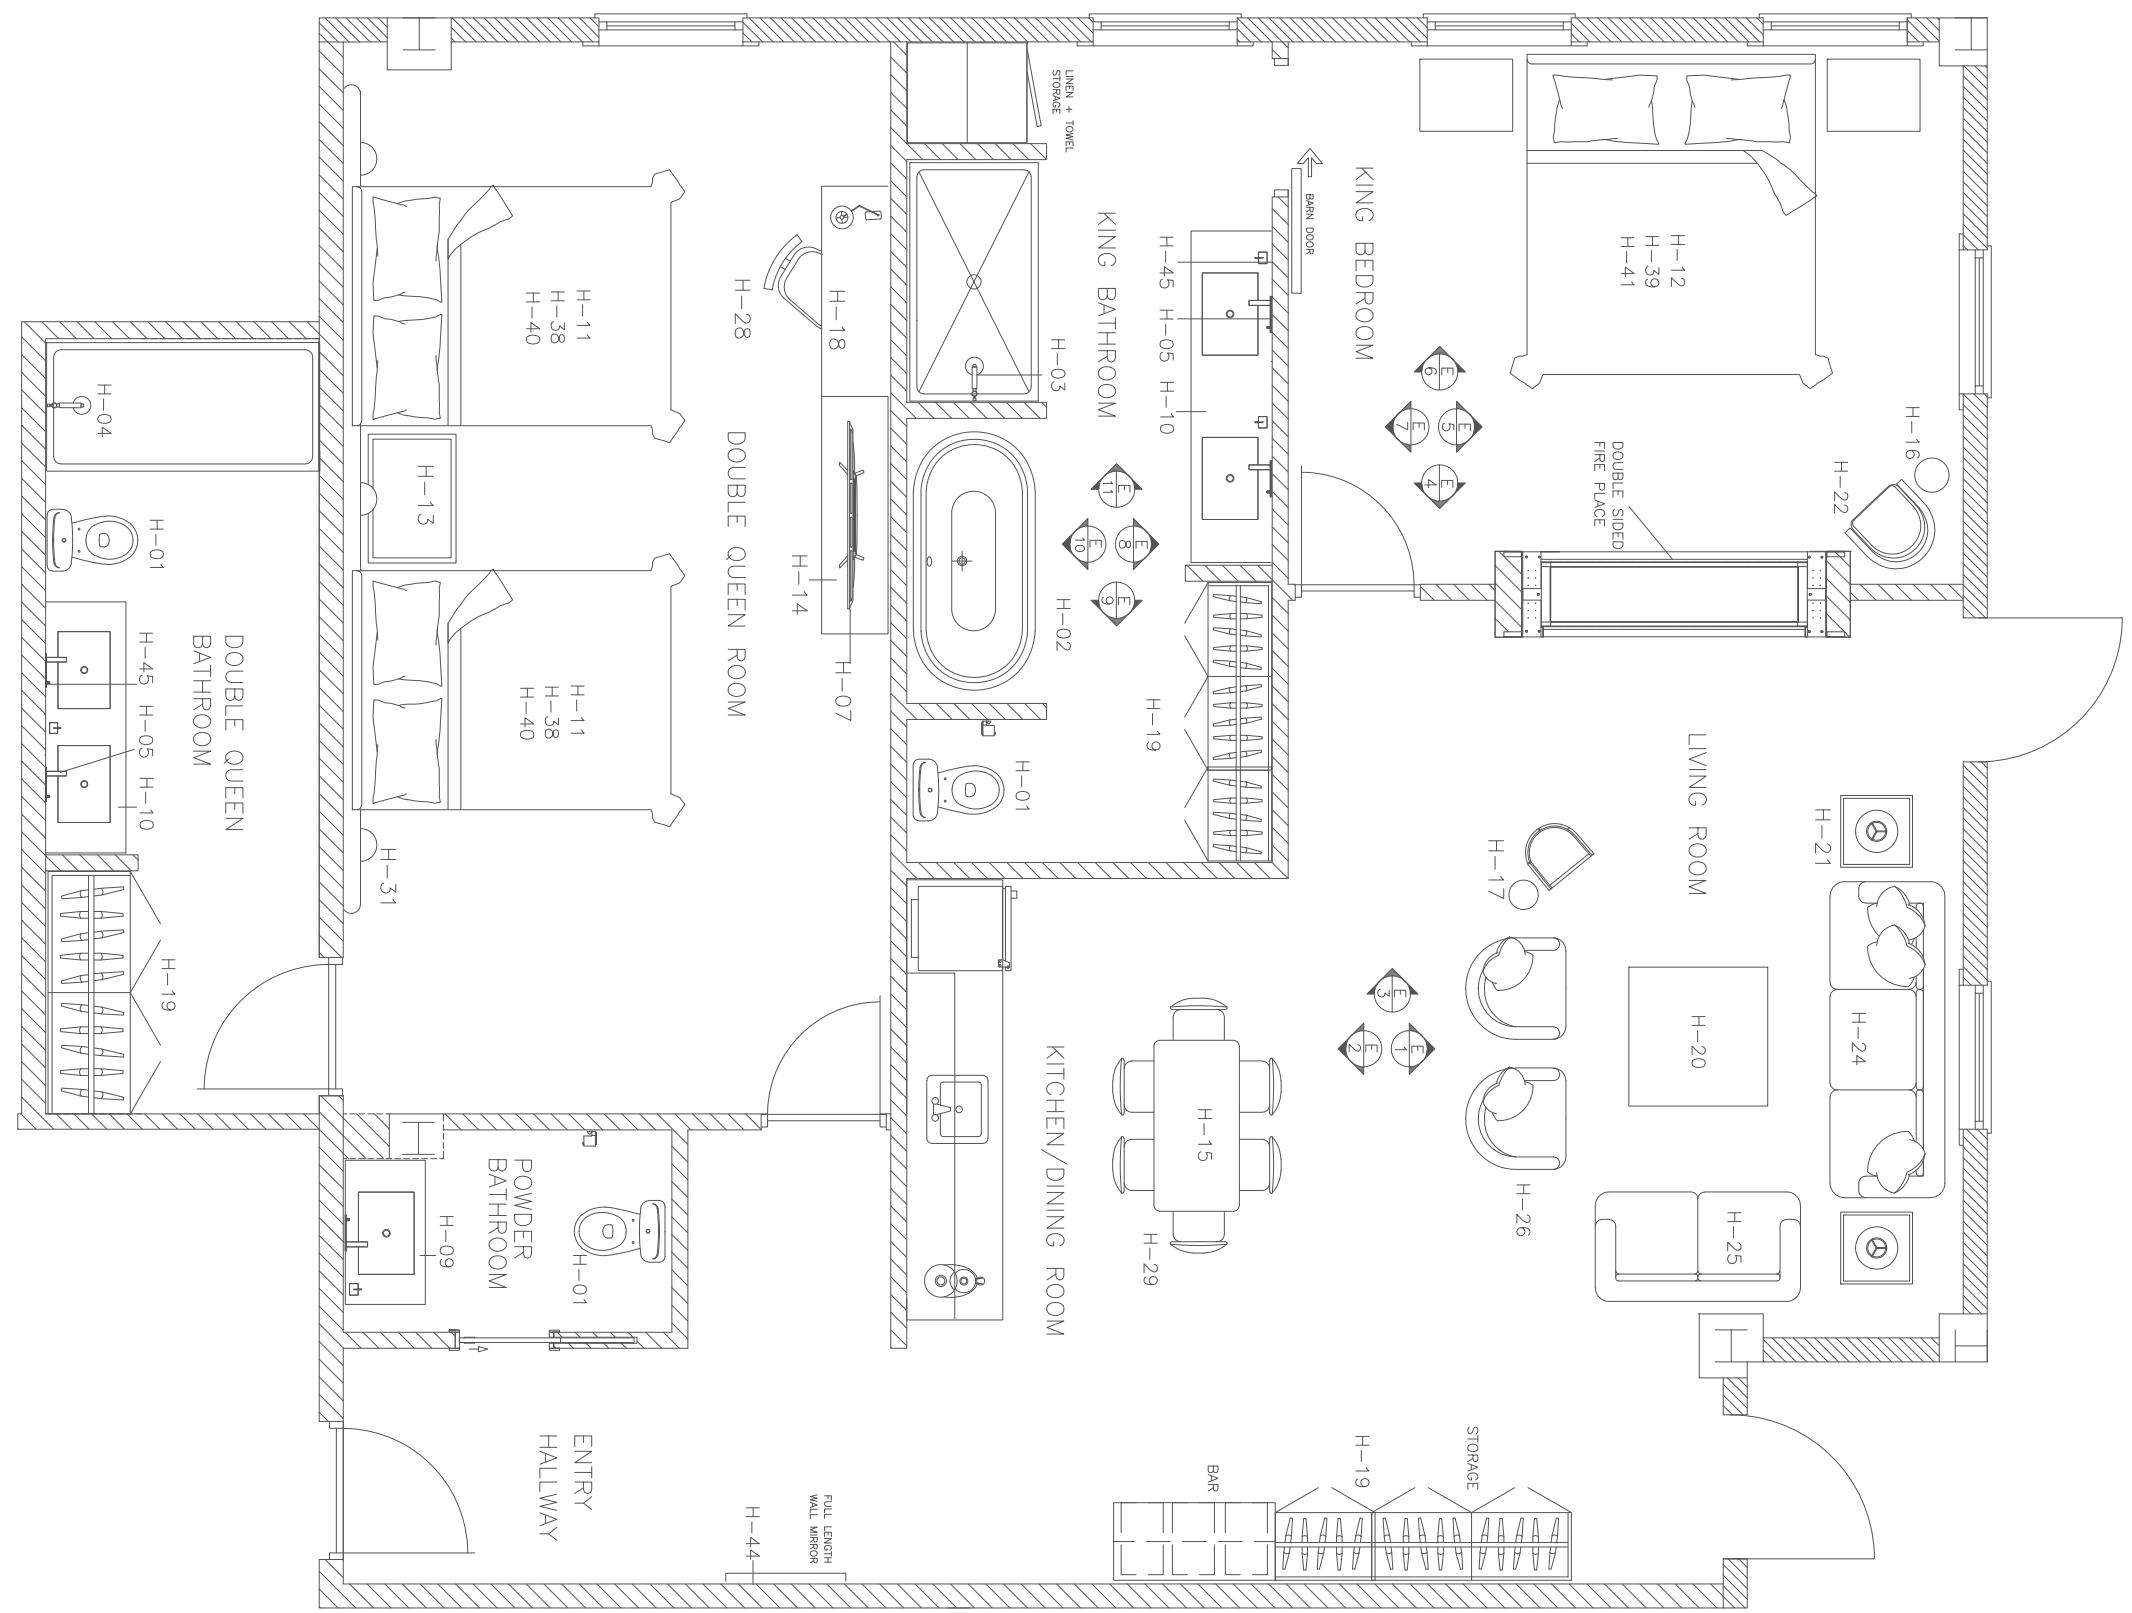

FFE LEGEND	
H-01	TOILET
H-02	FREE STANDING TUB
H-03	SHOWER HEAD KIT
H-04	BATH TUB KIT
H-05	SINK FAUCET
H-06	DROP IN TUB
H-07	MINI FRIDGE
H-08	TV
H-09	SINGLE VANITY
H-10	CUSTOM VANITY
H-11	QUEEN BED SET
H-12	KING BED SET
H-13	BEDSIDE TABLE
H-14	TV UNIT
H-15	DINING TABLE
H-16	SIDE TABLE
H-17	ACCENT TABLE
H-18	DESK
H-19	CUSTOM CABINET UNIT
H-20	COFFEE TABLE
H-21	END TABLE
H-22	SIDE CHAIR
H-23	UPHOLSTERED BENCH
H-24	LARGE SOFA
H-25	SMALL SOFA
H-26	SIDE CHAIR 2
H-27	LOUNGE CHAIR
H-28	DESK CHAIR
H-29	DINING CHAIR
H-30	QUEEN MATTRESS
H-31	KING MATTRESS
H-32	QUEEN DUVET COVER/SHAMS
H-33	KING DOVET COVER/SHAMS
H-34	FULL LENGTH MIRROR
H-35	CUSTOM BATH MIRROR
H-36	WALL ART 1
H-37	WALL ART 2
H-38	CIRCULAR MIRROR
H-39	WALL ART 3

KING SUITE ADA GUESTROOM  
FURNITURE PLAN  
SCALE: 1/4"=1'-0"


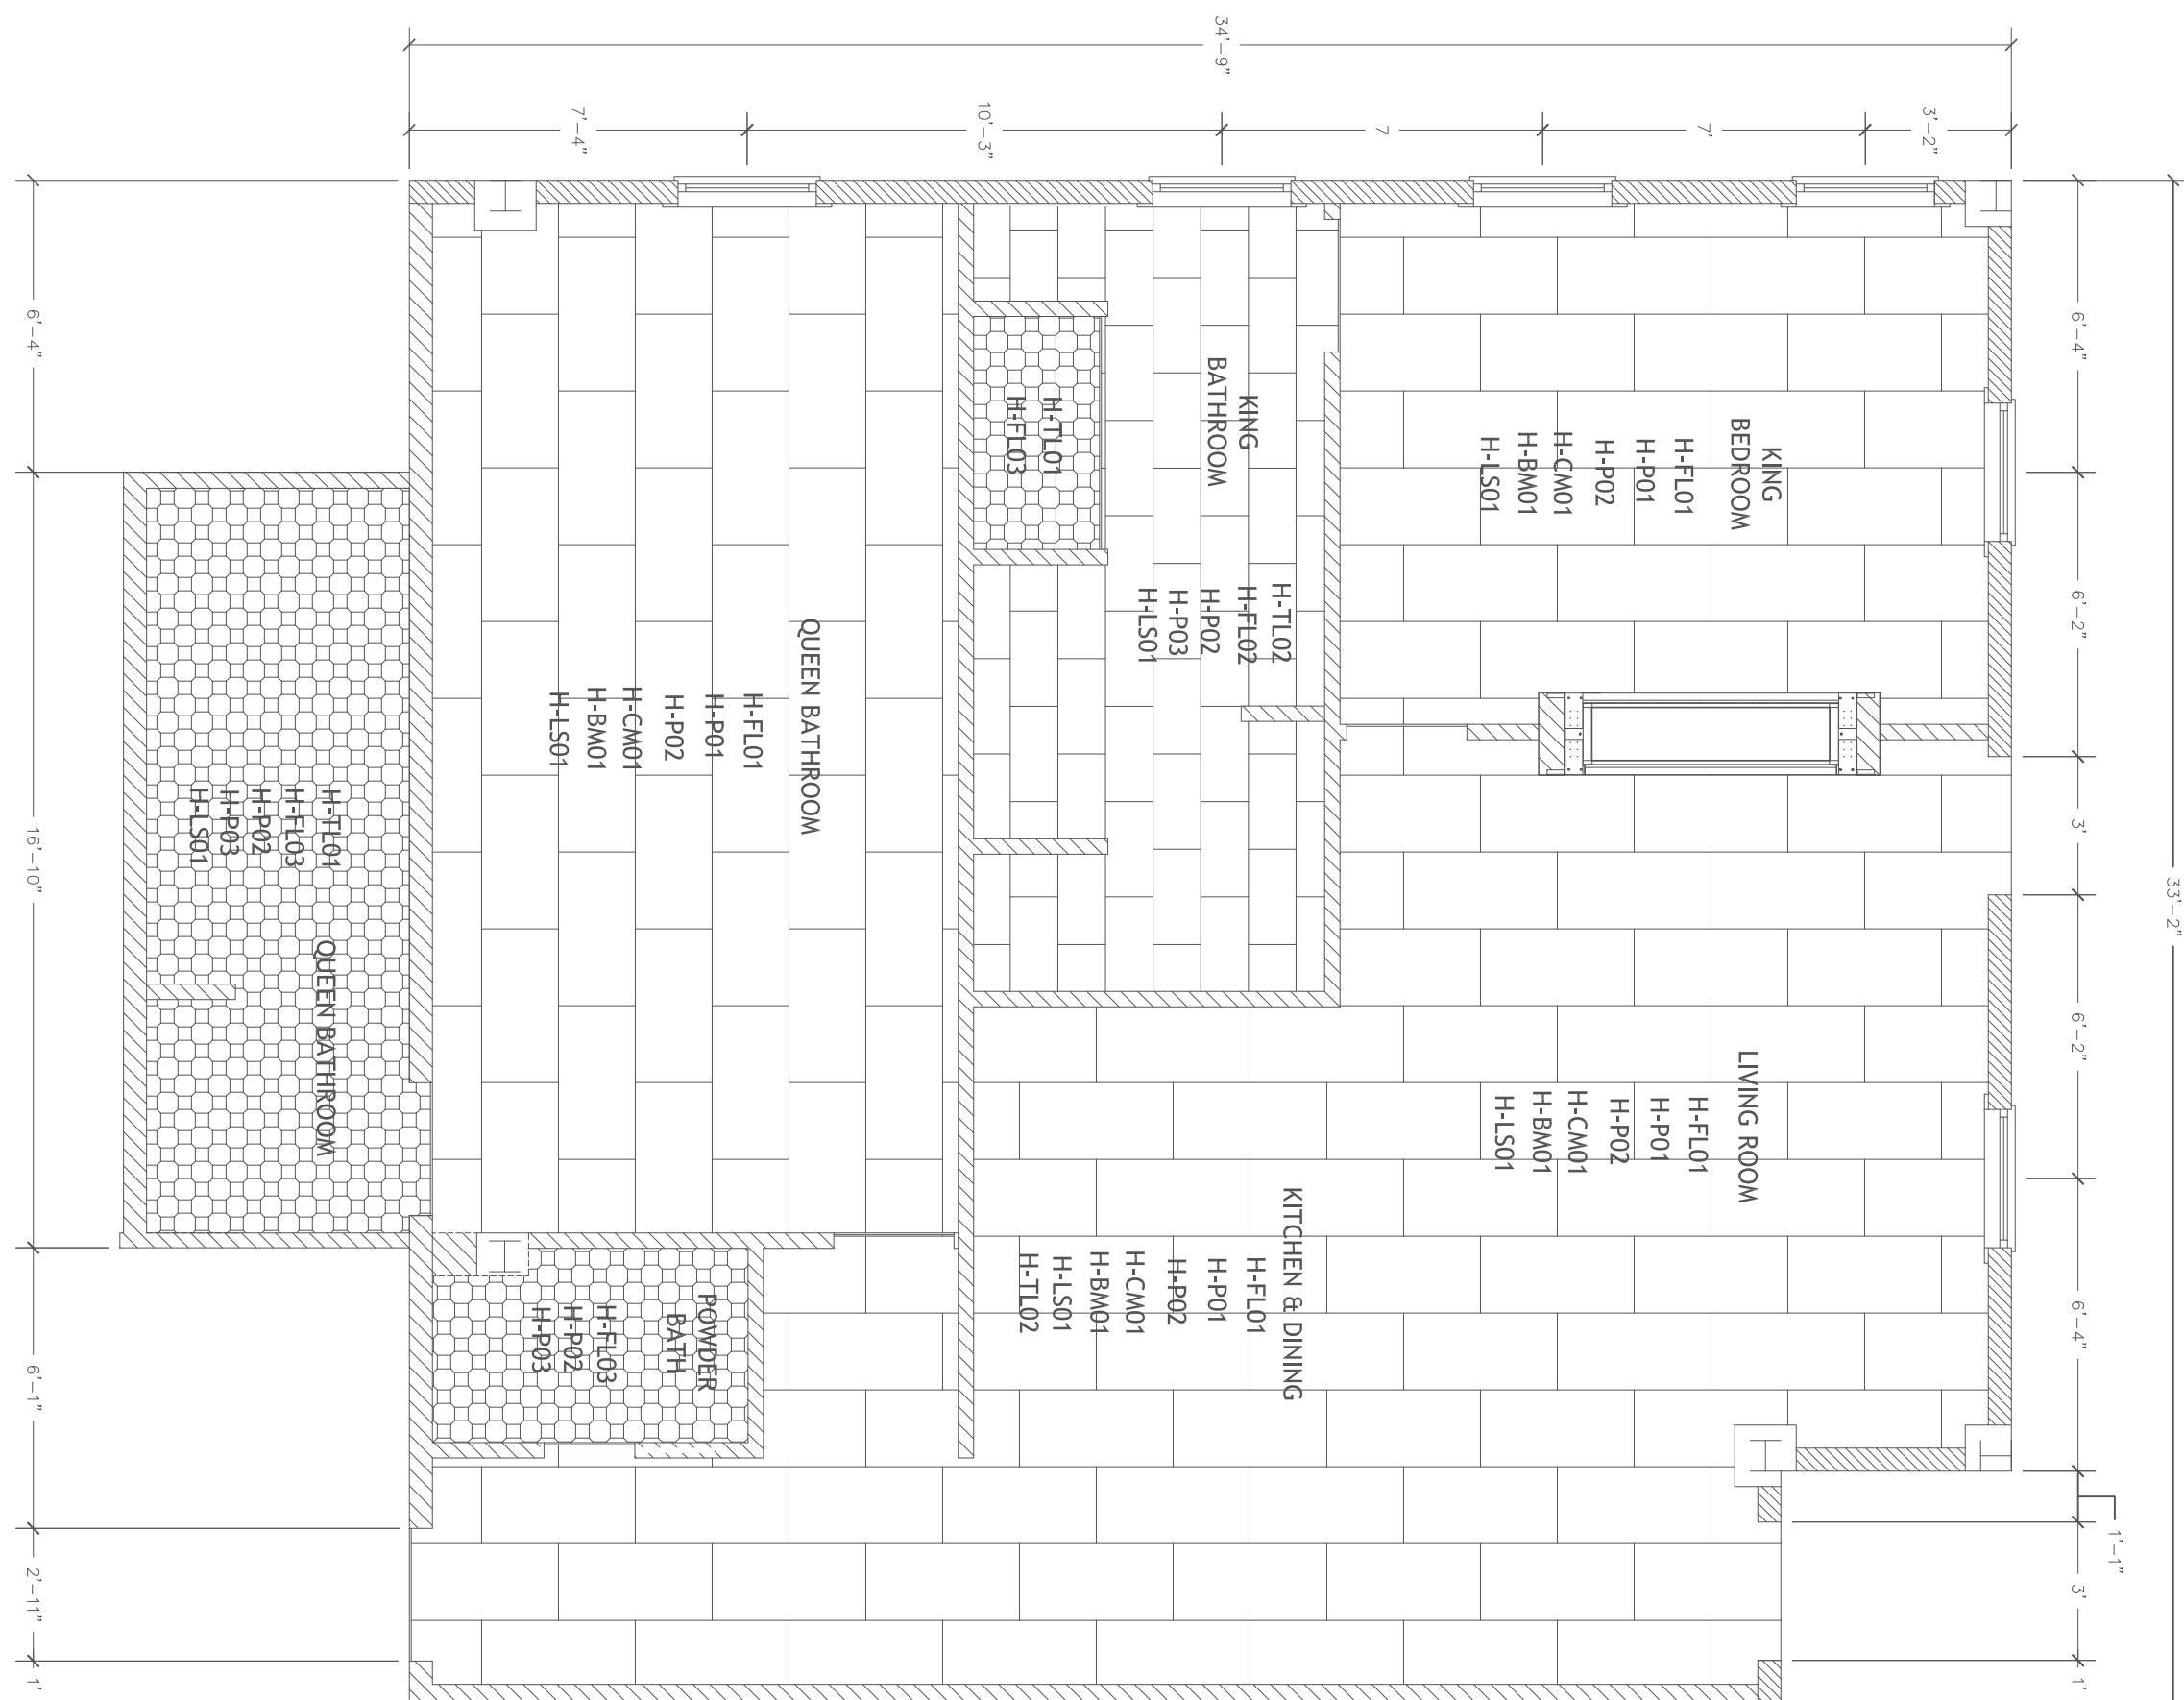


KING SUITE ADA GUESTROOM  
FINISH PLAN  
SCALE: 1/4"=1'-0"

## GALINOIS 123 Ocean Drive, Naxos, Cyclades 32480

### Hospitality Suite Floor Plans / A

Project Number	Date
2000.01	10 April, 2025
Drawn By	Beverly Bradshaw
Checked By	Bethany Blevins
Scale	1/4"=1'-0"

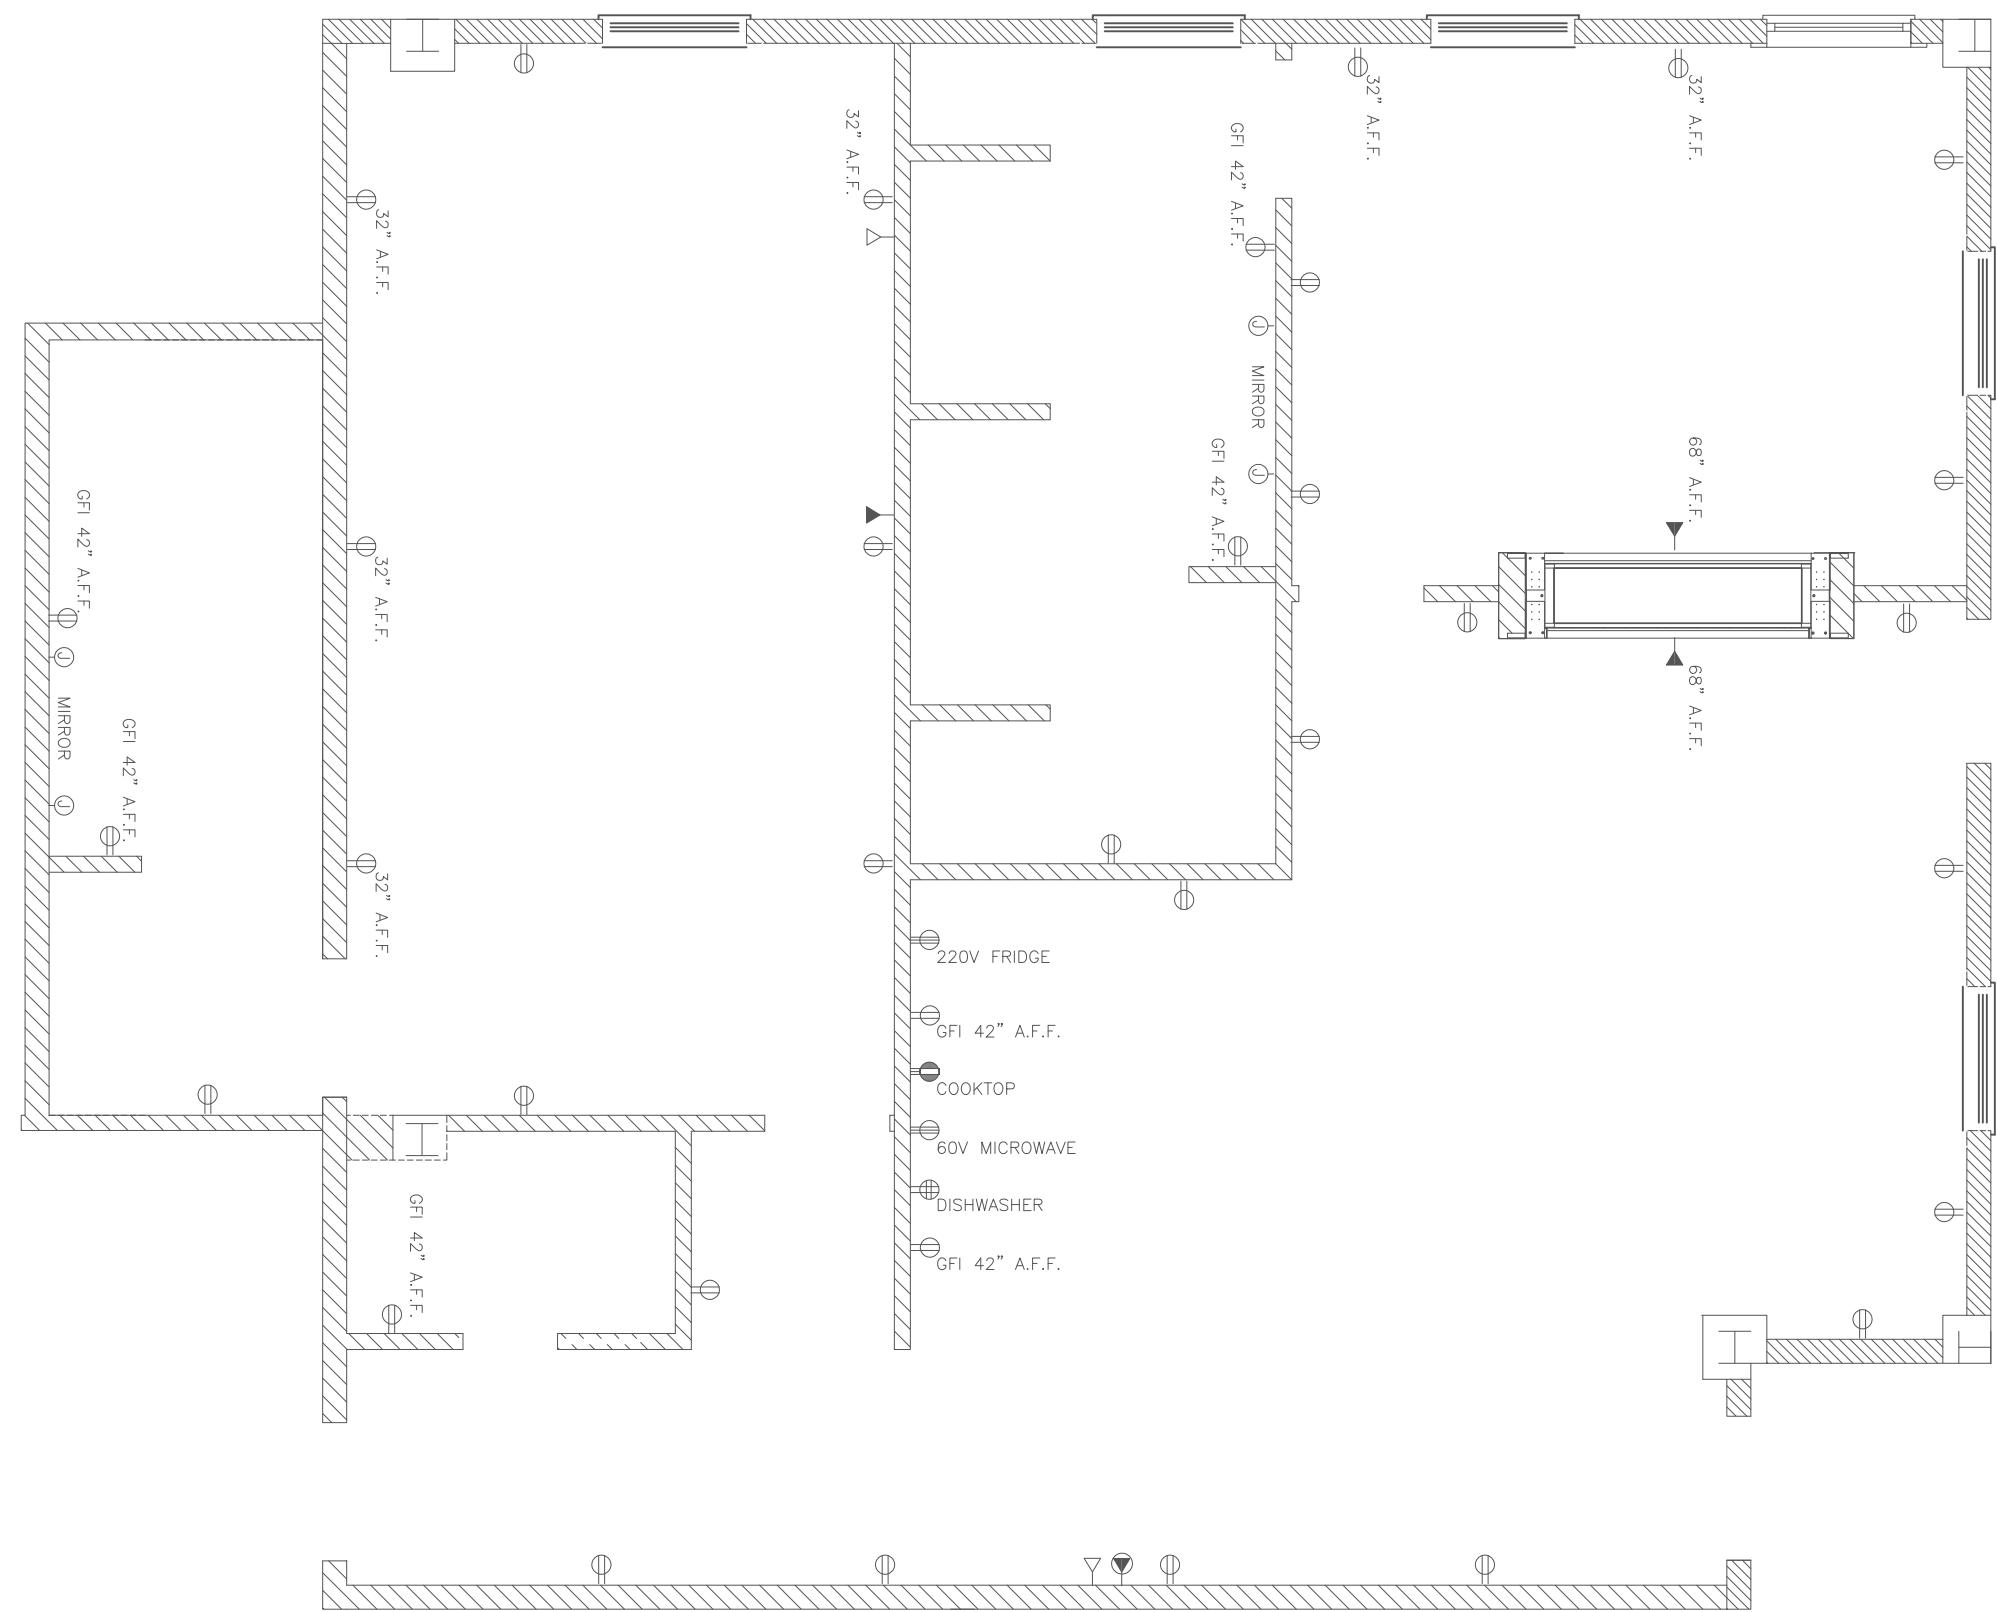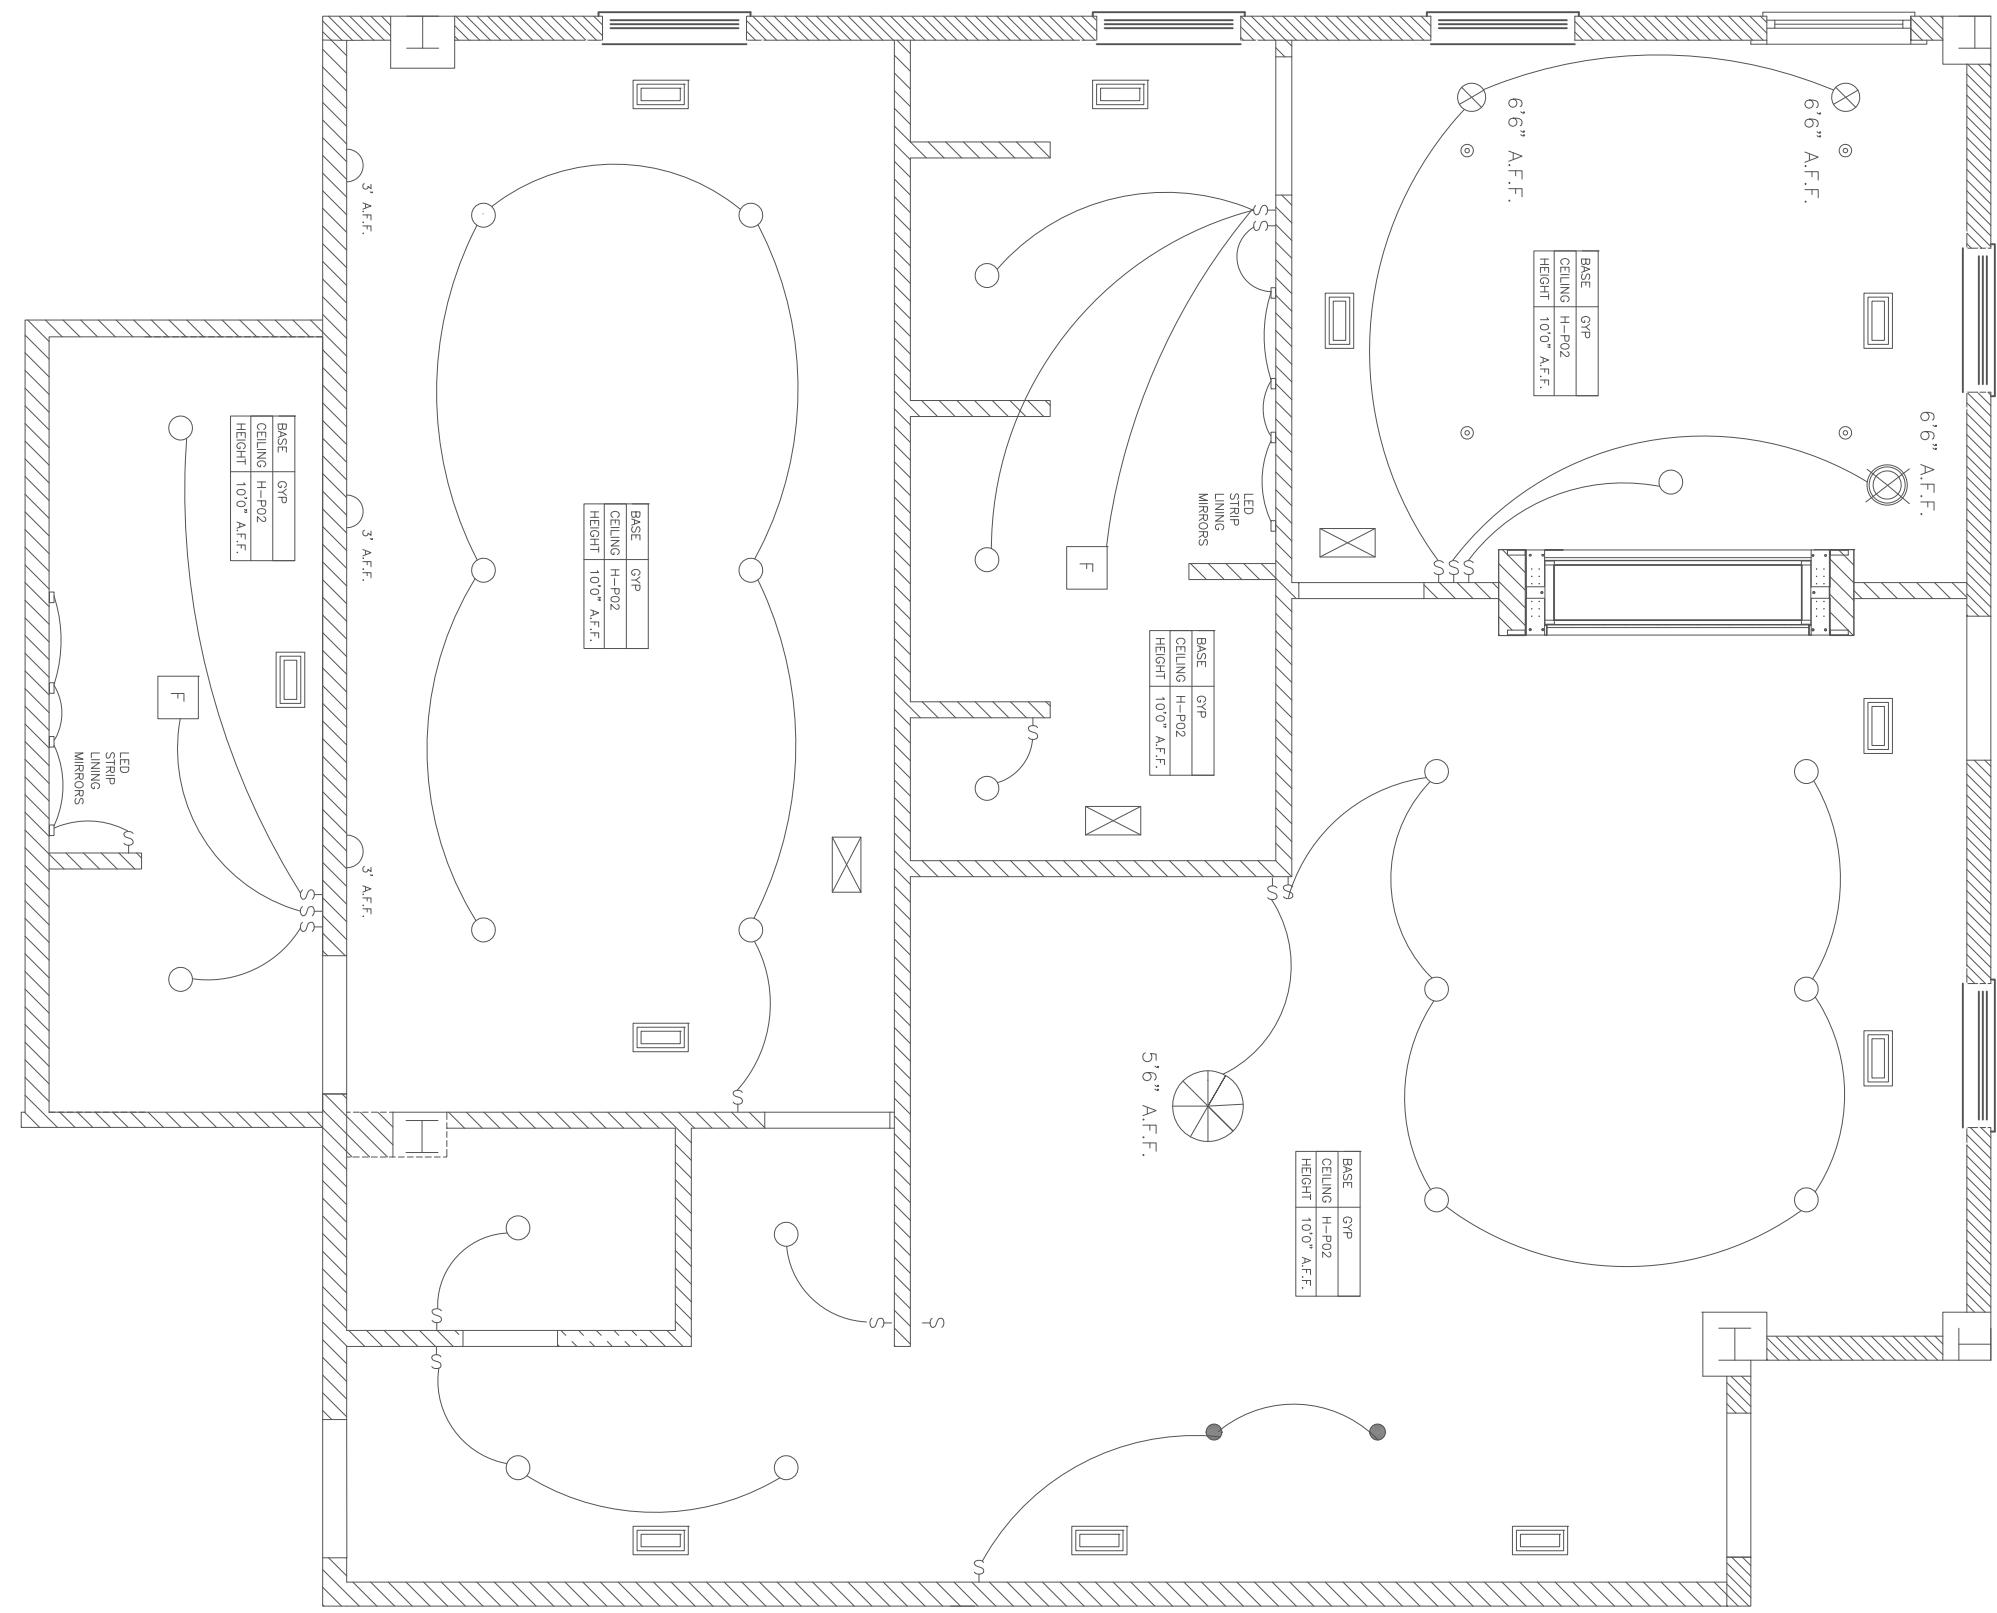

KING SUITE ADA GUESTROOM  
FURNITURE PLAN  
SCALE: 1/4" = 1'-0"

RCP LEGEND			
◎	H-30	HANGING PENDANT LIGHT	
◎	H-32	LARGE HANGING PENDANT	
◎	H-34	6" RECESSED CAN LIGHT	
●	H-35	4" RECESSED CAN LIGHT	
△	H-36	LED STRIP LIGHT	
—	—	FIRE SPRINKLER	
■	—	HVAC SUPPLY VENT	
□	—	HVAC RETURN VENT	
—	—	SWITCH	

ELECTRICAL LEGEND			
○	—	DUPLEX CONVENIENCE OUTLET	
○	○	GFI OUTLET	
○	○	220V OUTLET	
○	○	60V OUTLET	
○	○	JUNCTION BOX	
►	—	TELEPHONE OUTLET	
▼	—	CABLE OUTLET	
●	—	INTERNET OUTLET	
●	—	COOKTOP/RANGE OUTLET	
●	—	DISHWASHER OUTLET	
NOTES: UNLESS OTHERWISE NOTED, ALL OUTLETS ARE 15" A.F.F. STANDARD AND 18" A.F.F. IN ADA ROOMS			


# GALINOIS

## 123 Ocean Drive, Naxos, Cyclades

### 32480

### Hospitality Suite Floor Plans / B

ID 3:08		
Sale	1/4"	= 1'-0"
Drawn By	Beverly Bradshaw	
Checked By	Bethany Bleevins	
Project Number	2000.01	10 April, 2025

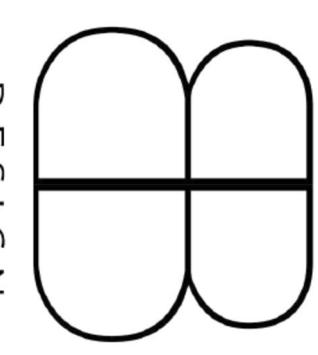

BB DESIGN  
BEVERLY BRADSHAW  
2313 ROSENDALE PLACE  
(334)320-1818  
BCBRADSHAW@CRIMSON.UA.EDU





No. Description Date

**HOSPITALITY SUITE NORTH ELEVATION**  
SCALE: 1/4" = 1'-0"

**HOSPITALITY SUITE WEST ELEVATION**  
SCALE: 1/4" = 1'-0"

**HOSPITALITY SUITE SOUTH ELEVATION**  
SCALE: 1/4" = 1'-0"

**HOSPITALITY SUITE EAST ELEVATION**  
SCALE: 1/4" = 1'-0"

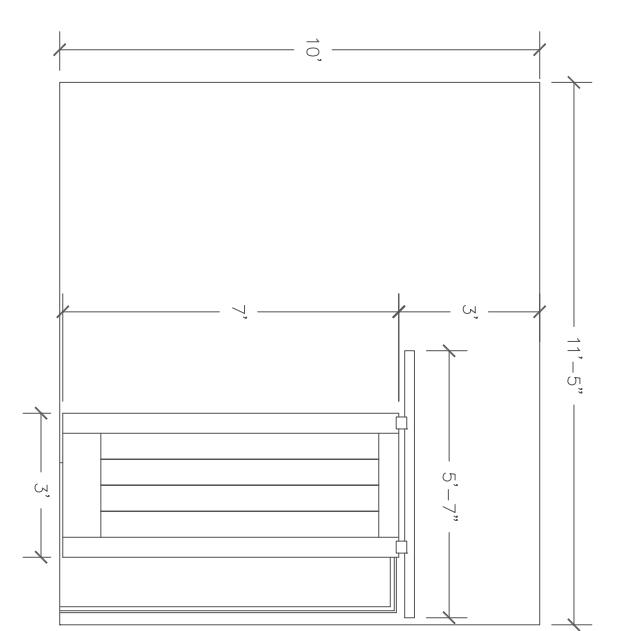
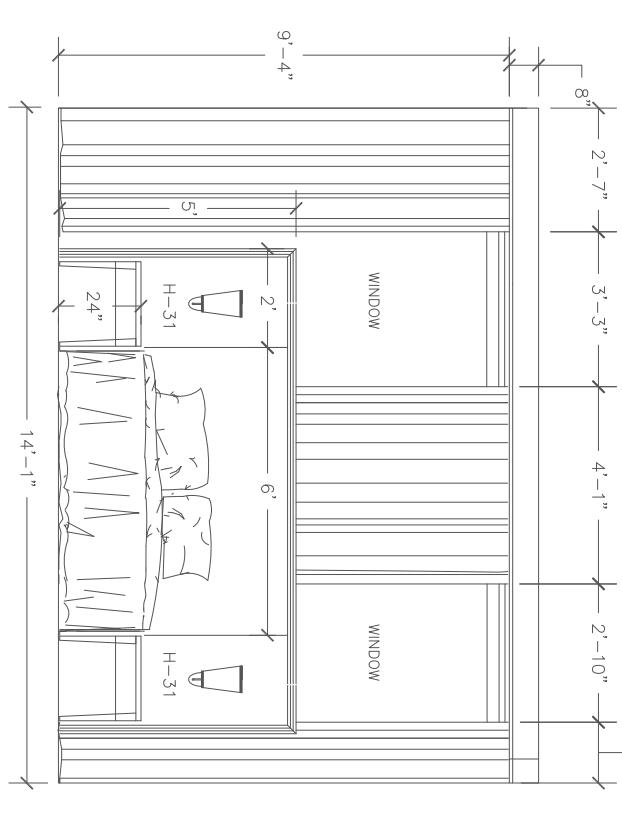
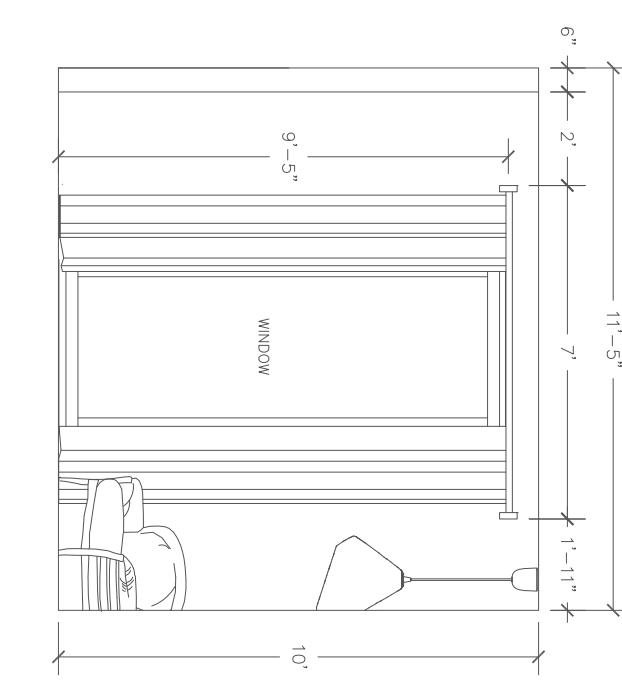
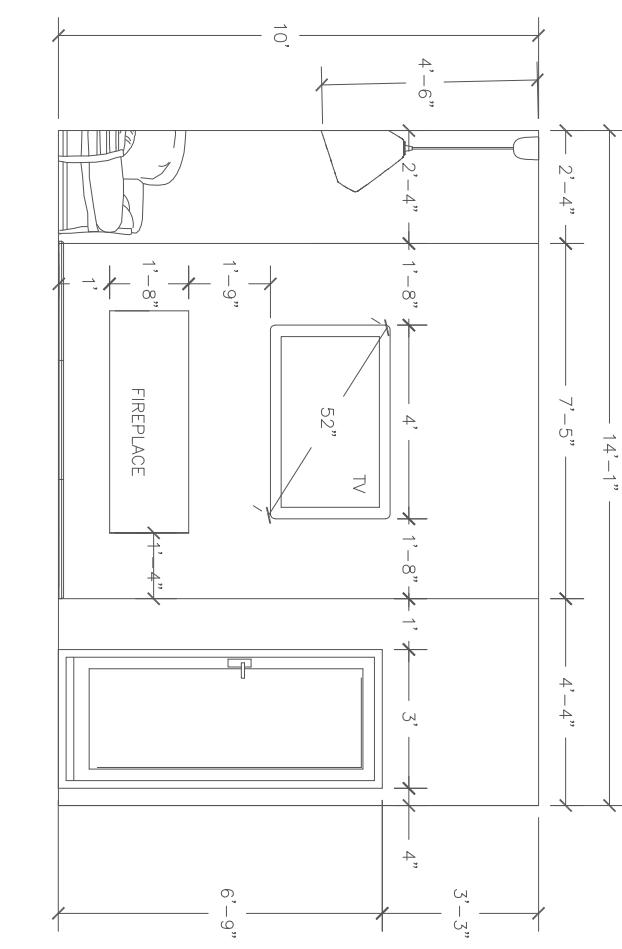


**KING ROOM EAST ELEVATION**  
SCALE: 1/4" = 1'-0"

**KING ROOM NORTH ELEVATION**  
SCALE: 1/4" = 1'-0"

**KING ROOM WEST ELEVATION**  
SCALE: 1/4" = 1'-0"

**KING ROOM SOUTH ELEVATION**  
SCALE: 1/4" = 1'-0"

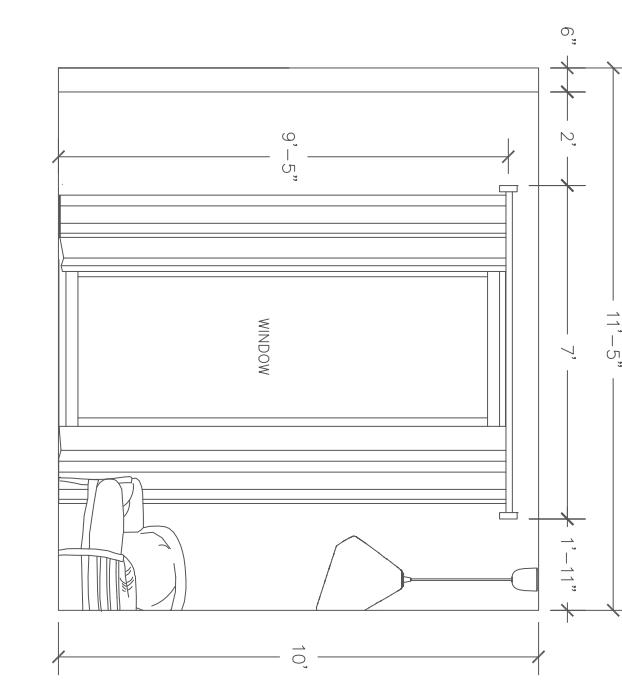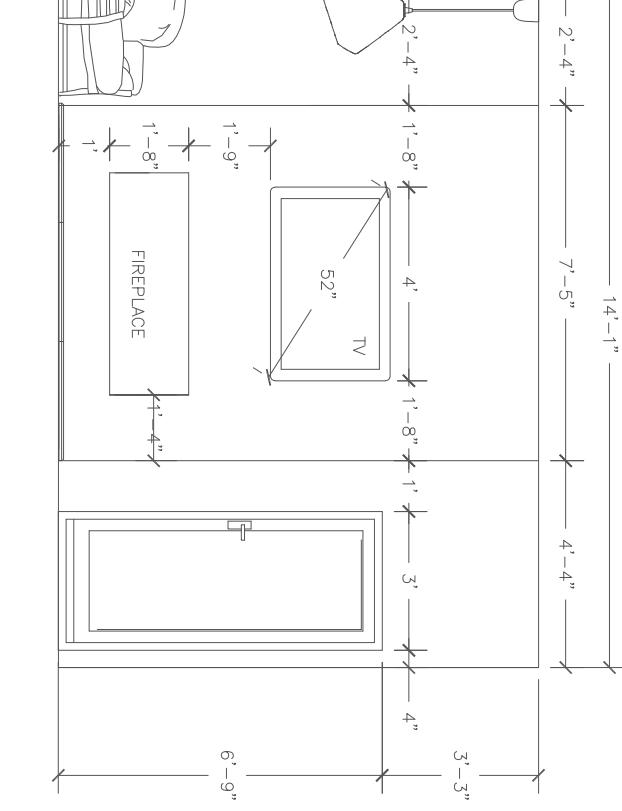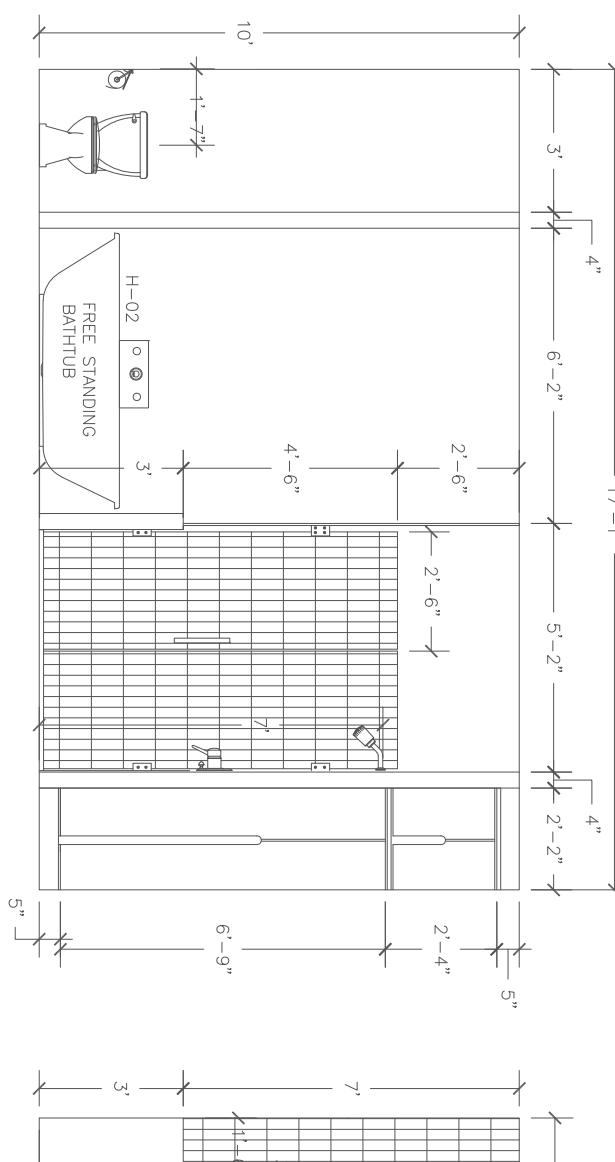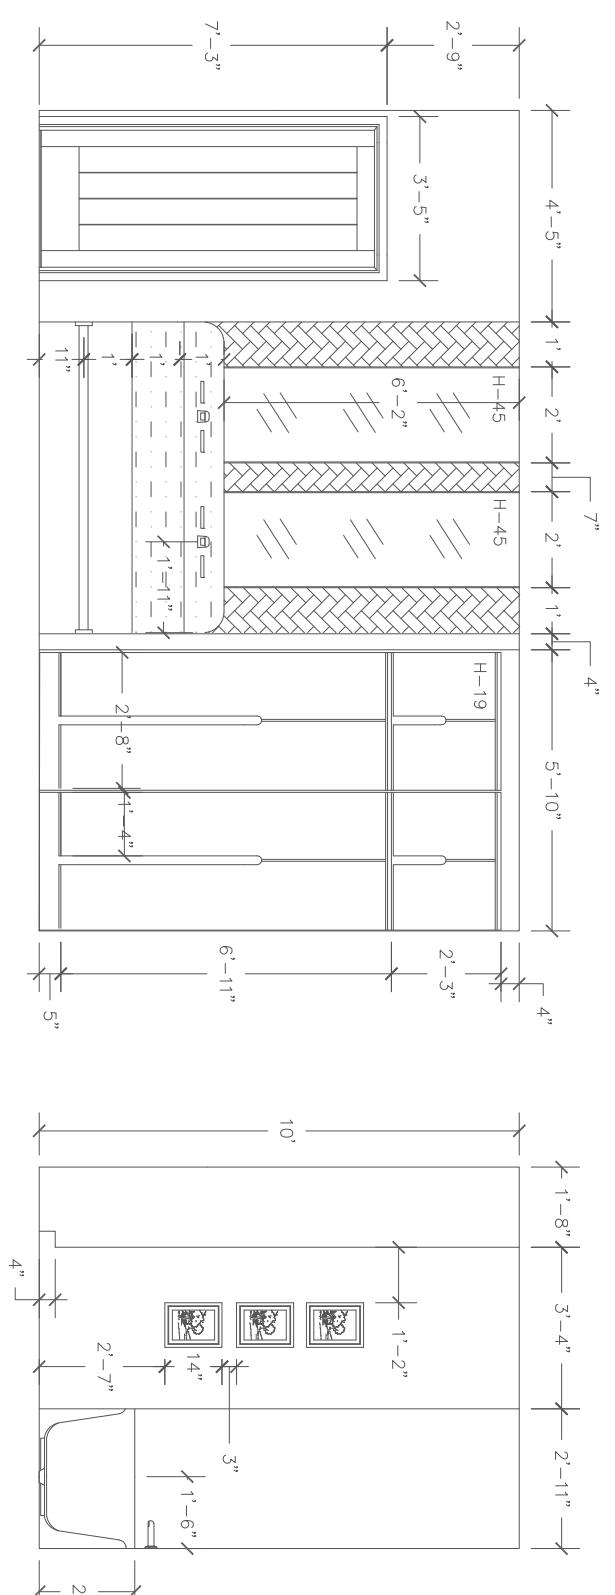

**KING BATH NORTH ELEVATION**  
SCALE: 1/4" = 1'-0"

**KING BATH EAST ELEVATION**  
SCALE: 1/4" = 1'-0"

**KING BATH SOUTH ELEVATION**  
SCALE: 1/4" = 1'-0"

**KING BATH WEST ELEVATION**  
SCALE: 1/4" = 1'-0"

## GALINOIS

123 Ocean Drive,  
Naxos, Cyclades  
32480

### Hospitality Suite Elevations

Project Number 2000.01


Drawn By 10 April, 2025

Checked By Beverly Bradshaw

Bethany Bleevins


Scale

$\frac{1}{4}$ " = 1'-0"

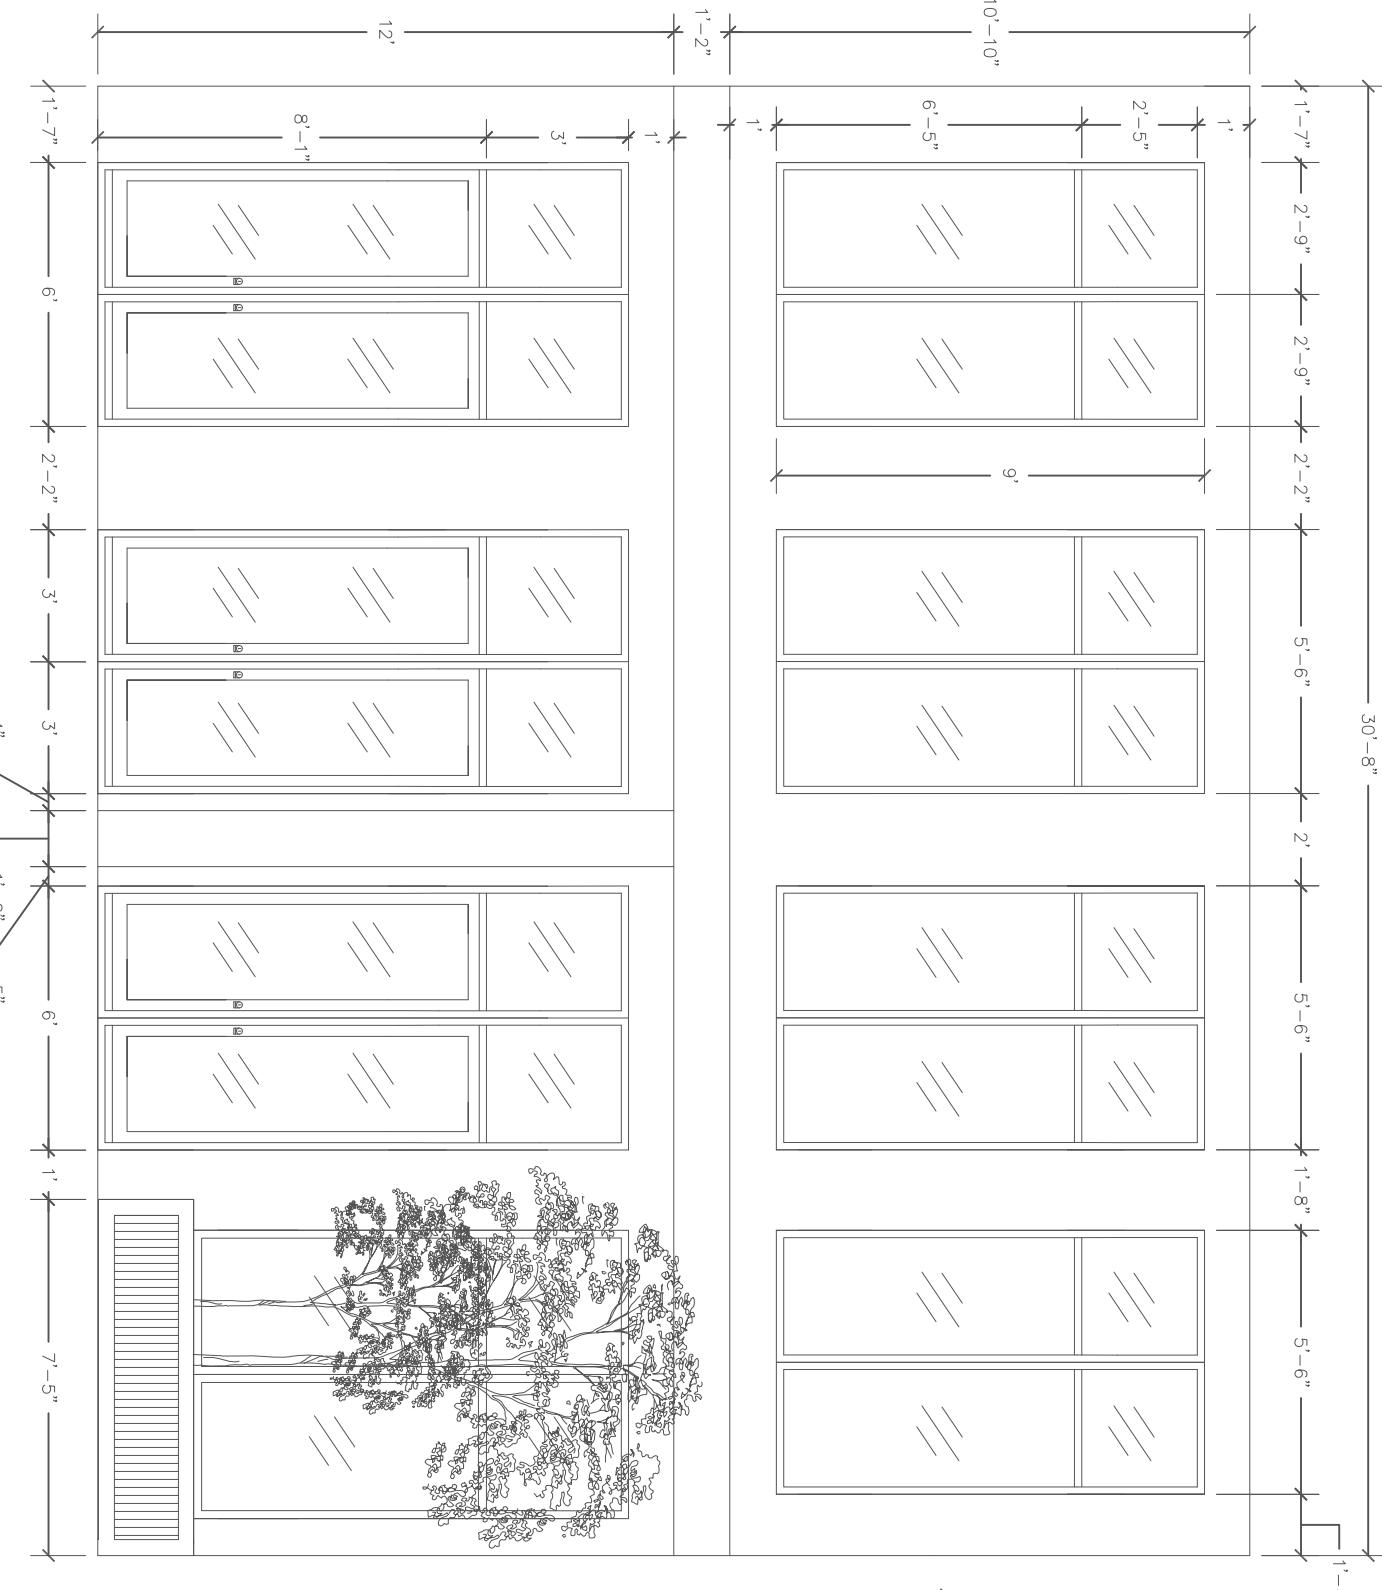


3 LOBBY FOYER SOUTH ELEVATION

SCALE: 1/4"=1'-0"

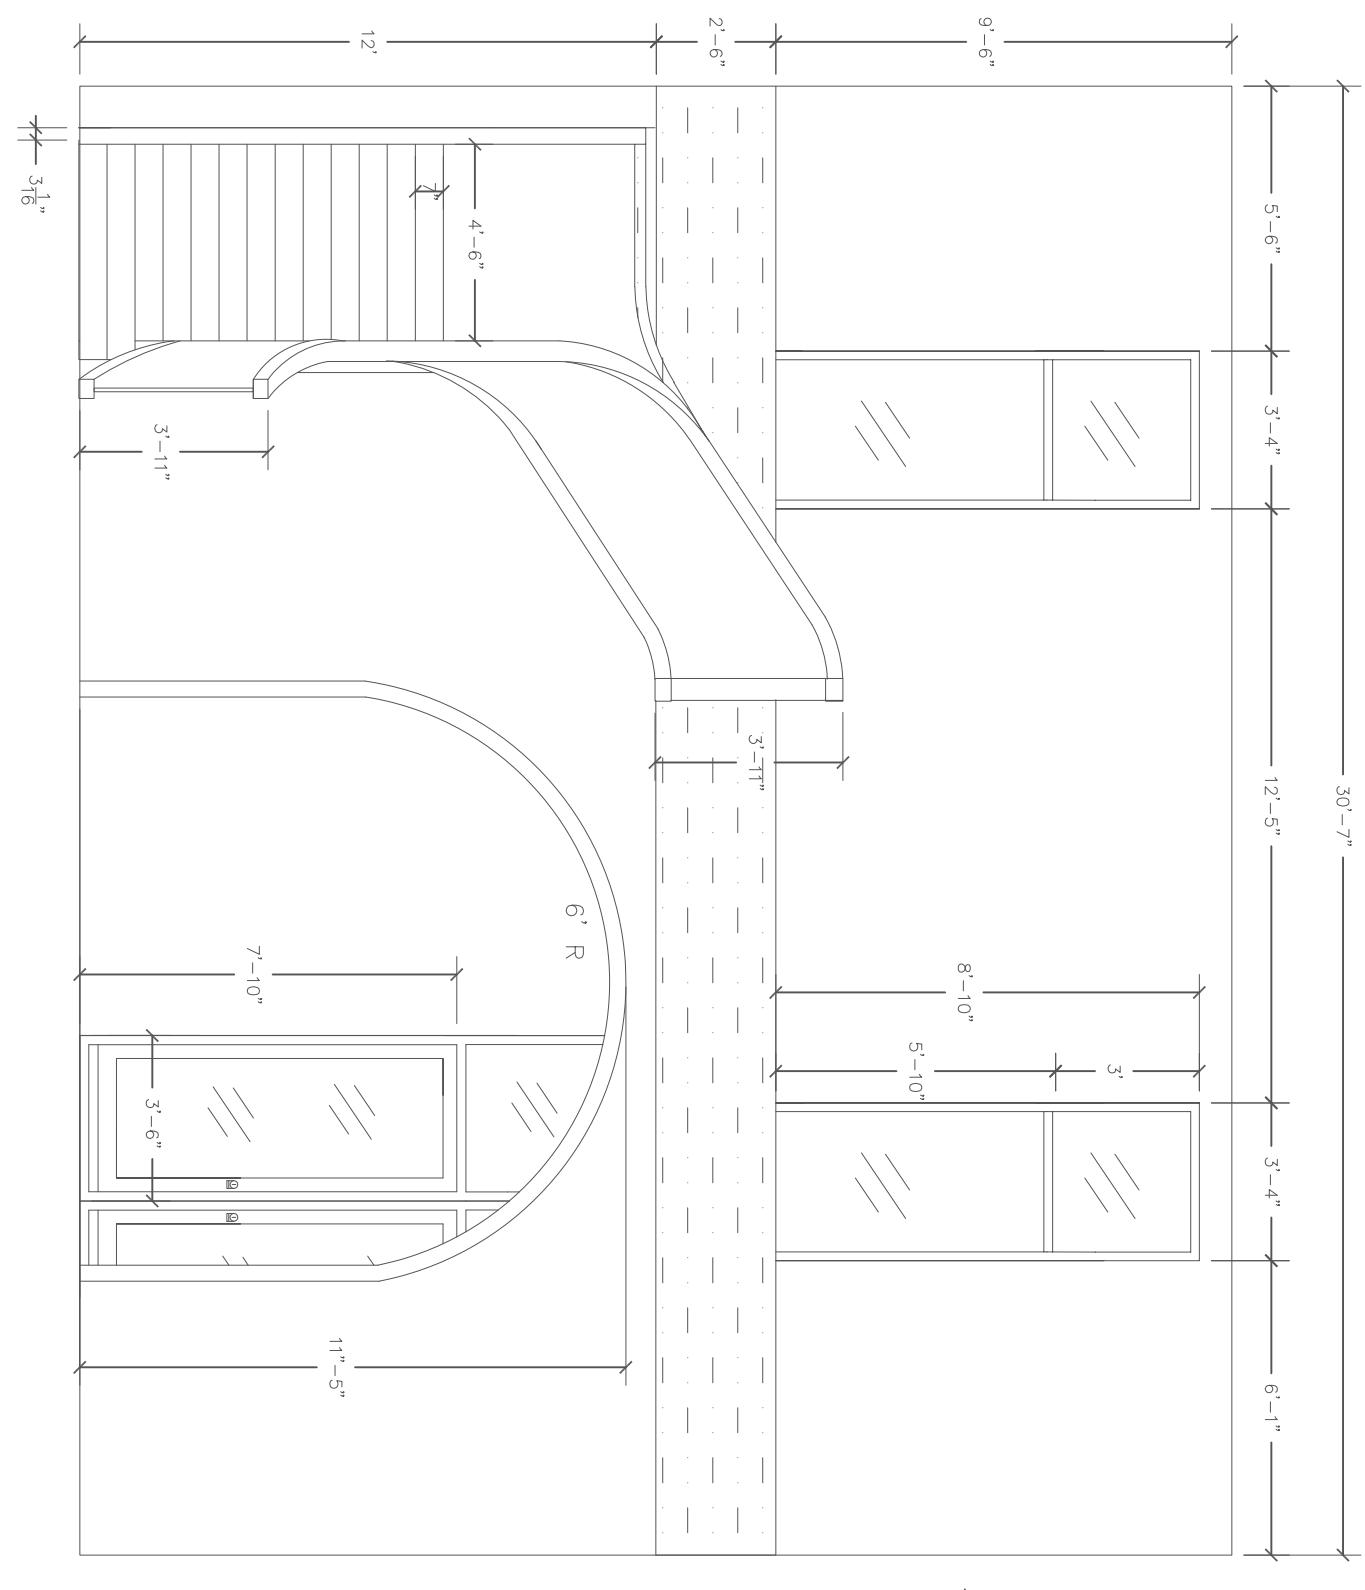


1 LOBBY FOYER NORTH ELEVATION

SCALE: 1/4"=1'-0"

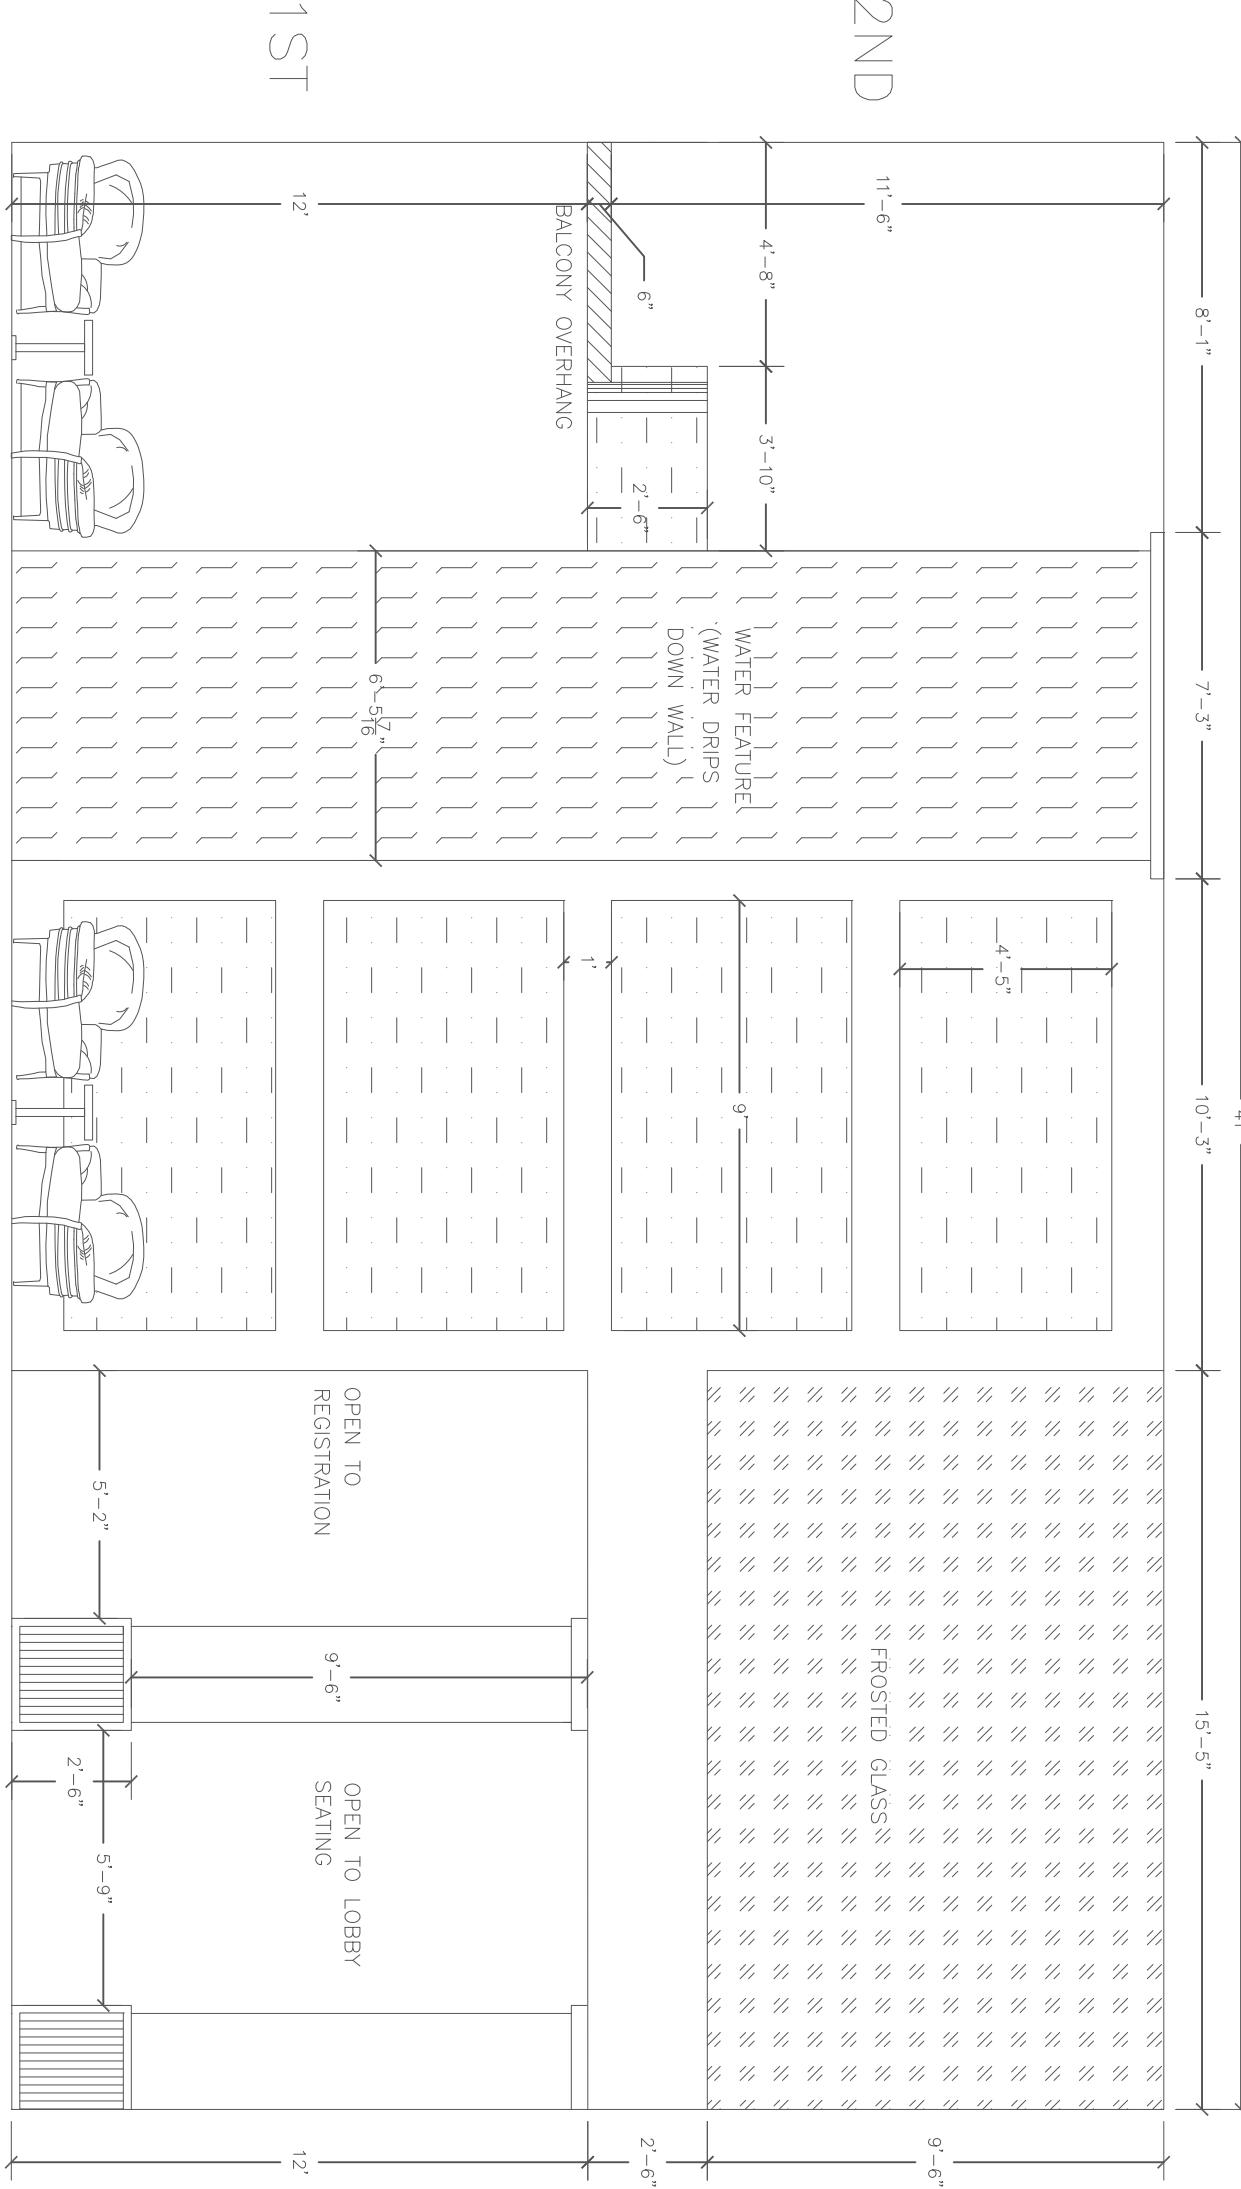


4 LOBBY FOYER EAST ELEVATION

SCALE: 1/4"=1'-0"

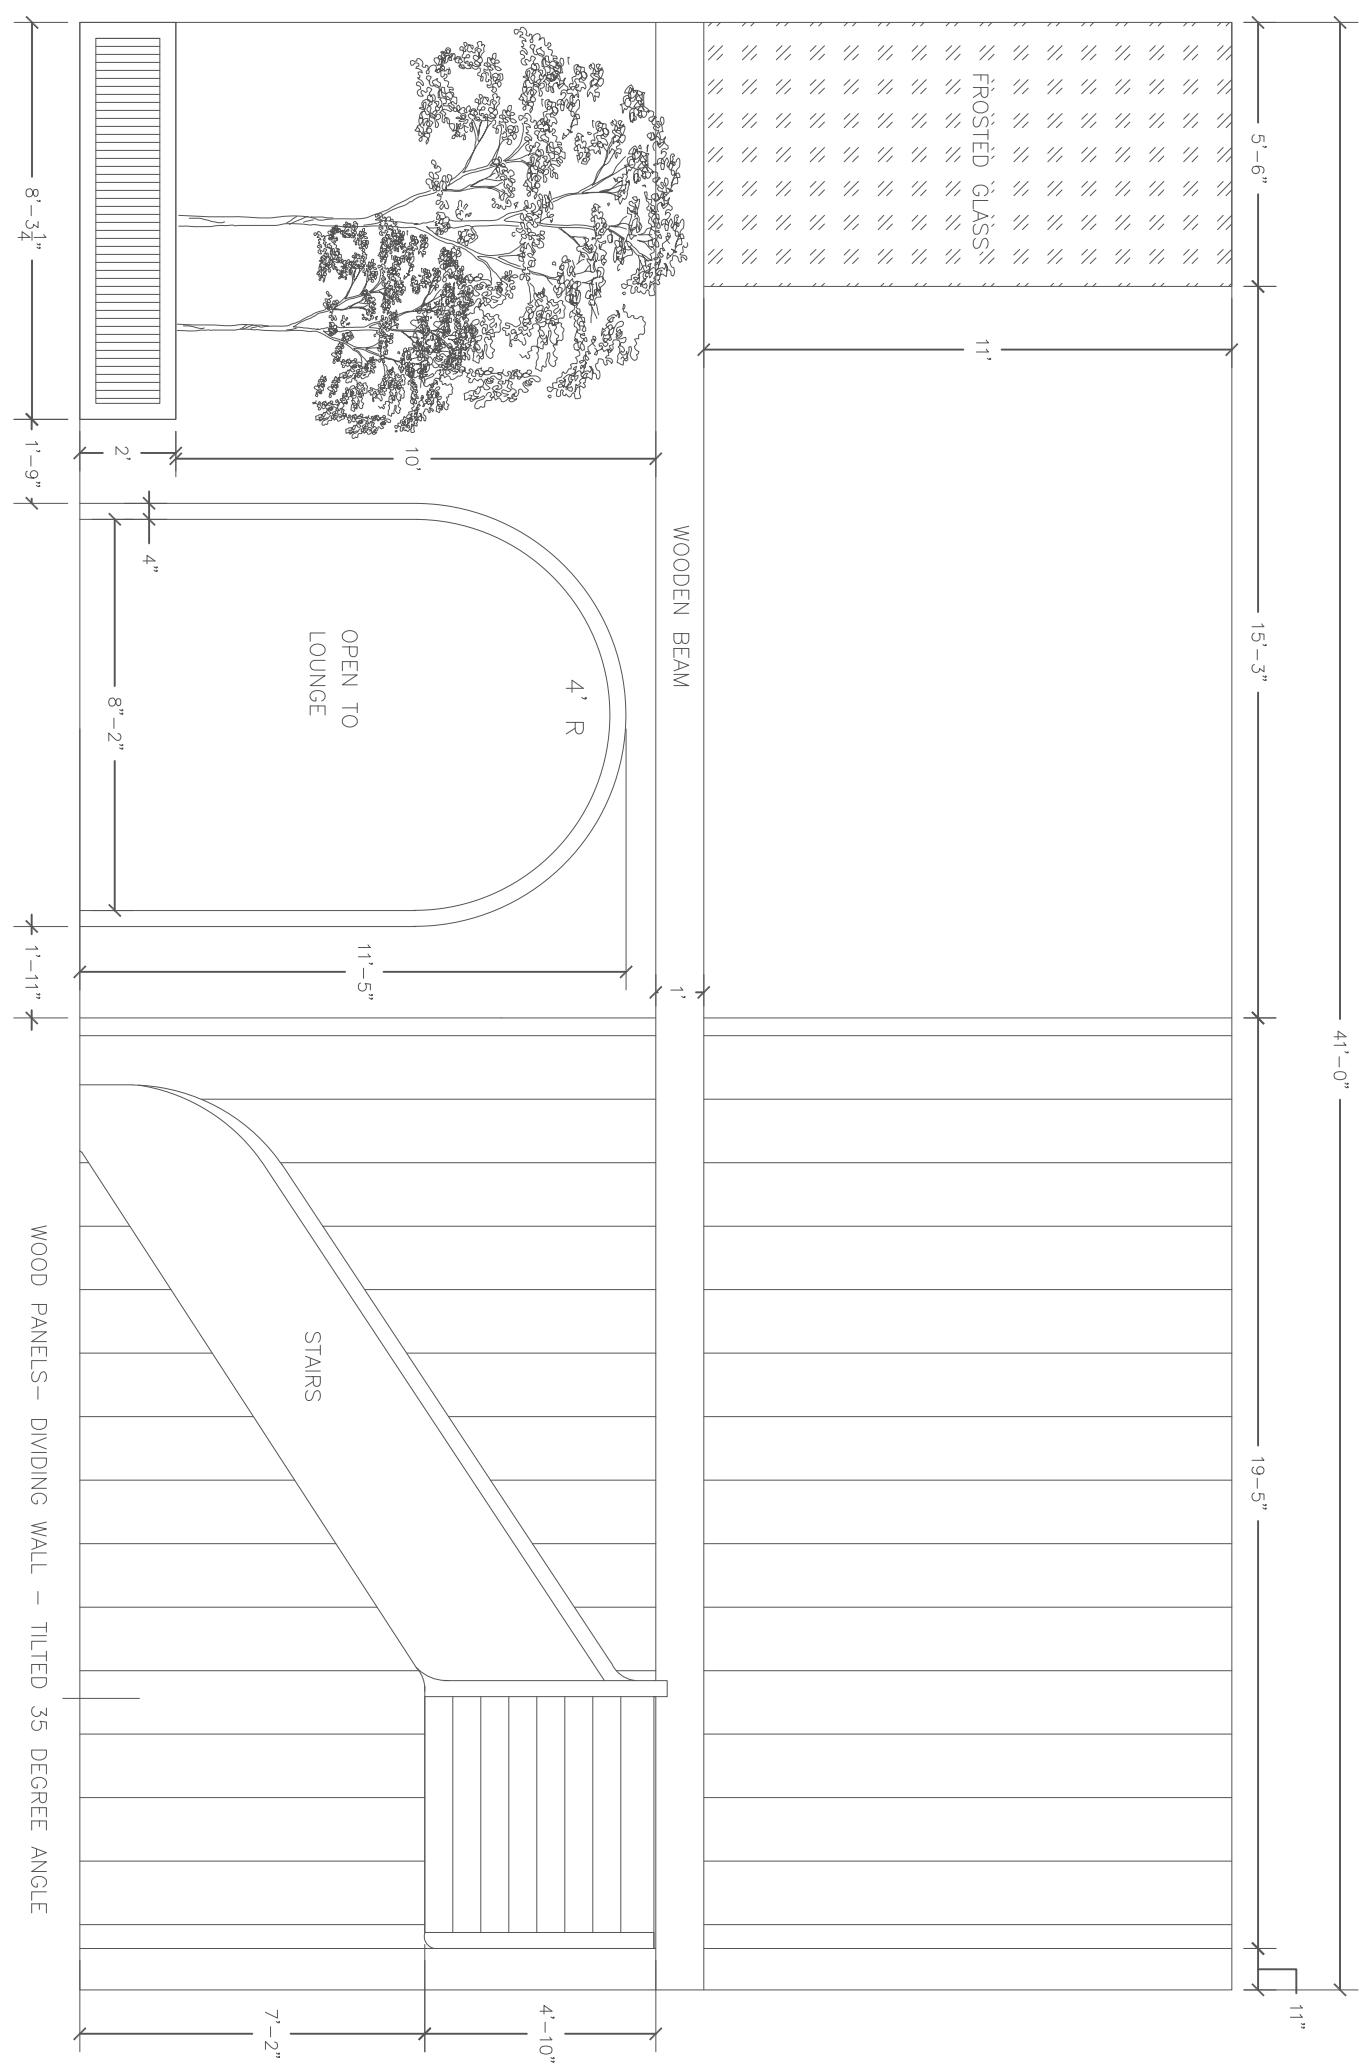

NOTES:

1. CEILING HEIGHT: 24'
2. LOBBY FOYER IS OPEN TO THE 2ND FLOOR. THE 2ND FLOOR CEILING IS THE CEILING.

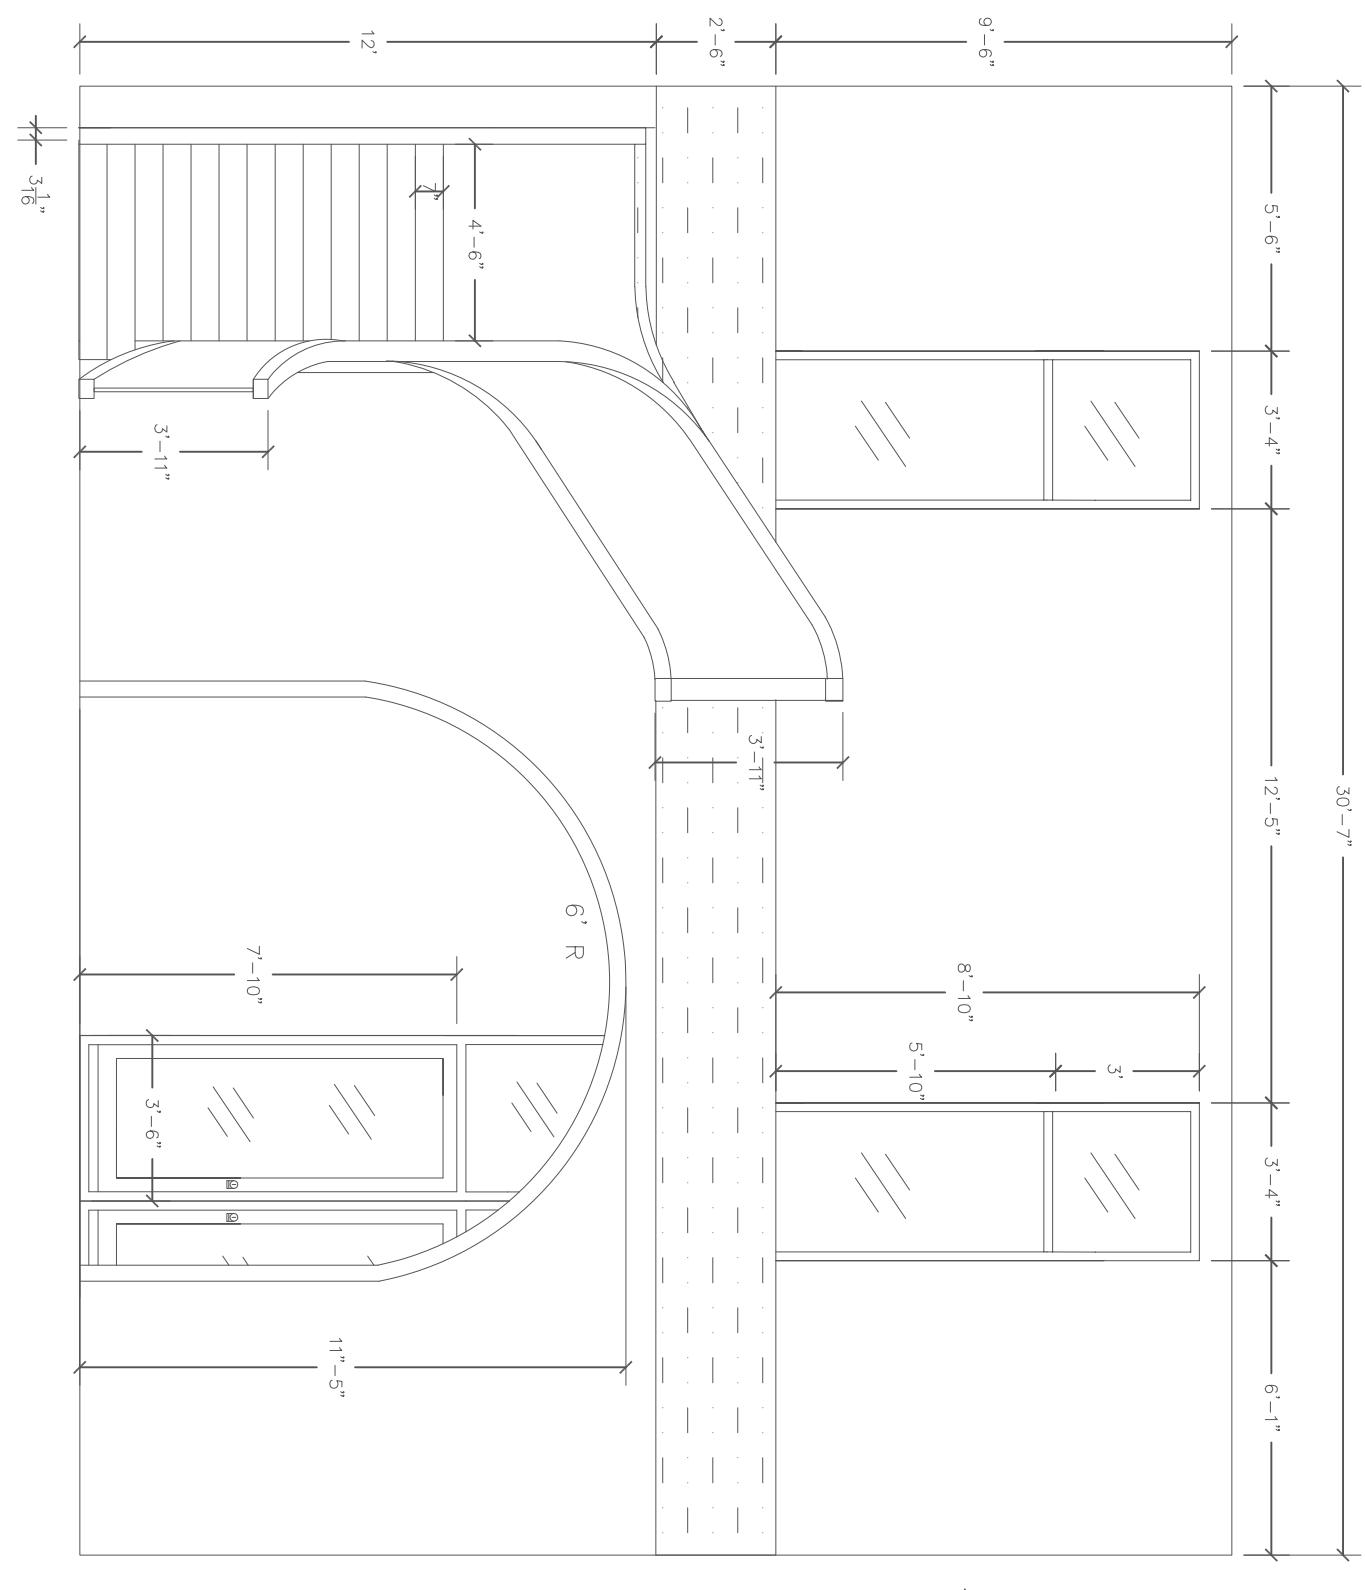

2 LOBBY FOYER WEST ELEVATION

SCALE: 1/4"=1'-0"

**GALINOS**  
123 Ocean Drive,  
Naxos, Cyclades  
32480

## Lobby Elevations

**ID4:00**

Scale

$\frac{1}{4}$ "=1'-0"

Project Number 2000.01

10 April, 2025


Beverly Bradshaw


Checked By

Bethany Bleevins

BB DESIGN  
BEVERLY BRADSHAW  
2313 ROSEMONT PLACE  
(334)320-1818  
BCBRADSHAW@CRIMSON.UA.EDU

UNIVERSITY OF ALABAMA - INTERIOR DESIGN

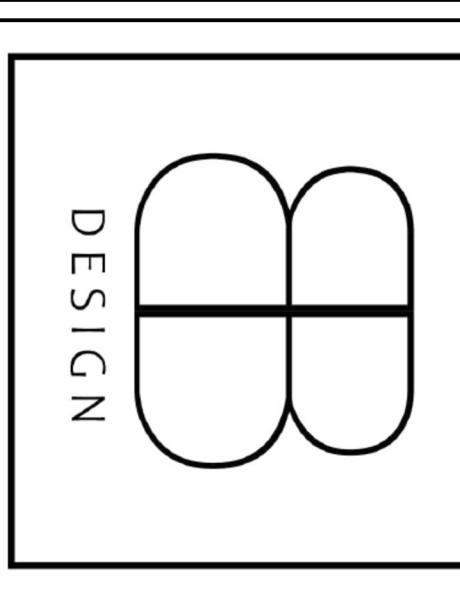






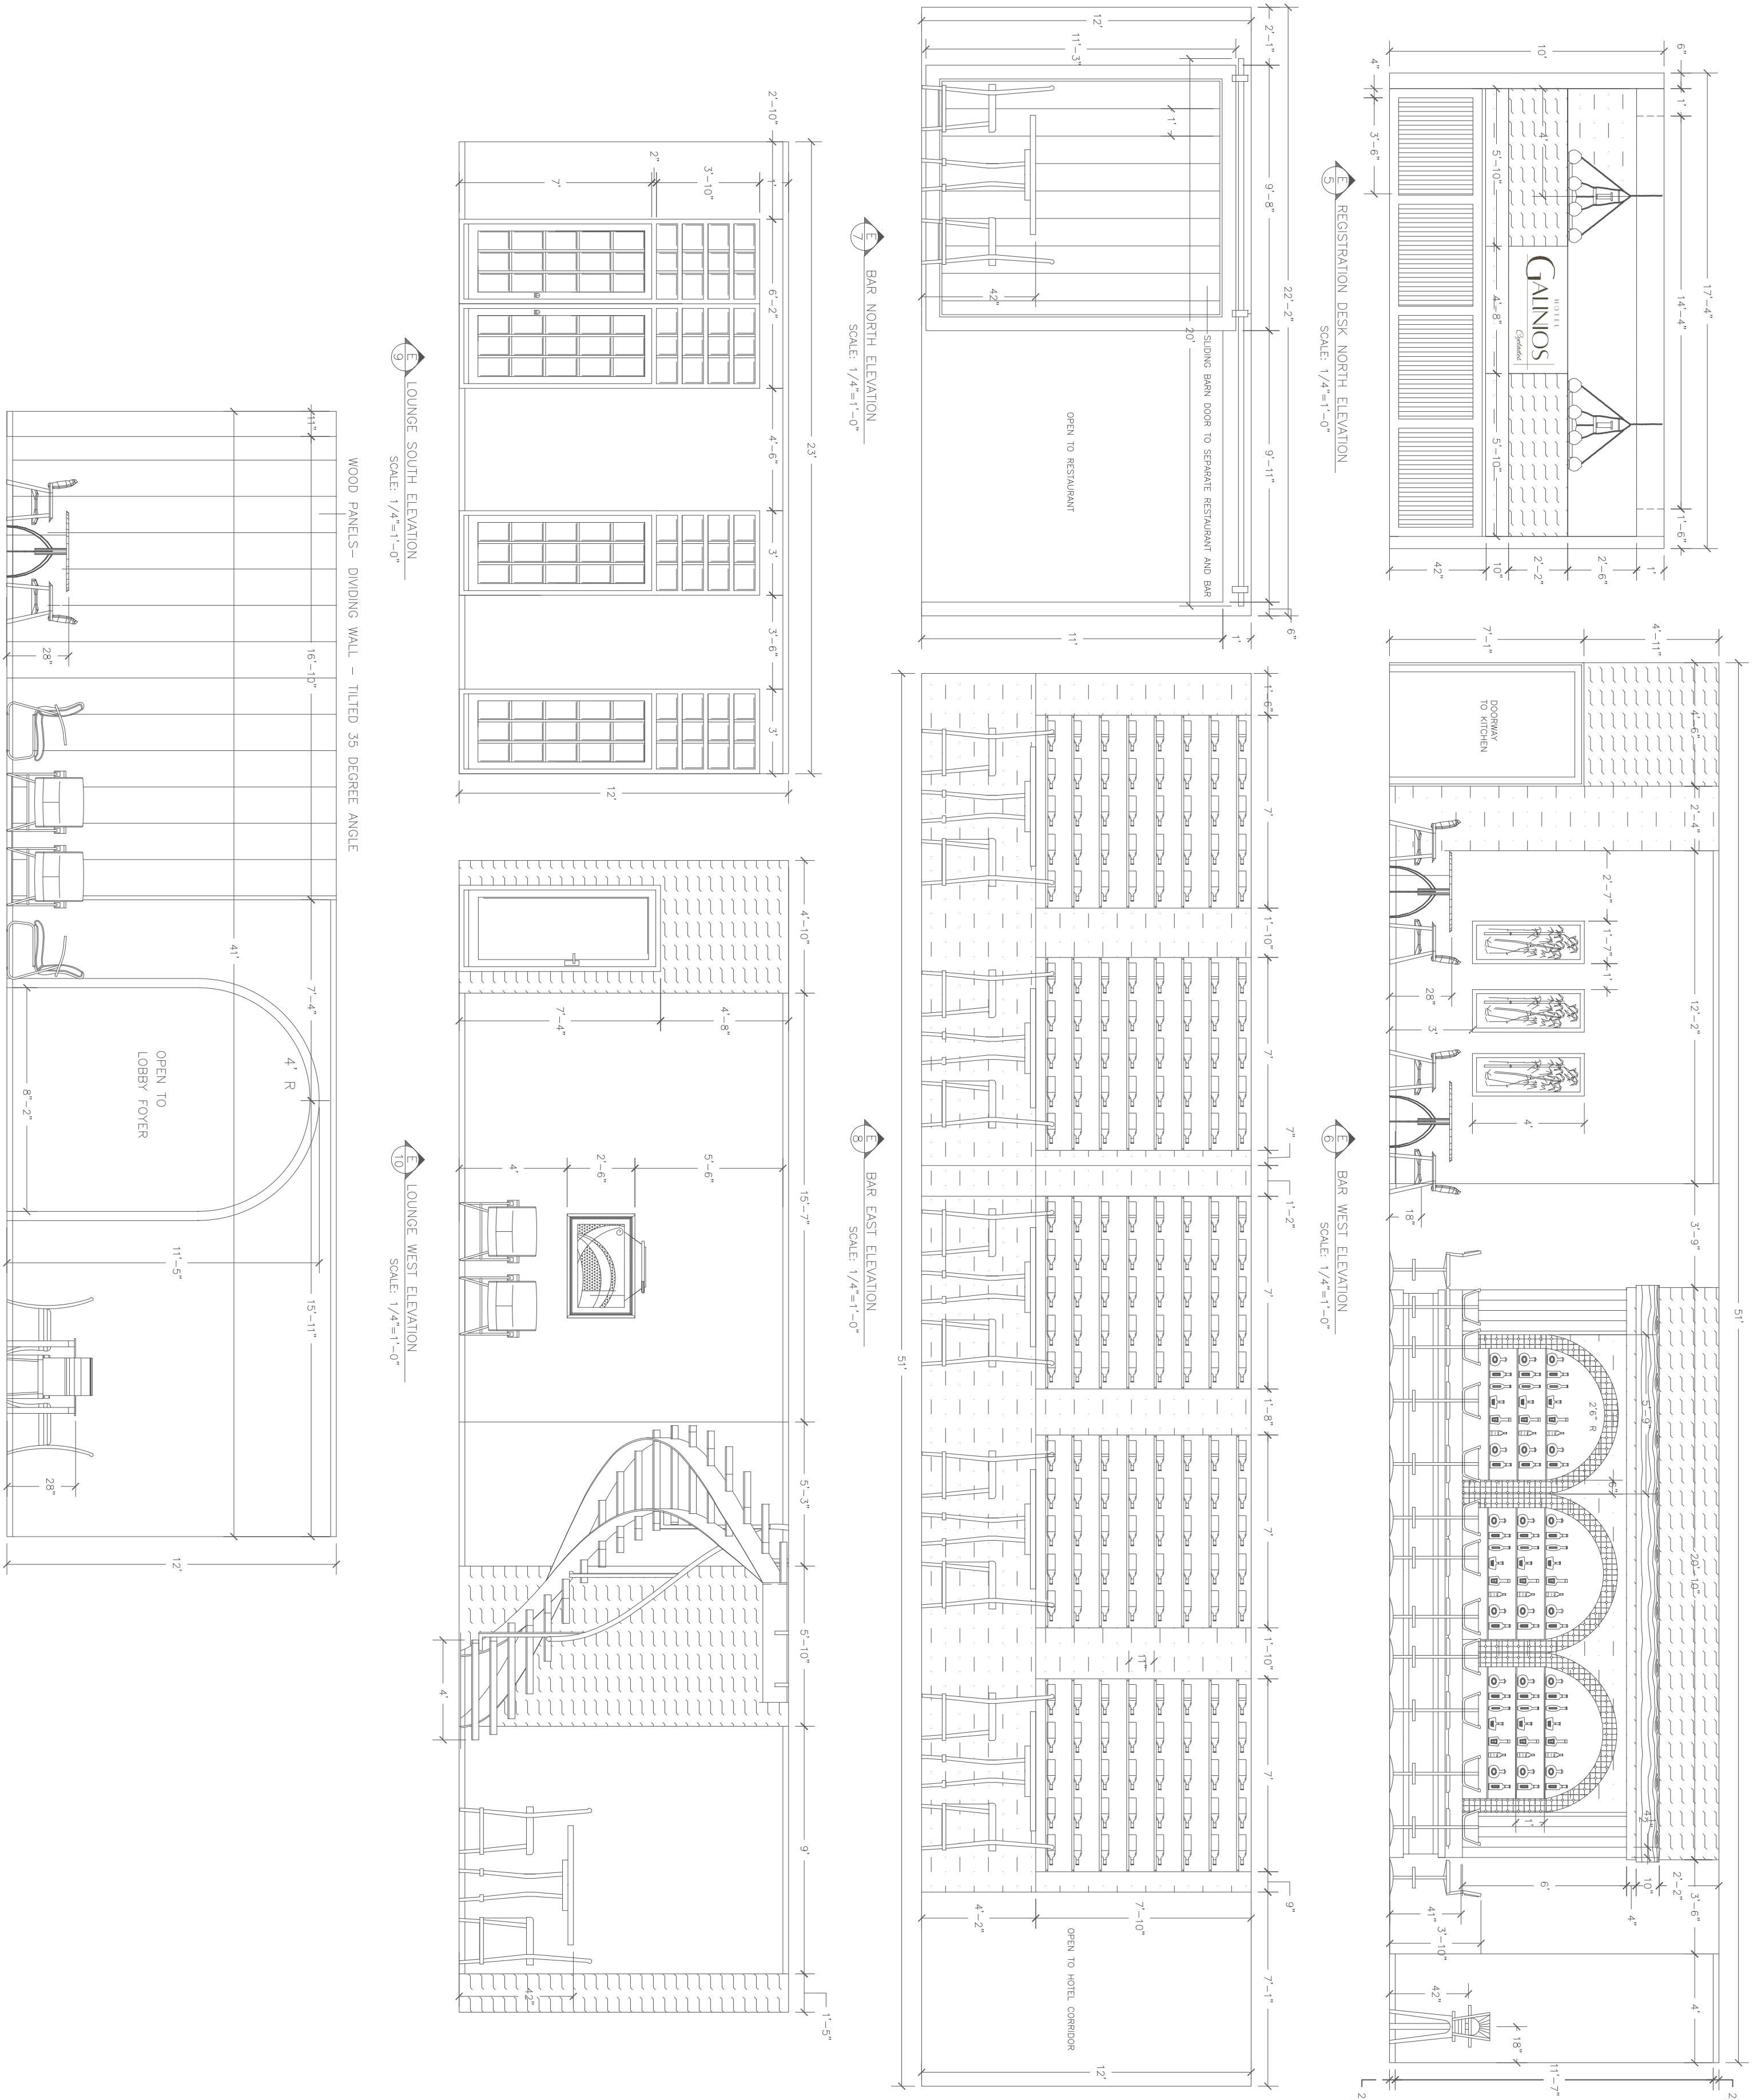


Project Number 2000.01  
Drawn By Beverly Bradshaw  
Checked By Bethany Blevins

**ID4:01**

Scale

$\frac{1}{4}$ "=1'-0"

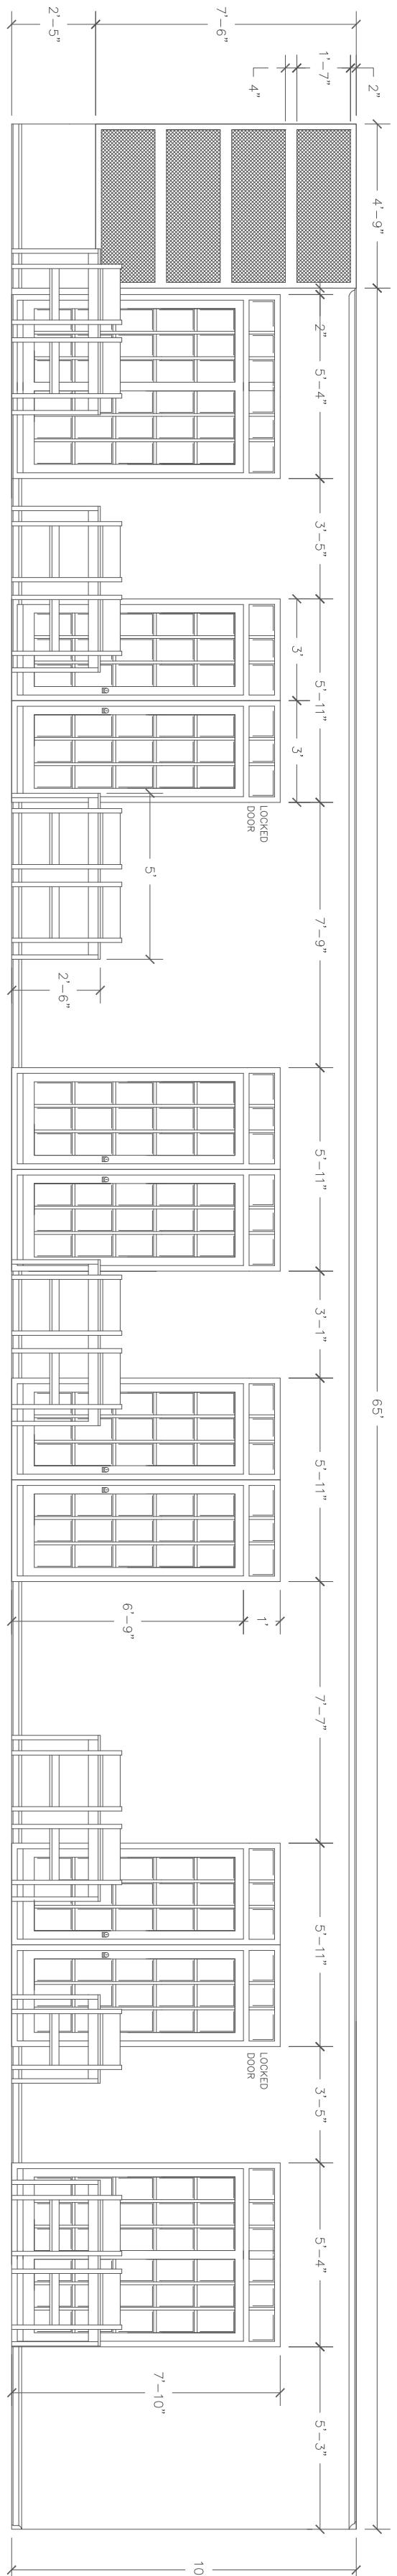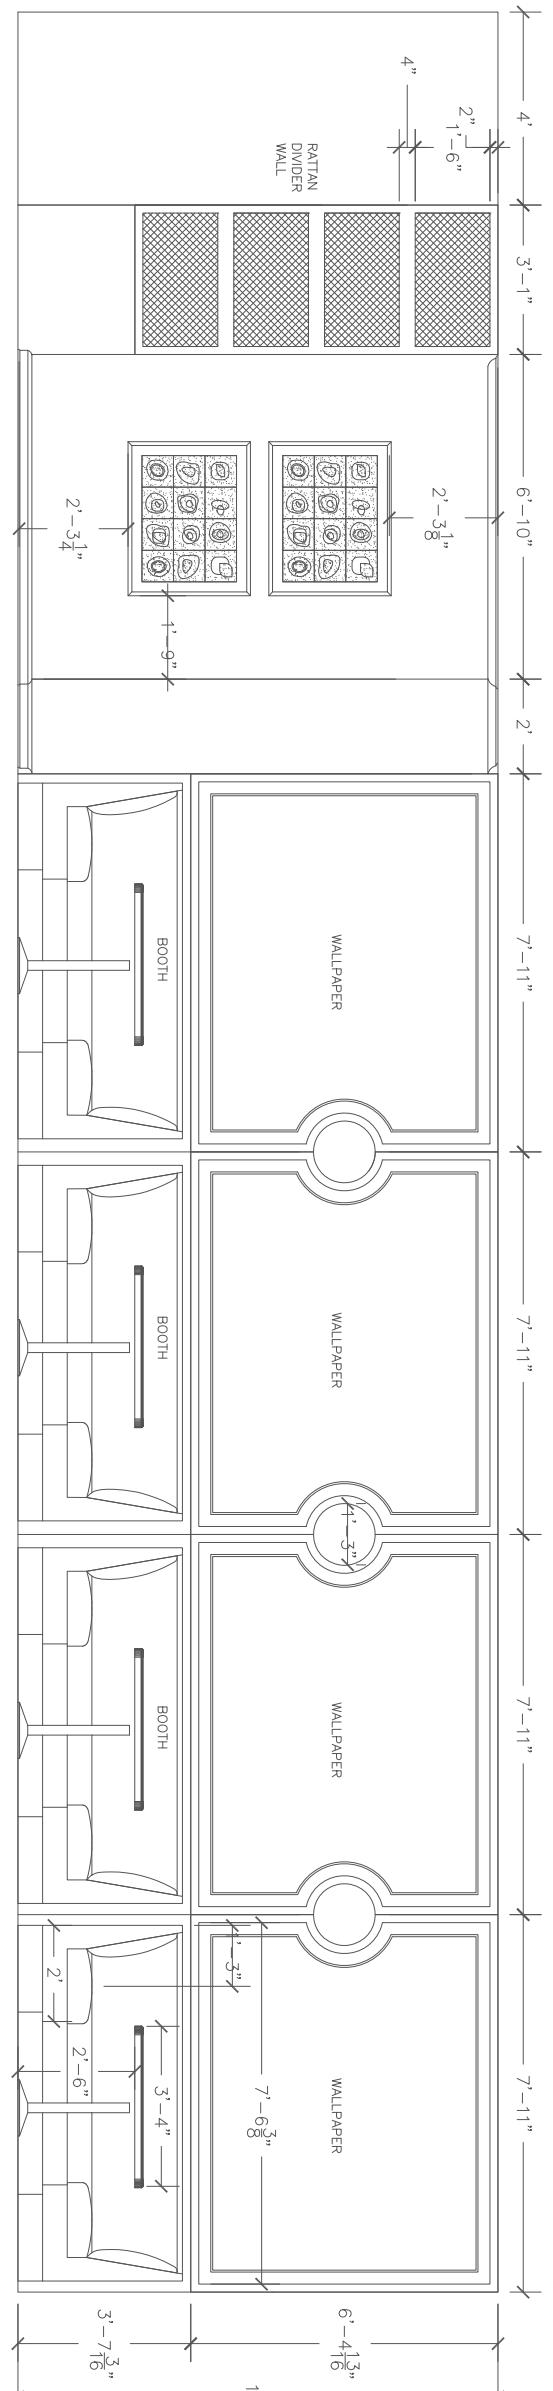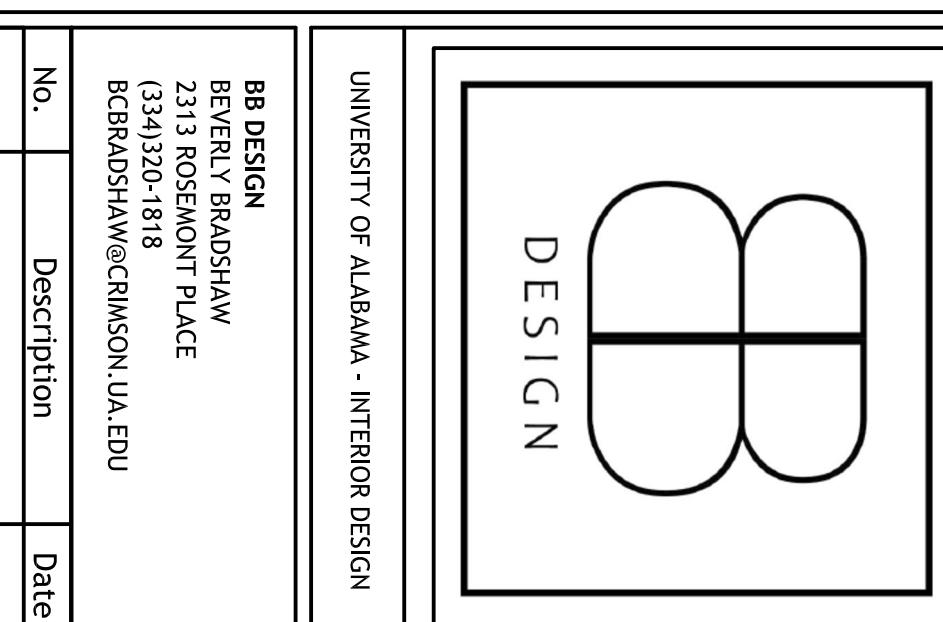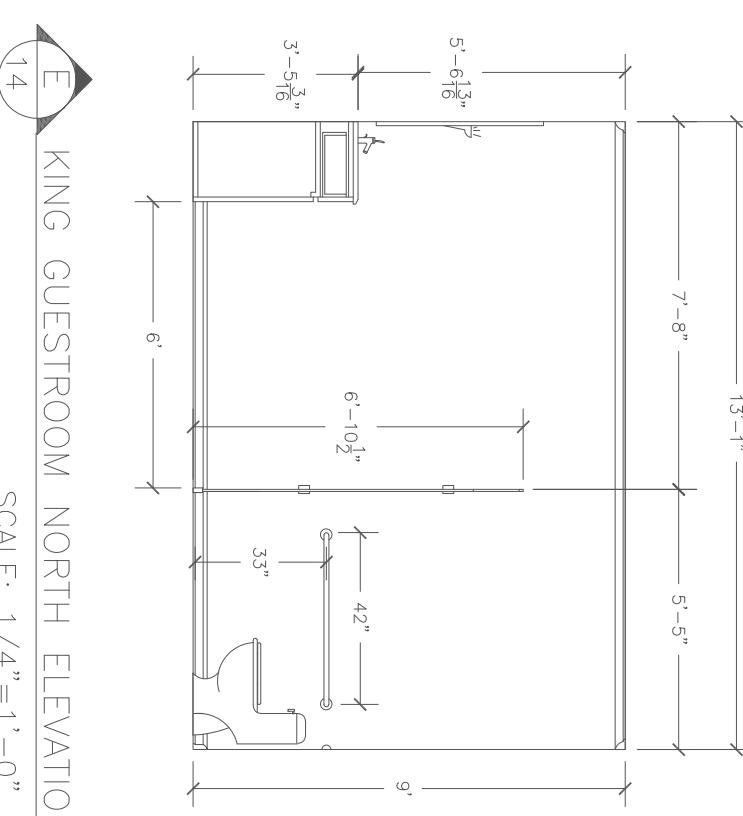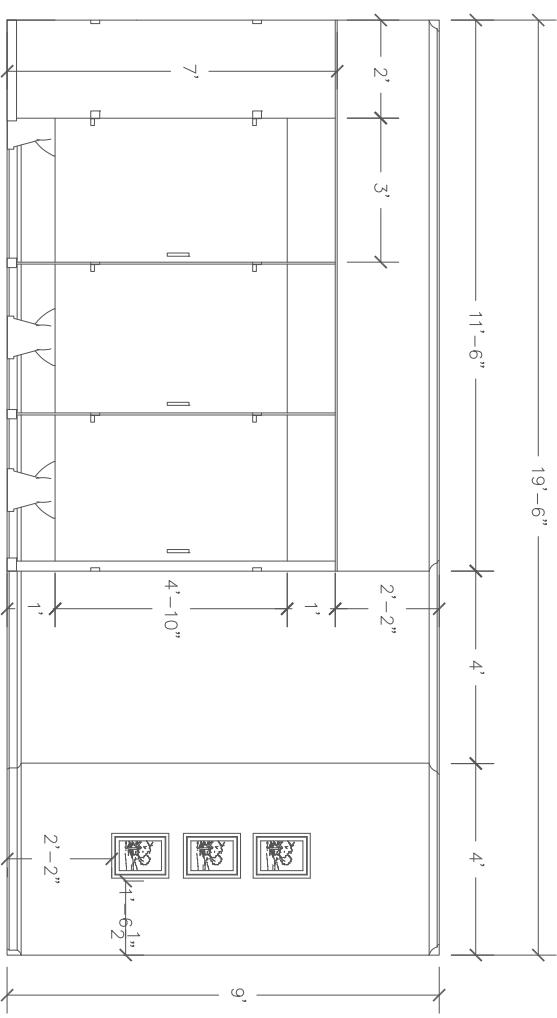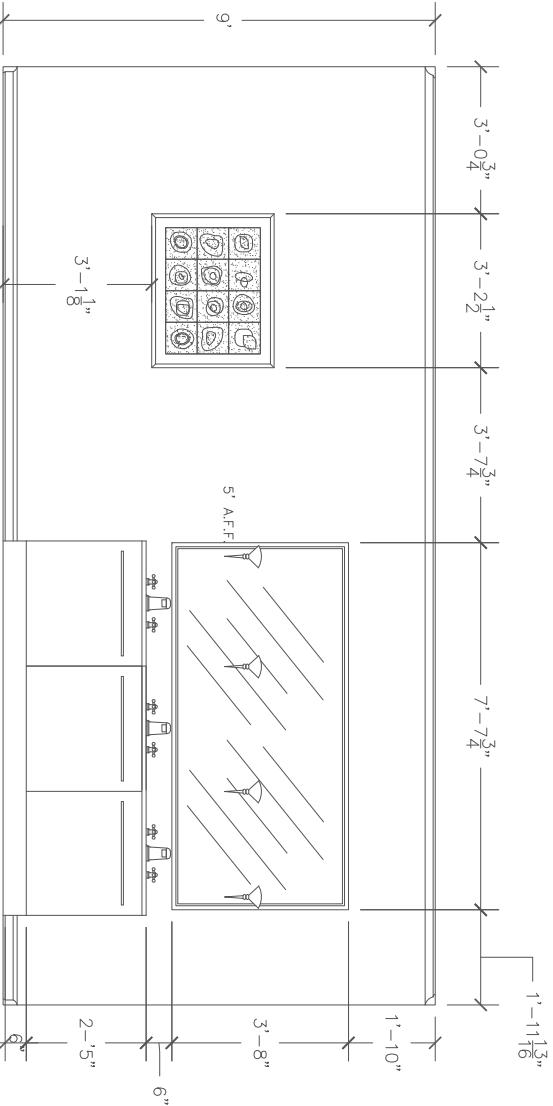

# GALINOIS


## 123 Ocean Drive, Naxos, Cyclades

### 32480

## Restaurant and Public Restroom Elevations

Project Number	2000.01
Drawn By	10 April, 2025 Beverly Bradshaw
Checked By	Bethany Blevins

1/4"=1'-0"

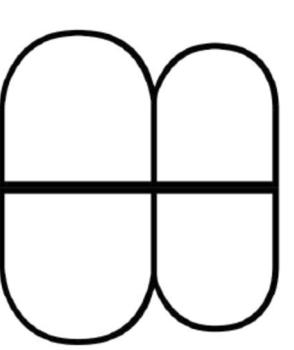


UNIVERSITY OF ALABAMA - INTERIOR DESIGN  
DESIGN


BB DESIGN  
BEVERLY BRADSHAW  
2313 ROSEMONT PLACE  
(334)320-1818  
BCRADSHAW@CRIMSON.UA.EDU

No. Description Date

E SPA WEST ELEVATION  
SCALE: 1/4"=1'-0"

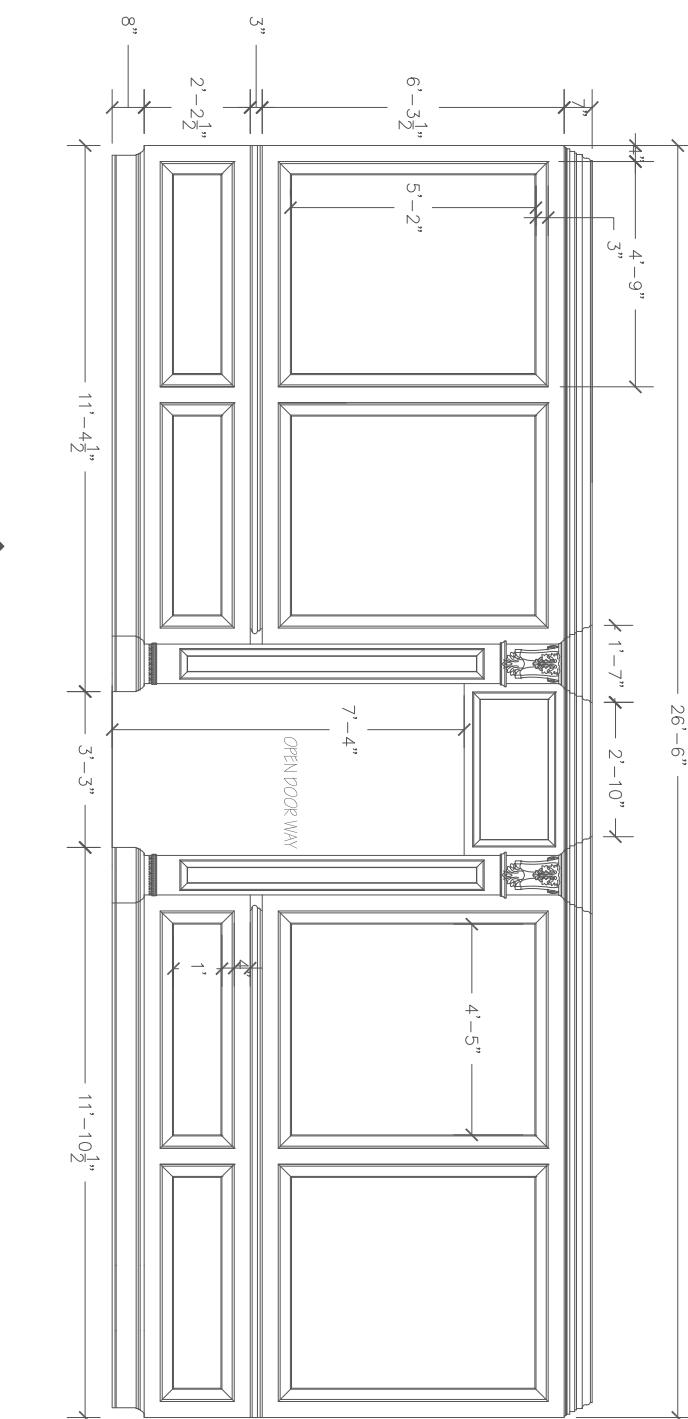


E SPA EAST ELEVATION  
SCALE: 1/4"=1'-0"

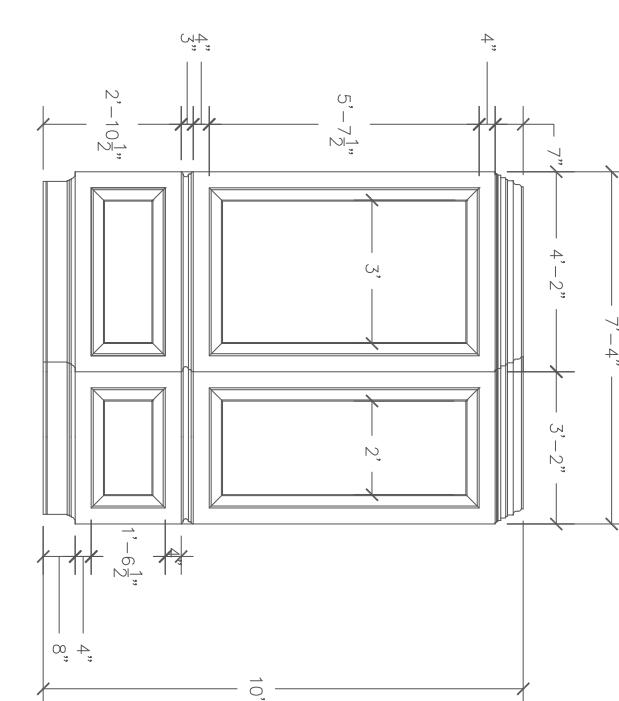


OPEN PORCH AREA


E SPA NORTH ELEVATION  
SCALE: 1/4"=1'-0"

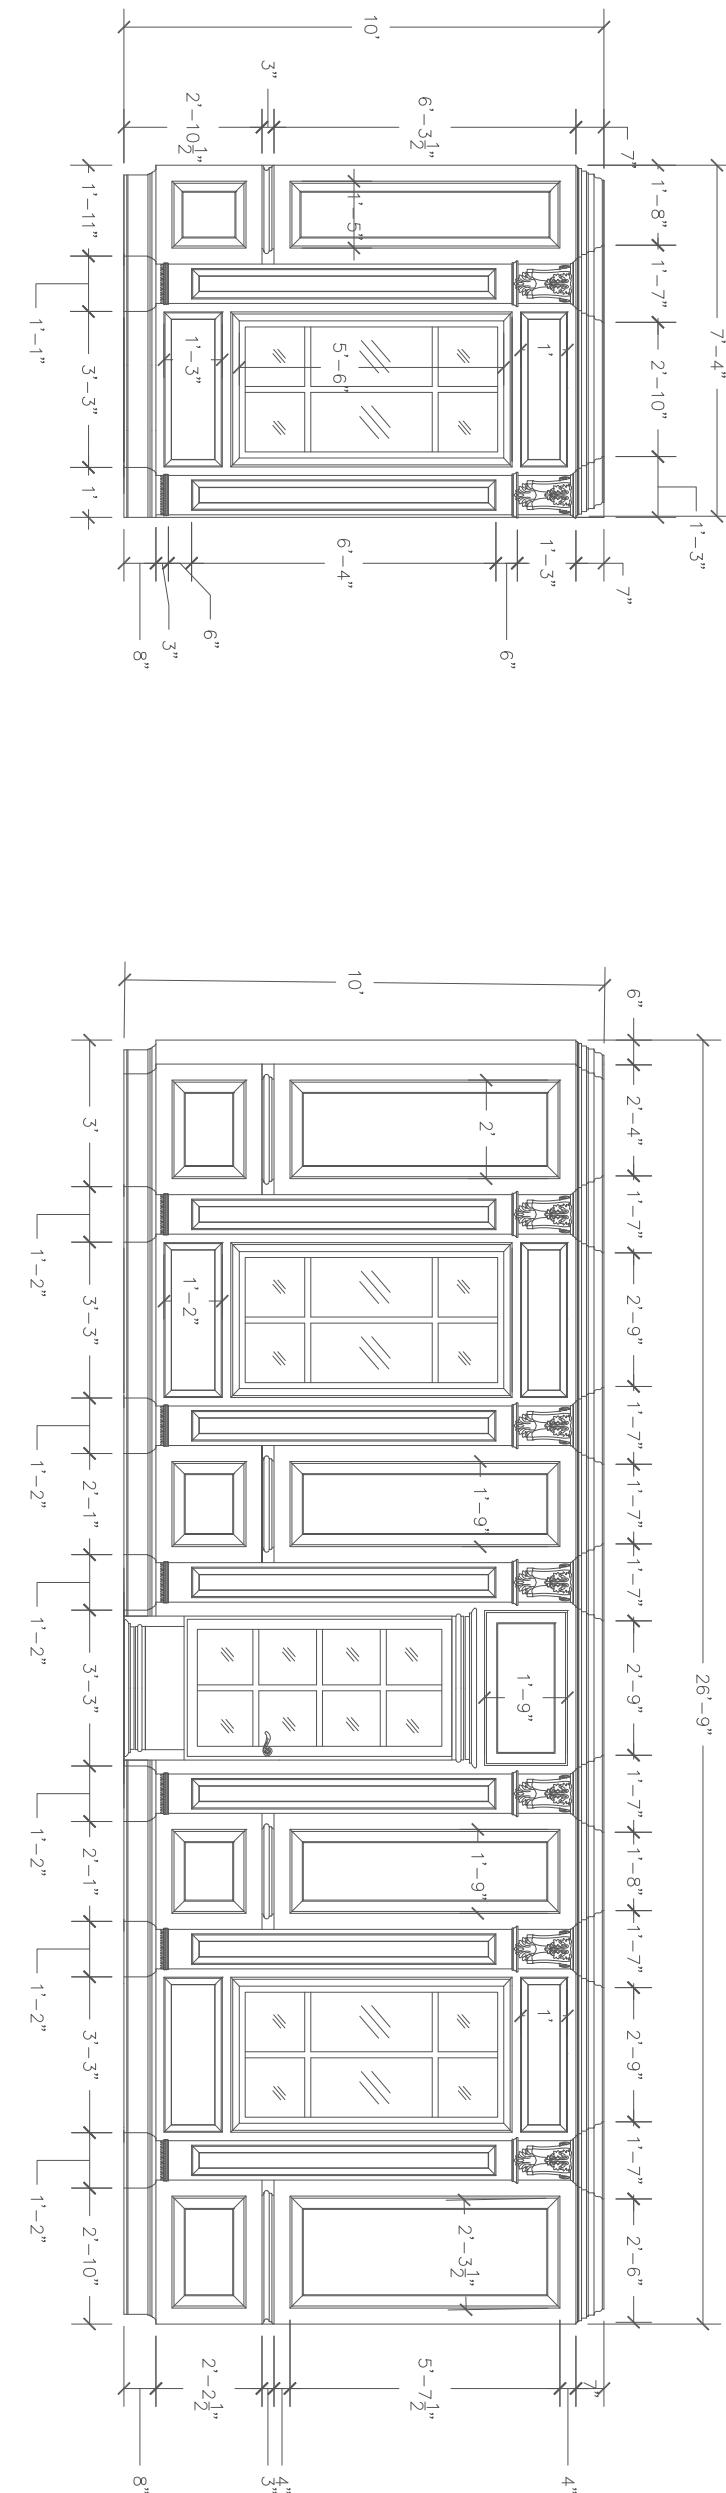


E SPA SOUTH ELEVATION  
SCALE: 1/4"=1'-0"

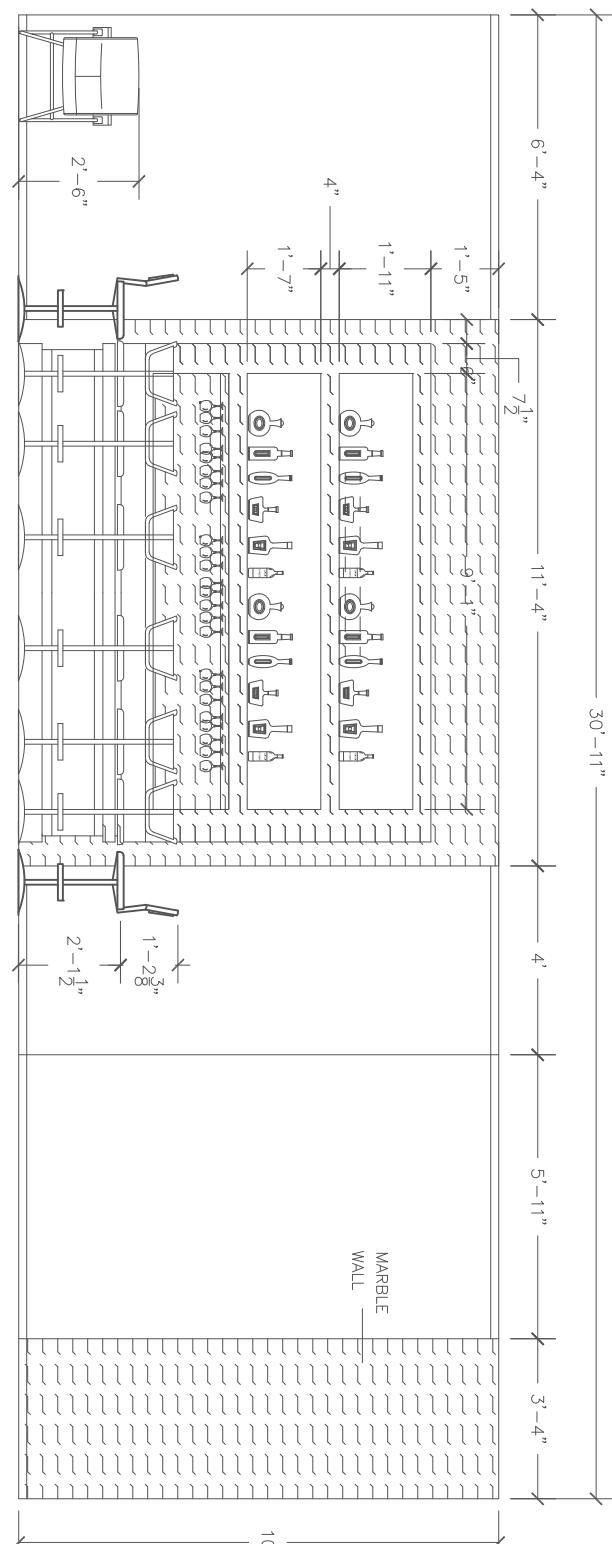

E 2ND FLOOR LOUNGE NORTH ELEVATION  
SCALE: 1/4"=1'-0"

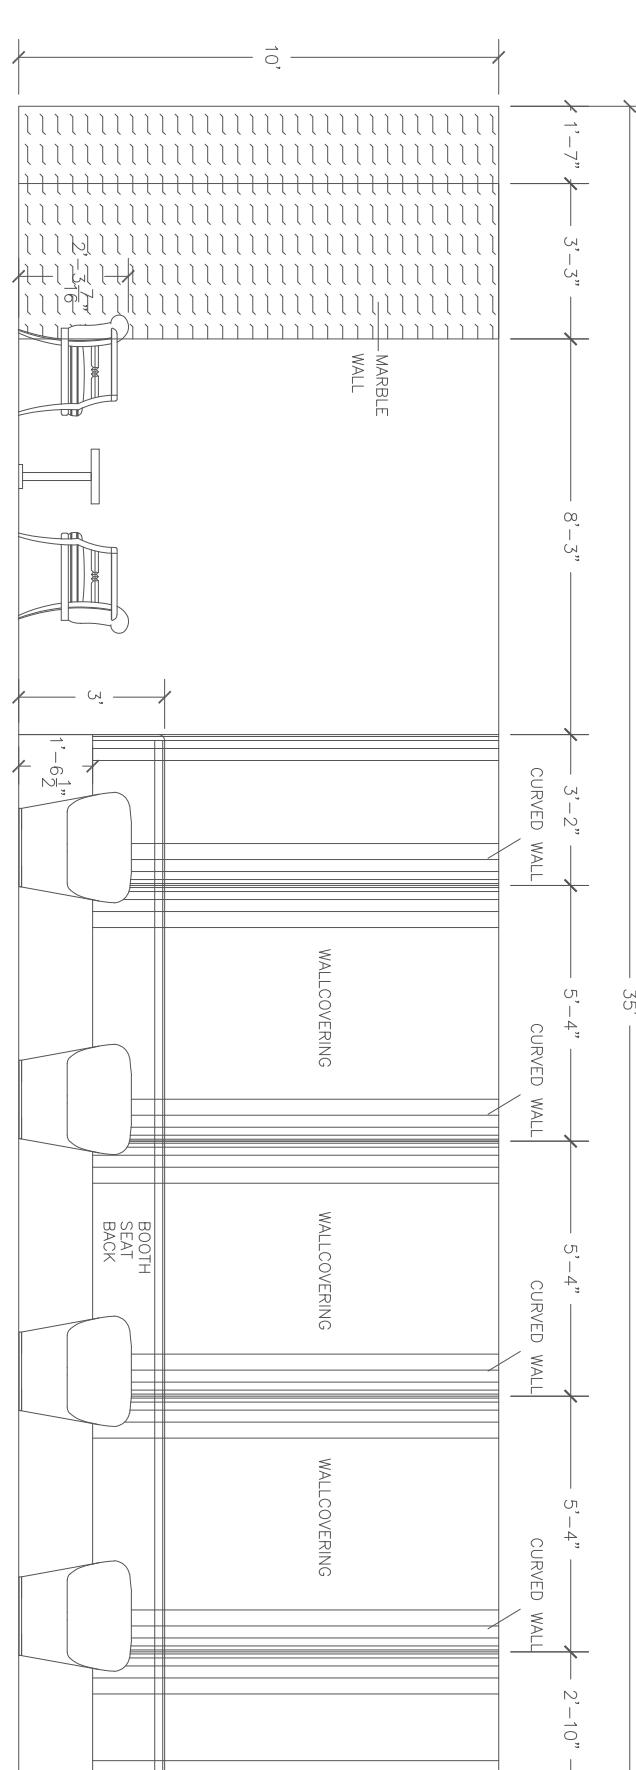

E 2ND FLOOR LOUNGE EAST ELEVATION  
SCALE: 1/4"=1'-0"

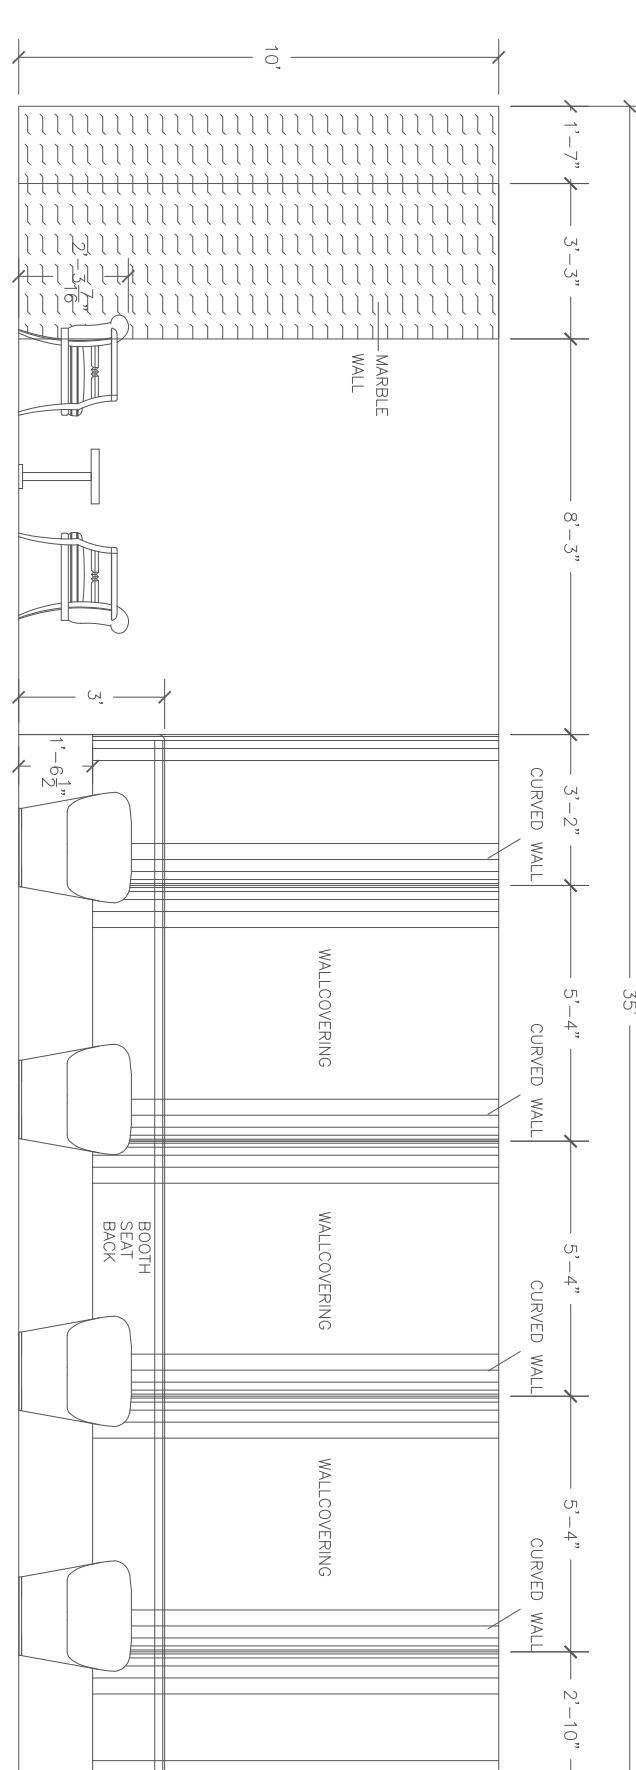




GALINOIS  
123 Ocean Drive,  
Naxos, Cyclades  
32480

Second Floor  
Elevations-  
Spa & Lounge

Project Number	2000.01
Drawn By	10 April, 2025
Checked By	Beverly Bradshaw Bethany Blevins

Scale

$\frac{1}{4}$ "=1'-0"

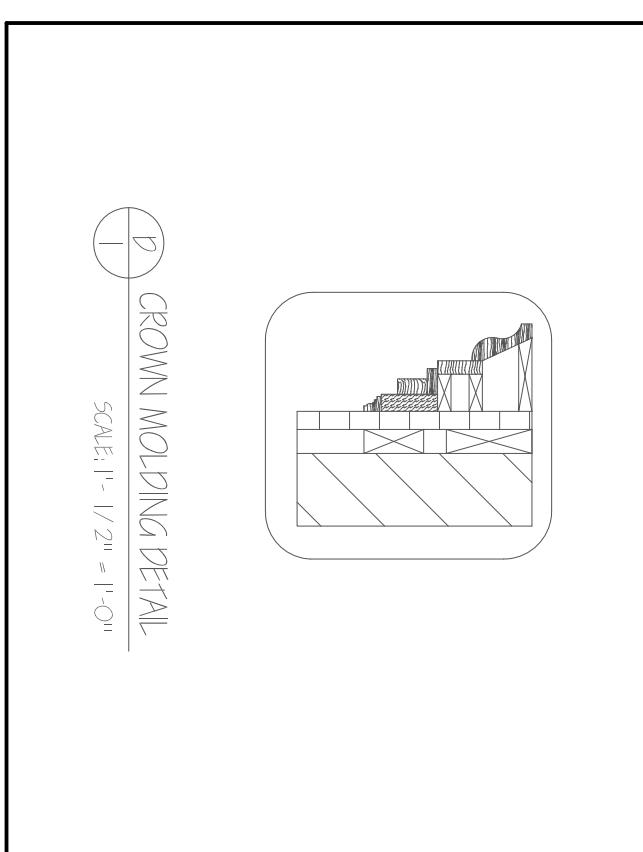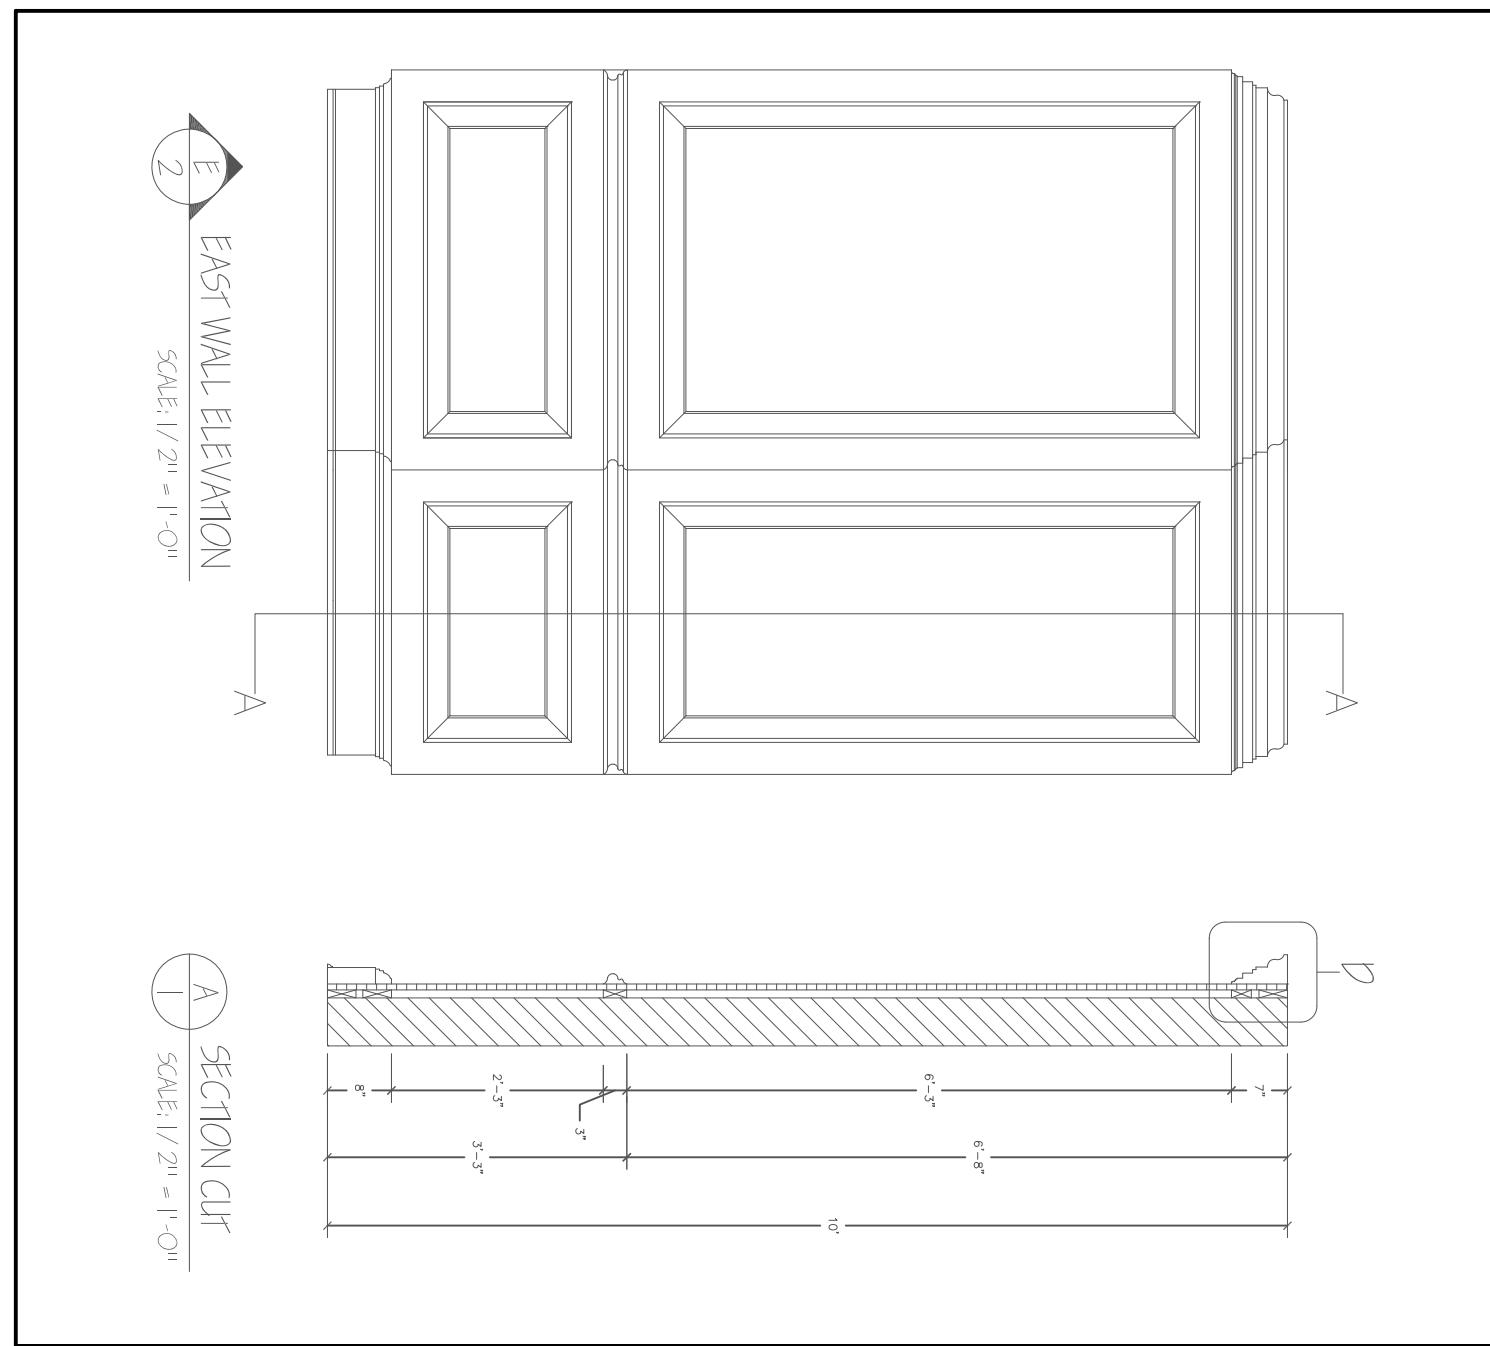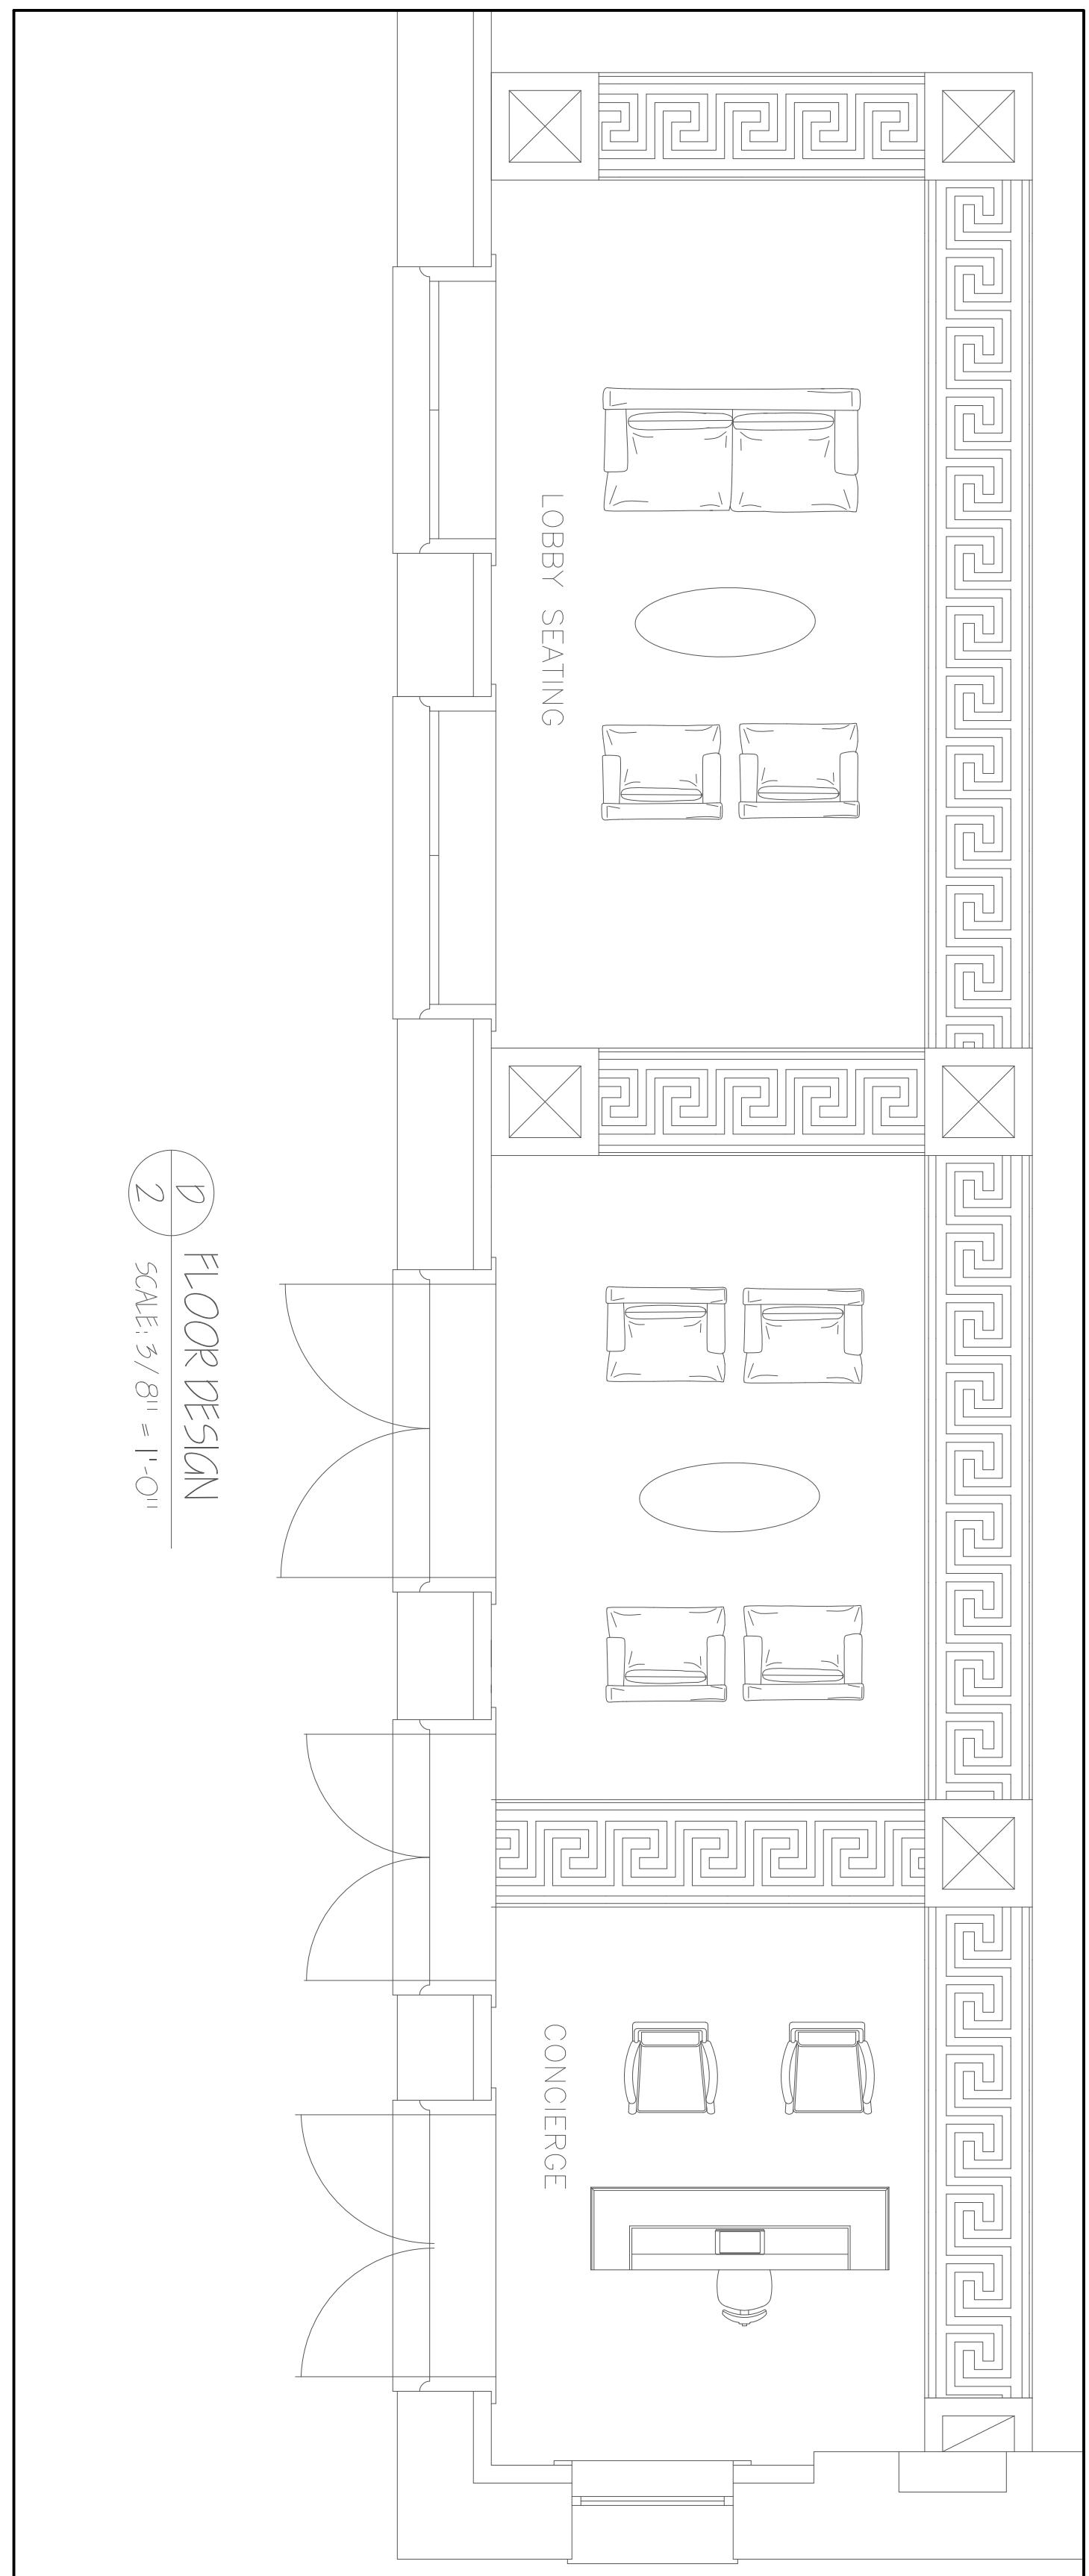

Sections and Details		
Project Number	2000.01	BB DESIGN BEVERLY BRADSHAW 2313 ROSEMONT PLACE (334)320-1818 BCBRADSHAW@CRIMSON.UA.EDU
Drawn By	10 April, 2025	UNIVERSITY OF ALABAMA - INTERIOR DESIGN
Checked By	Beverly Bradshaw	
	Bethany Blevins	
ID5:00	VARIES*	DESIGN
Scale		